


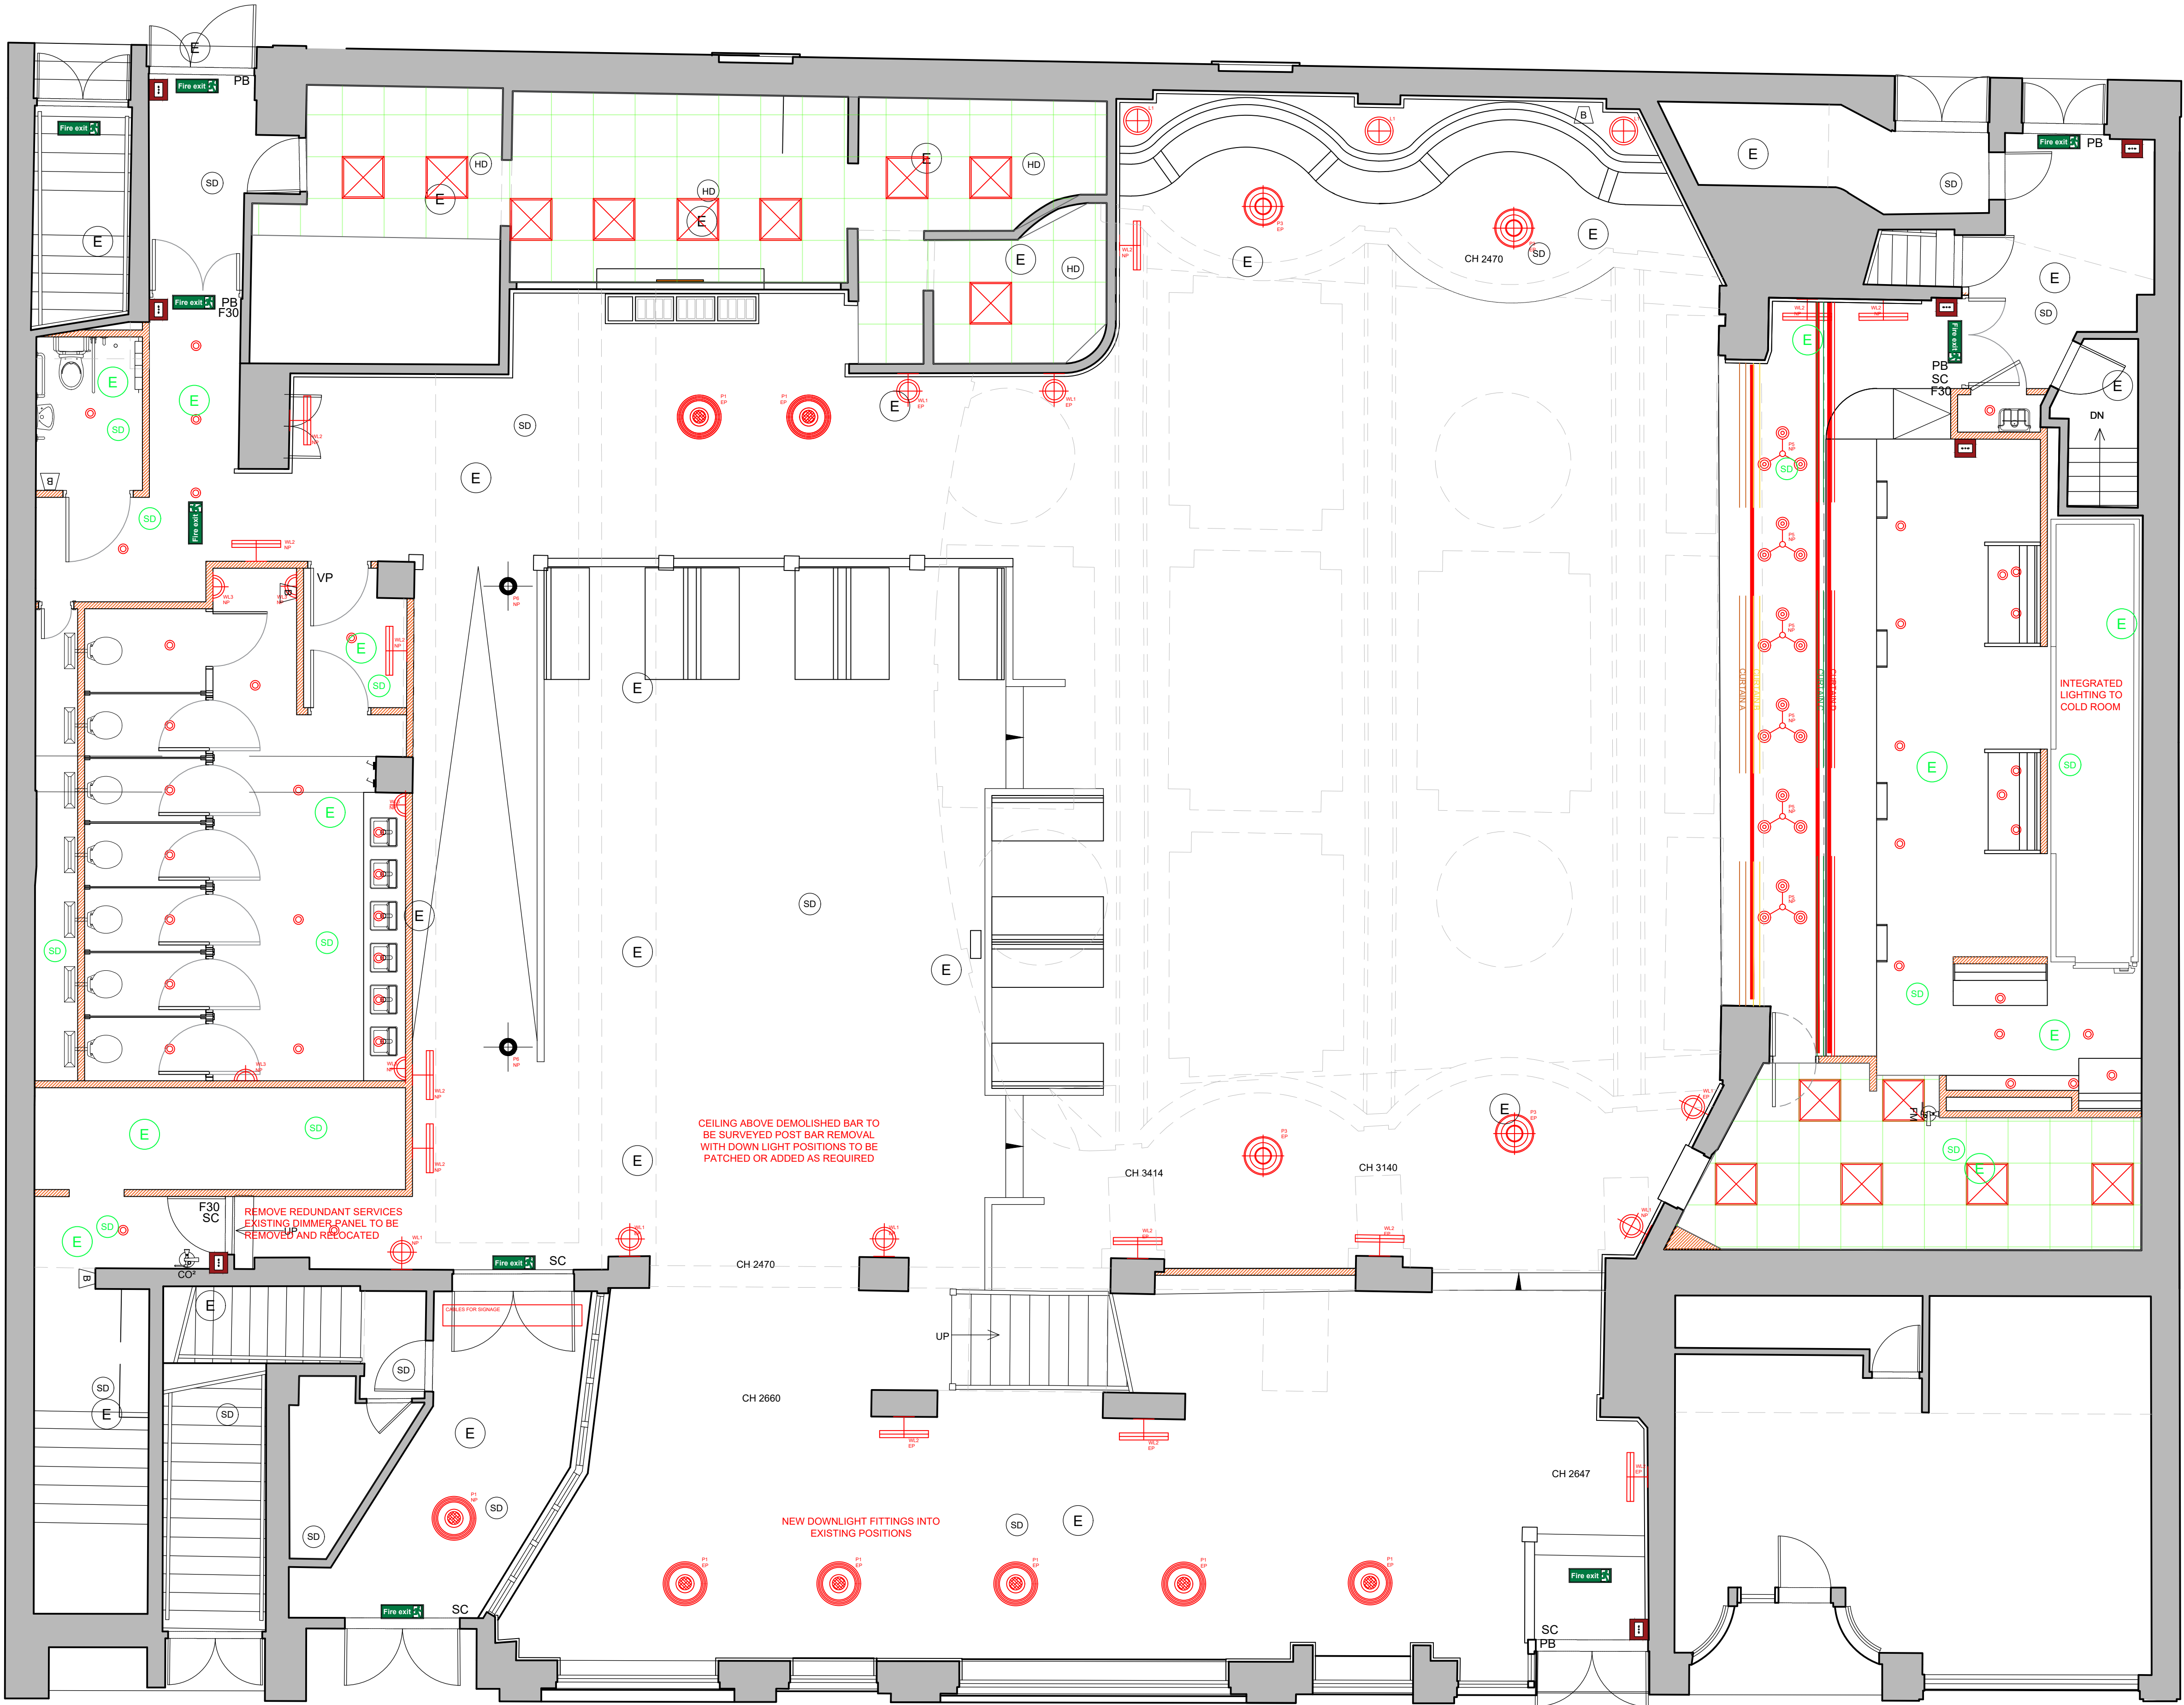

PROPOSED GROUND FLOOR PLAN - LIGHTING PLAN

Scale 1:50

Do not scale from this drawing. All dimensions to be checked on site prior to manufacture and construction. This drawing is the property of Harrison Ince Holdings Limited and should not be reproduced without permission. All discrepancies to be brought to the attention of the architect immediately. This drawing is to be read in conjunction with the specification / bill of quantities and related drawings.

REVISIONS			
-	FIRST ISSUE	19.11.25	SF
A	PLANNING ISSUE	05.12.25	GW
B	ISSUED FOR TENDER	27.03.26	GW
C	CHANGE TO P1 PENDANT TYPE	08.04.26	SF
D	PRESTART ISSUE	12.08.26	GW
E	CONSTRUCTION ISSUE	20.08.26	GW

LIGHTING KEY		
NAME	KEY	IMAGE
WL1 WALL LIGHT REF: DOUBLE ARM WALL LIGHT WITH TWO LARGE PRISMATIC CONES SUPPLIER: E2 CONTRACT LIGHTING FINISH: SATIN BRASS		
WL2 PICTURE LIGHT REF: VINTAGE DETAIL PICTURE LIGHT SUPPLIER: E2 CONTRACT LIGHTING FINISH: SATIN BRASS		
WL3 WALL LIGHT REF: GLASS ROD UP & DOWN WALL LIGHT IP44 SUPPLIER: E2 CONTRACT LIGHTING FINISH: GOLD		
L1 DECORATIVE LAMP REF: HARDWIRED TABLE LAMP WITH HOLOPHANE DOME SHADE SUPPLIER: E2 CONTRACT LIGHTING FINISH: POLISHED BRASS		
P1 PENDANT TYPE 1 REF: CEILING LAMP SUPPLIER: E2 CONTRACT LIGHTING FINISH: ANTIQUE BRASS		
P2 PENDANT TYPE 2 REF: EXISTING CHANDELIERS TO BE CLEANED AND RETAINED IN THEIR CURRENT LOCATION		
P3 PENDANT TYPE 3 REF: HOLOPHANE DOME LIGHT SUPPLIER: E2 CONTRACT LIGHTING FINISH: ANTIQUE BRASS		
P5 PENDANT TYPE 5 REF: WHITE MILK GLASS HANGING LAMP SUPPLIER: E2 CONTRACT LIGHTING FINISH: ANTIQUE BRASS		
P6 PENDANT TYPE 6 REF: EXISTING SMALL CHANDELIERS TO BE TAKEN DOWN, CLEANED AND REINSTALLED IN NEW POSITION		
DL1 DOWNLIGHT TYPE 1 REF: JDW DSOP FINISH: ANTIQUE BRASS		
SKY TILE REF: JDW DSOP		
LED STRIP CURTAIN LIGHT REF: LED TAPE PER ATRIUM SPECIFICATION INSTALLED IN TRACK 48. FITTING TO BE ORDERED BY CONTRACTOR		
CEILING UP LIGHT REF: ANSELL AZTEC FLOOD LIGHT SUPPLIED BY OMEGA - POSITIONS AND NUMBERS APPROX.		
NOTES: ALL FITTING FINISHES TO BE POLISHED BRASS, ANTIQUE BRASS, SATIN BRASS OR GOLD EP - TO REMAIN AS EXISTING ELECTRICAL POINTS NP - NEW POINTS AND FITTINGS TO BE INSTALLED FITTINGS INDICATED IN RED TO BE NEW FITTINGS (INSTALLED WITH NEW OR EXISTING POINTS)		

CONSTRUCTION



HARRISON INCE
ARCHITECTS INTERIOR DESIGNERS

CLIENT
JD WETHERSPOON PLC

PROJECT
THE ART PICTURE HOUSE,
36 HAYMARKET STREET, BURY BL9 0AY

TITLE
PROPOSED GROUND FLOOR
LIGHTING PLAN

DATE	AUGUST 2026	SCALE	1:50 @ A1
JOB NO.	PN 6264	DWG. NO.	AF01 E
DRAWN	CAD/LEB/GW	CHECKED	

EASTGATE
2 CASTLE ST
MANCHESTER
M3 4LZ
TEL: 0161 236 3650
EMAIL: enquiries@harrison-ince.co.uk