


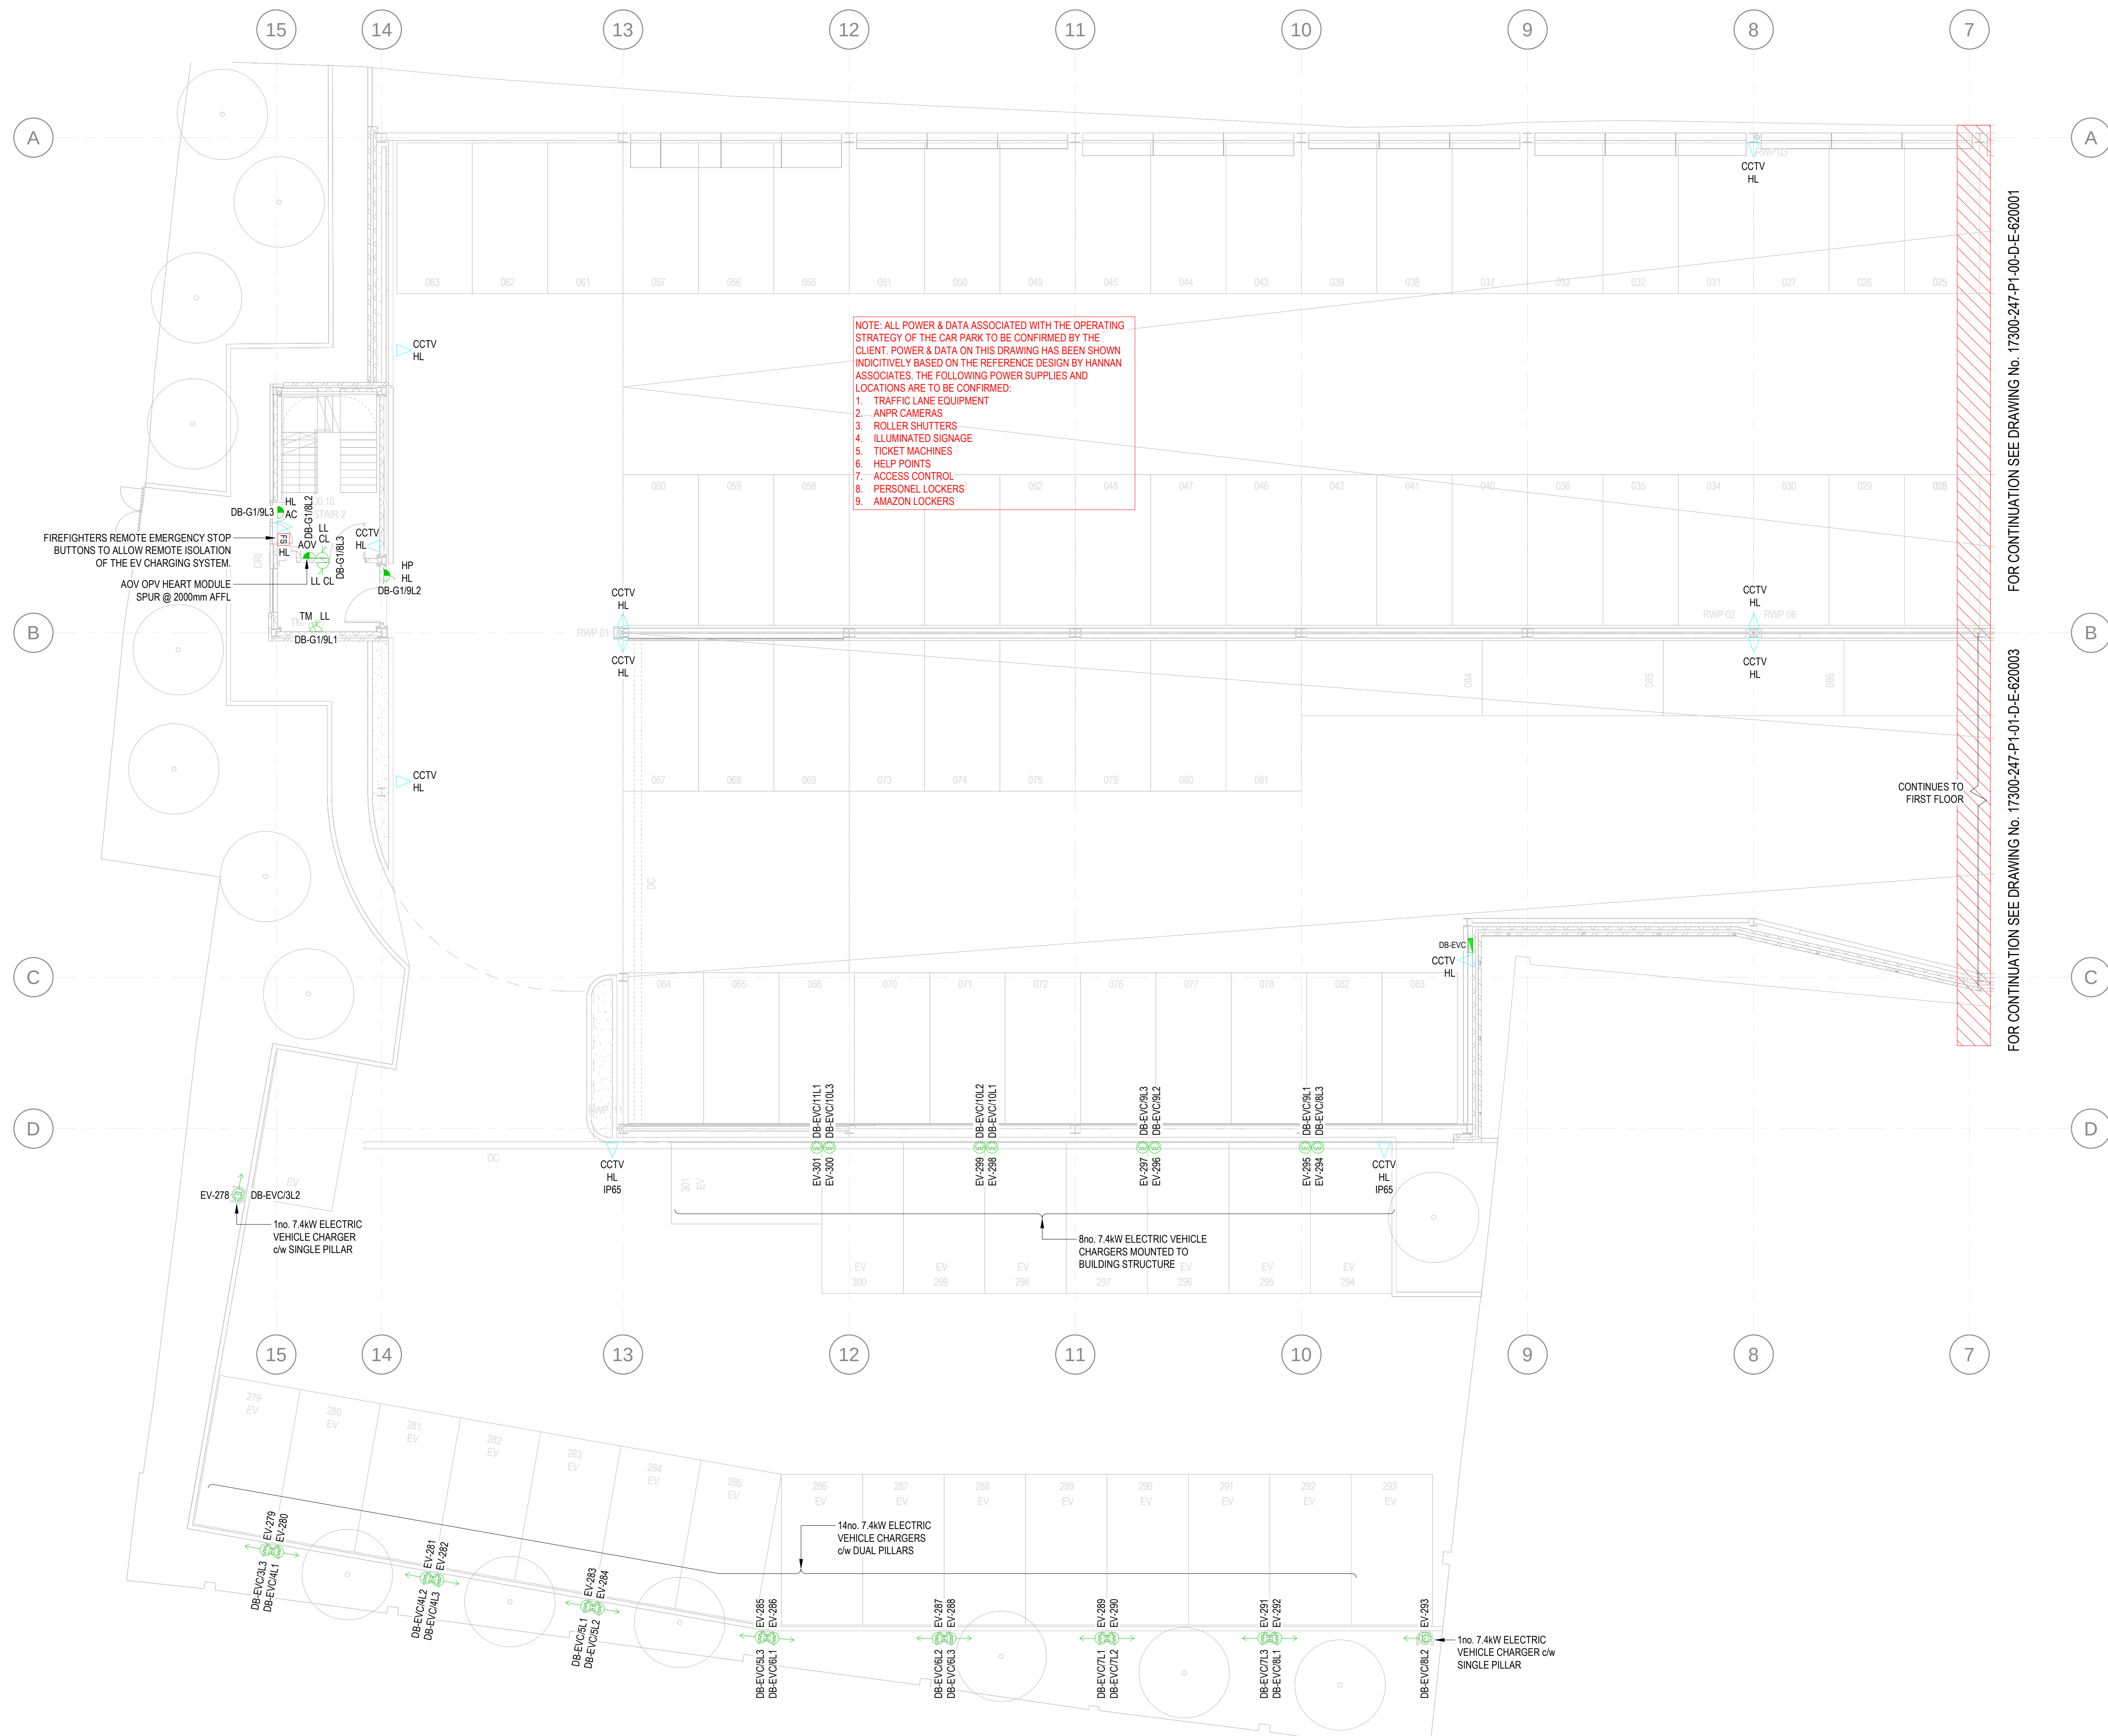

POWER LEGEND

- MAIN LV SWITCHBOARD
- DISTRIBUTION BOARD
- CONNECTION POINT/PANEL
- REFER TO DRAWING FOR DETAILS
- SINGLE SWITCHED SOCKET OUTLET
- 13A RATING UNLESS OTHERWISE NOTED
- CL DENOTES LOCKABLE CLEANERS SOCKET
- TWIN SWITCHED SOCKET OUTLET
- 13A RATING UNLESS OTHERWISE NOTED
- SWITCHED FUSED CONNECTION UNIT
- 13A RATING UNLESS OTHERWISE NOTED
- 13P DENOTES 20A DOUBLE-POLE SWITCH
- UNSWITCHED FUSED CONNECTION UNIT
- 13A RATING UNLESS OTHERWISE NOTED
- INDUSTRIAL SOCKET OUTLET
- RATING & No. OF POLES AS INDICATED
- ROTARY ISOLATOR
- RATING & No. OF POLES AS INDICATED
- ISOLATOR KEY SWITCH
- ELECTRIC VEHICLE CHARGING POINT
- SINGLE 7.4kw
- ELECTRIC VEHICLE CHARGING POINT
- DUAL 7.4kw
- 3-COMPARTMENT DADO TRUNKING
- DADO TRUNKING VERTICAL RISER
- TV CO-AXIAL POINT
- TV
- SINGLE DATA (RJ45) OUTLET
- TWIN DATA (RJ45) OUTLET
- SINGLE CCTV DATA (RJ45) OUTLET
- AC
- SINGLE ACCESS CONTROL DATA (RJ45) OUTLET
- HDMI
- SINGLE HDMI OUTLET
- ANPR
- SINGLE ANPR CCTV DATA (RJ45) OUTLET
- COMMS CABINET / INCOMING TELECOMS DP
- DISABLED ALARM SYSTEM
- DRP
- REFUGEE MAIN PANEL
- FIREMAN'S SWITCH - COLOURED RED

ABBREVIATIONS

- LL LOW LEVEL (450mm AFFL)
- ML MID LEVEL (1200mm AFFL)
- HL HIGH LEVEL (2000mm AFFL)
- CV CEILING VOID
- AFPL ABOVE FINISHED FLOOR LEVEL
- IP65 IP65 RATED FOR EXTERNAL USE
- AC ACCESS CONTROL
- AL AMAZON LOCKER
- ADV AUTOMATIC OPENING VENT
- CCTV CCTV SYSTEM
- CL CLEANERS SOCKET
- DAR DISABLED ALARM RESET
- DIS DISABLED ALARM
- DRCP DISABLED REFUGEE OUTSTATION
- DRP DISABLED REFUGEE MAIN PANEL
- EF EXTRACT FAN
- FAP FIRE ALARM PANEL
- HDM HDMI OUTLET
- HP HELP POINT
- PH ELECTRIC PANEL HEATER
- PL PERSONAL LOCKERS
- TH TUBULAR HEATER
- TM TICKET MACHINE
- WH ELECTRIC WATER HEATER

NOTES

1. THIS DRAWING SHALL BE READ IN CONJUNCTION WITH ALL OTHER 247 GROUP DRAWINGS AND DOCUMENTATION.
2. THE ELECTRICAL INSTALLATION SHALL BE IN ACCORDANCE WITH THE LATEST EDITION OF THE IET WIRING REGULATIONS BS7671, INCLUDING ANY AMENDMENTS.
3. ALL POWER SUPPLIES TO BE INSTALLED AS PER THE LOCATIONS ON THIS DRAWING, UNLESS ADVISED OTHERWISE BEFORE INSTALLATION COMMENCES.
4. ALL CIRCUITS ARE PROTECTED BY AN MCB/RCD AS PER THE DISTRIBUTION BOARD SCHEDULES. ALL SOCKET OUTLETS ARE PROTECTED WITH RCDs.

C01	CONSTRUCTION ISSUE	JD	JM	15/08/2025
P01	PRELIMINARY ISSUE	JD	JM	22/07/2025
rev	description	dwn	chkd	date

Status CONSTRUCTION

Client VINCI BUILDING

Architect/Proj Jon Matthews Architects

24-7 Group
Unit 5, Cranford Drive, Knebworth, Herts, SG9 6BN
0161 8200047 | mail@24-7group.co.uk | www.24-7group.co.uk

project PRESTWICH TRAVEL HUB

title GROUND FLOOR
SMALL POWER & ANCILLARY
SERVICES LAYOUT
SHEET 1 OF 2

project no.	drawn by	date	checked	scale
PN01725	JD	JUNE 2025	JM	1:100 @ A0
drawing no.				revision
17300-247-P1-00-D-E-620000				C01