


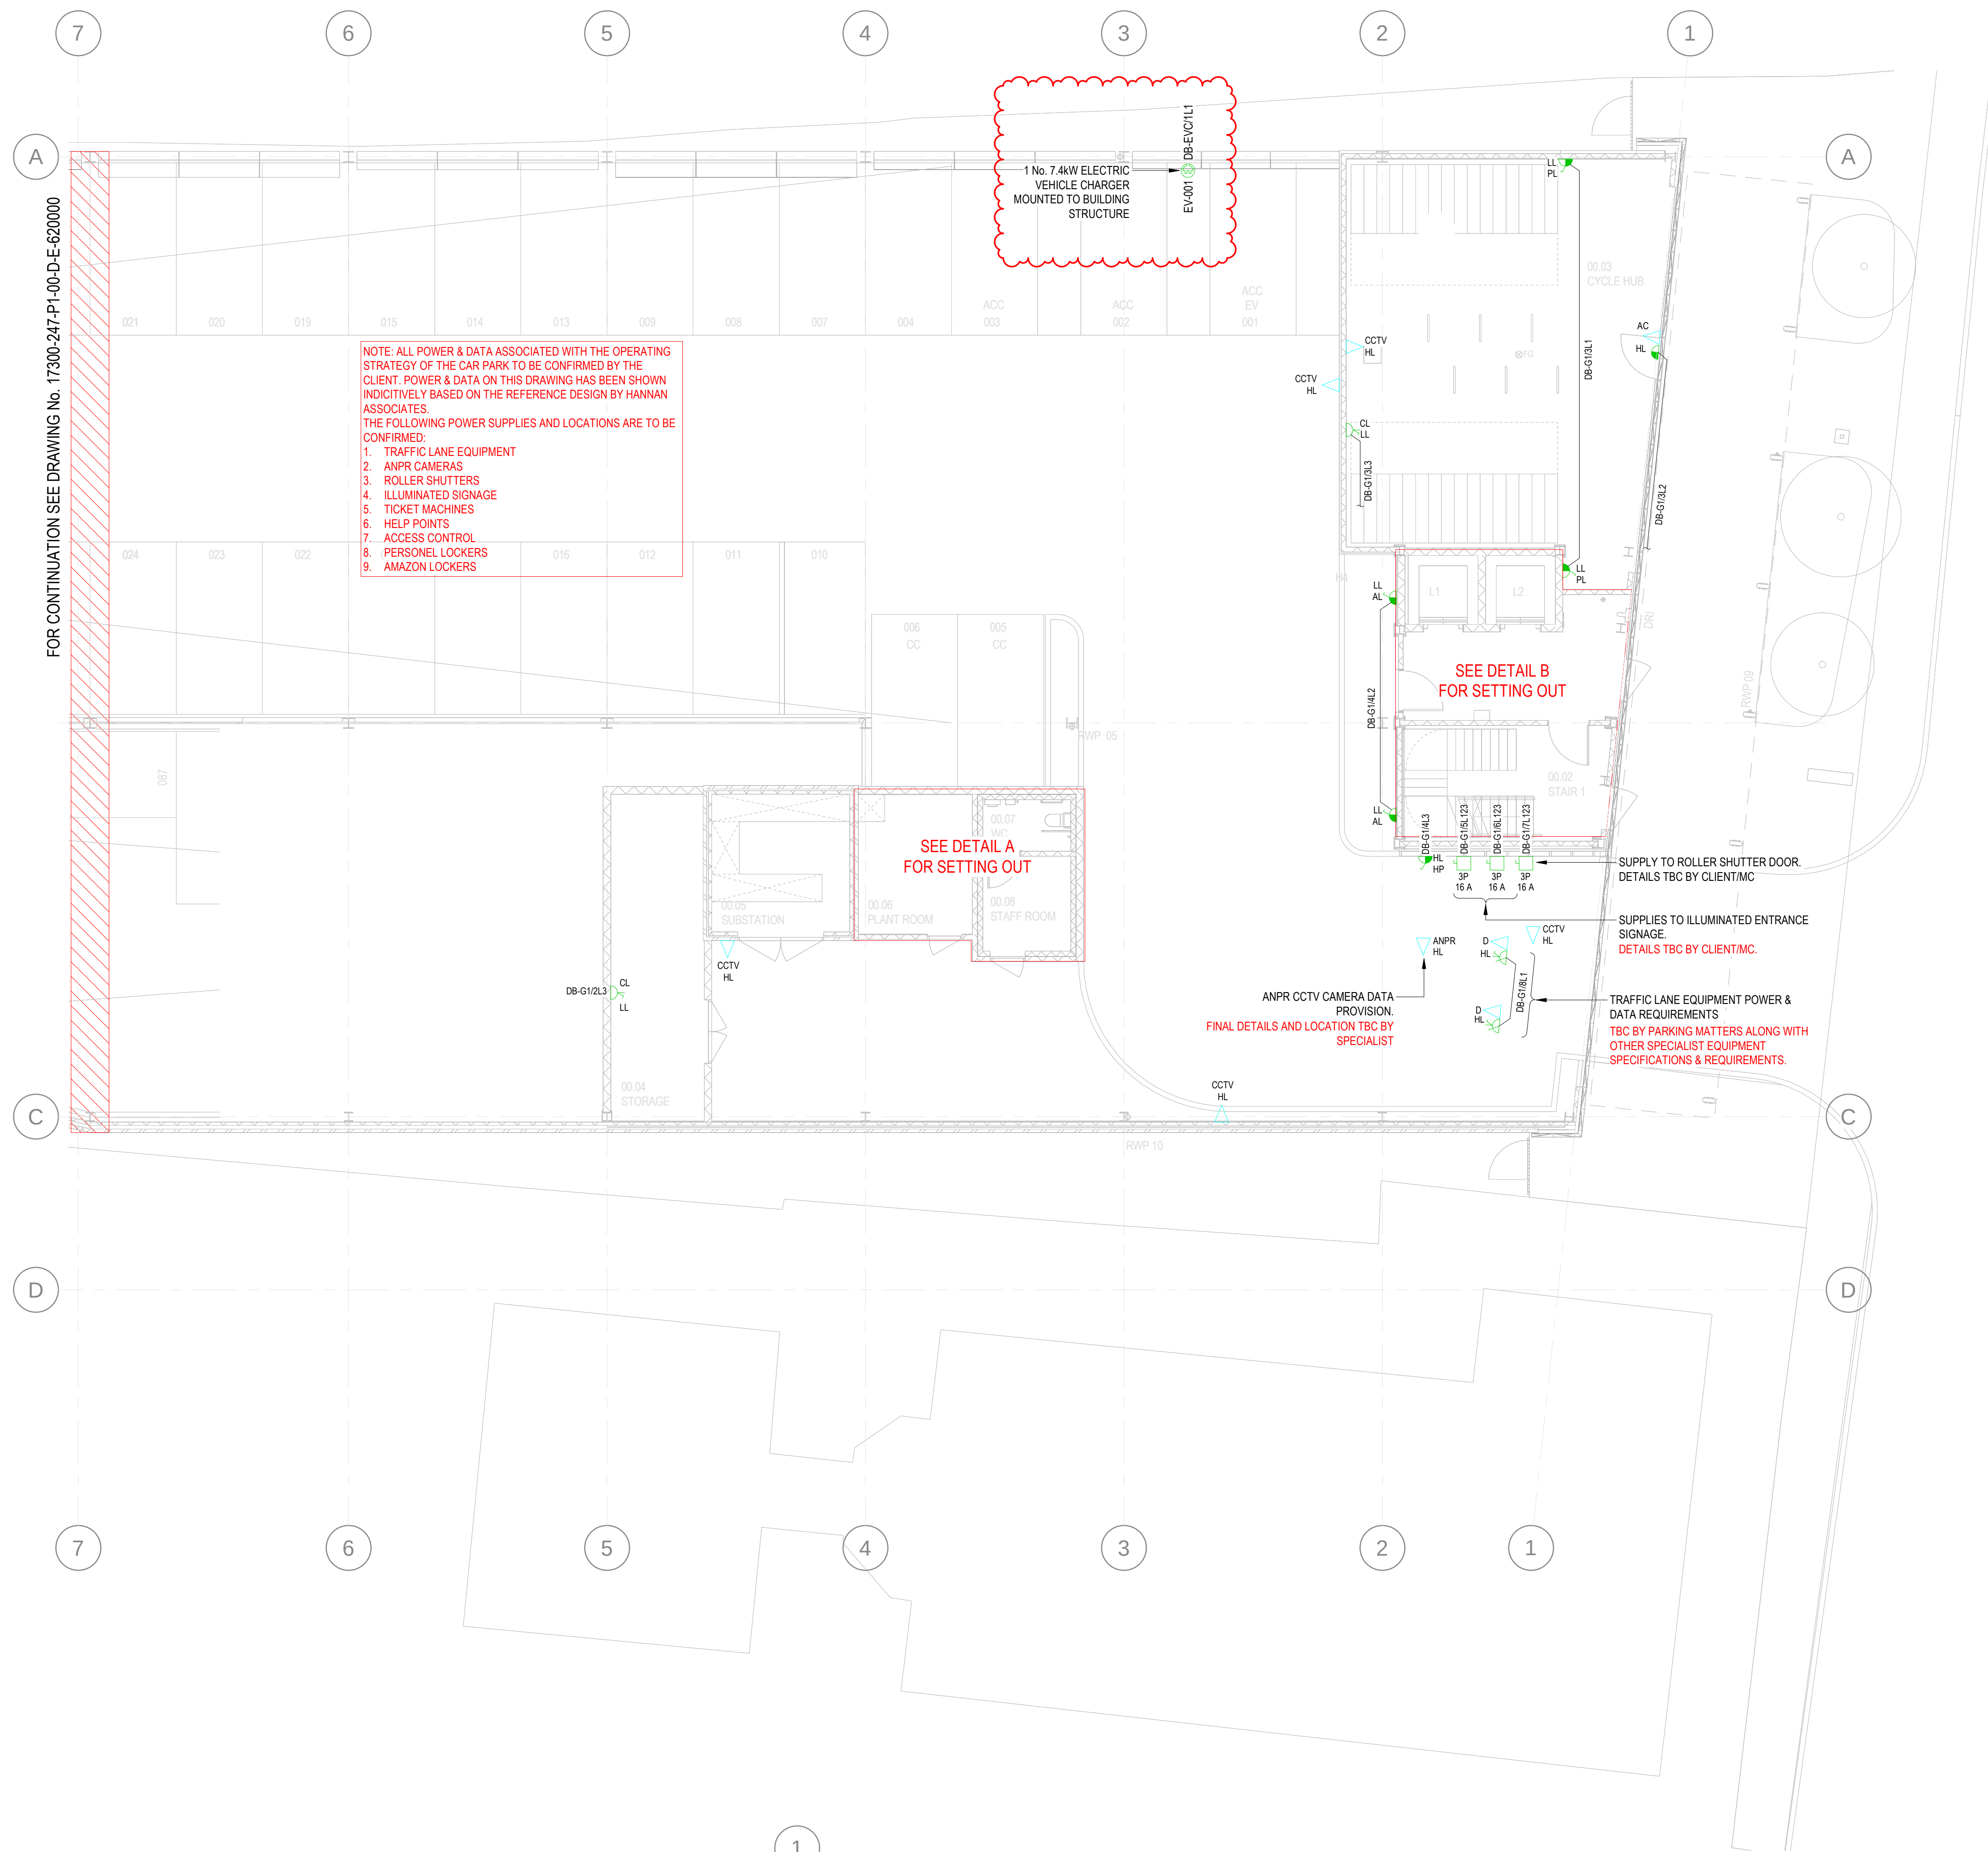

## POWER LEGEND


- MAIN LV SWITCHBOARD
- DISTRIBUTION BOARD
- CONNECTION POINT/PANEL
- REFER TO DRAWING FOR DETAILS
- SINGLE SWITCHED SOCKET OUTLET
- 13A RATING UNLESS OTHERWISE NOTED
- CL DENOTES LOCKABLE CLEANERS SOCKET
- TWIN SWITCHED SOCKET OUTLET
- 13A RATING UNLESS OTHERWISE NOTED
- SWITCHED FUSED CONNECTION UNIT
- 13A RATING UNLESS OTHERWISE NOTED
- 13P DENOTES 20A DOUBLE-POLE SWITCH
- UNSWITCHED FUSED CONNECTION UNIT
- 13A RATING UNLESS OTHERWISE NOTED
- INDUSTRIAL SOCKET OUTLET
- RATING & No. OF POLES AS INDICATED
- ROTARY ISOLATOR
- RATING & No. OF POLES AS INDICATED
- ISOLATOR KEY SWITCH
- ELECTRIC VEHICLE CHARGING POINT
- SINGLE 7.4kw
- ELECTRIC VEHICLE CHARGING POINT
- DUAL 7.4kw
- 3-COMPARTMENT DADO TRUNKING
- DADO TRUNKING VERTICAL RISER
- TV CO-AXIAL POINT
- D
- SINGLE DATA (RJ45) OUTLET
- TWIN DATA (RJ45) OUTLET
- SINGLE CCTV DATA (RJ45) OUTLET
- SINGLE ACCESS CONTROL DATA (RJ45) OUTLET
- SINGLE HDMI OUTLET
- SINGLE ANPR CCTV DATA (RJ45) OUTLET
- COMMS CABINET / INCOMING TELECOMS DP
- DISABLED ALARM SYSTEM
- REFUGE MAIN PANEL
- DRP
- FIREMAN'S SWITCH - COLOURED RED

## ABBREVIATIONS


- LL LOW LEVEL (450mm AFFL)
- ML MID LEVEL (1200mm AFFL)
- HL HIGH LEVEL (2000mm AFFL)
- CV CEILING VOID
- AFLL ABOVE FINISHED FLOOR LEVEL
- IPBS IPBS RATED FOR EXTERNAL USE
- AC ACCESS CONTROL
- AL AMAZON LOCKER
- ADV AUTOMATIC OPENING VENT
- CCTV CCTV SYSTEM
- CL CLEANERS SOCKET
- DAR DISABLED ALARM RESET
- DIS DISABLED ALARM
- DRCP DISABLED REFUGE OUTSTATION
- DRP DISABLED REFUGE MAIN PANEL
- EF EXTRACT FAN
- FAP FIRE ALARM PANEL
- HDMI HDMI OUTLET
- HP HELP POINT
- PH ELECTRIC PANEL HEATER
- PL PERSONAL LOCKERS
- TH TUBULAR HEATER
- TM TICKET MACHINE
- WH ELECTRIC WATER HEATER

## NOTES


- THIS DRAWING SHALL BE READ IN CONJUNCTION WITH ALL OTHER 247 GROUP DRAWINGS AND DOCUMENTATION.
- THE ELECTRICAL INSTALLATION SHALL BE IN ACCORDANCE WITH THE LATEST EDITION OF THE IET WIRING REGULATIONS BS7671, INCLUDING ANY AMENDMENTS.
- ALL POWER SUPPLIES TO BE INSTALLED AS PER THE LOCATIONS ON THIS DRAWING, UNLESS ADVISED OTHERWISE BEFORE INSTALLATION COMMENCES.
- ALL CIRCUITS ARE PROTECTED BY AN MCB/RCD AS PER THE DISTRIBUTION BOARD SCHEDULES. ALL SOCKET OUTLETS ARE PROTECTED WITH RCDs.

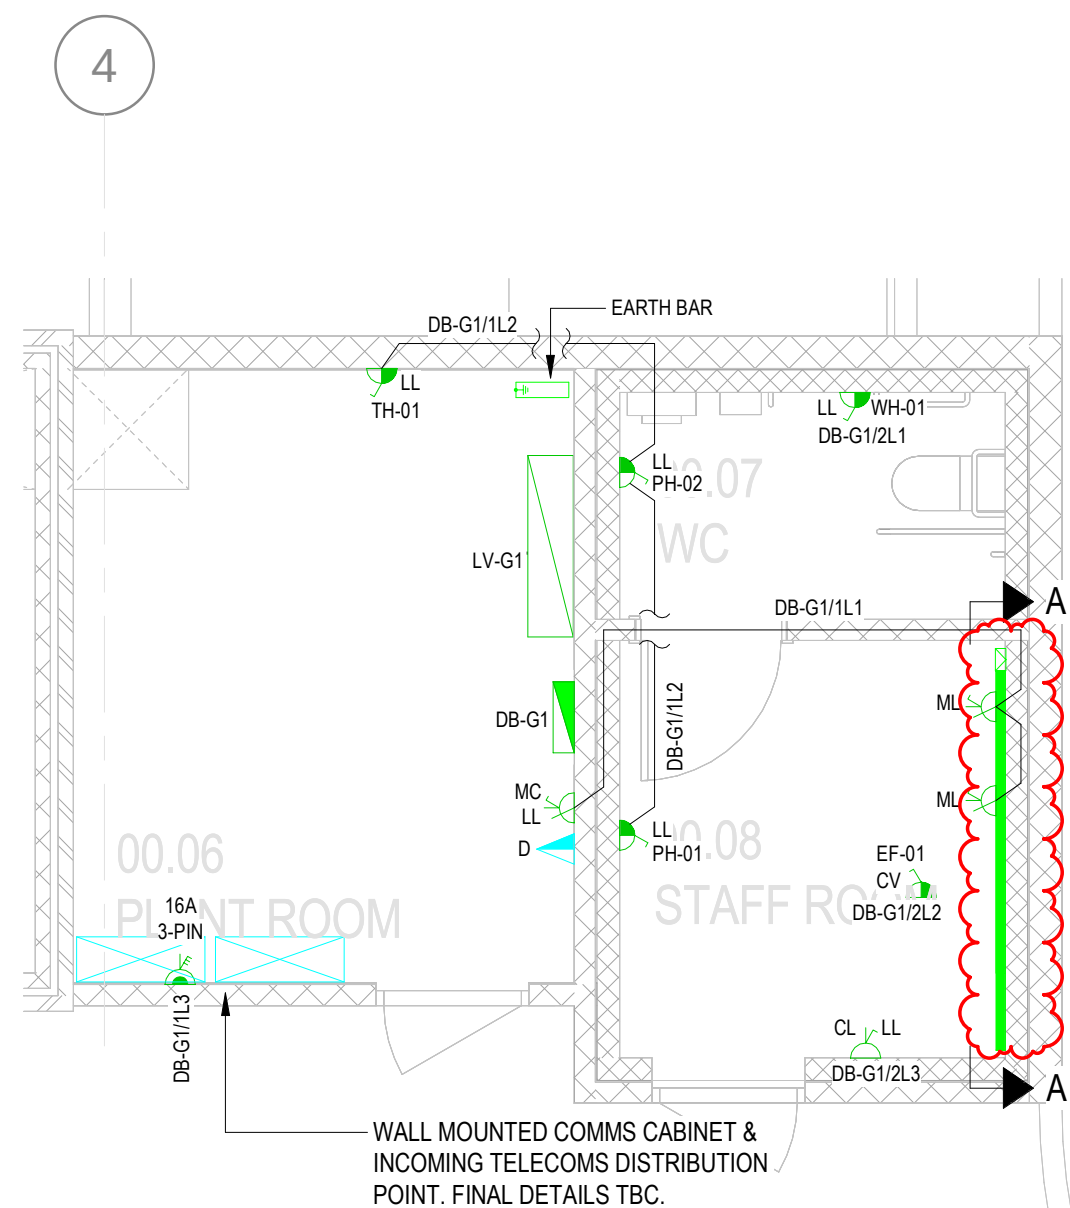

DETAIL A  
SCALE 1:50

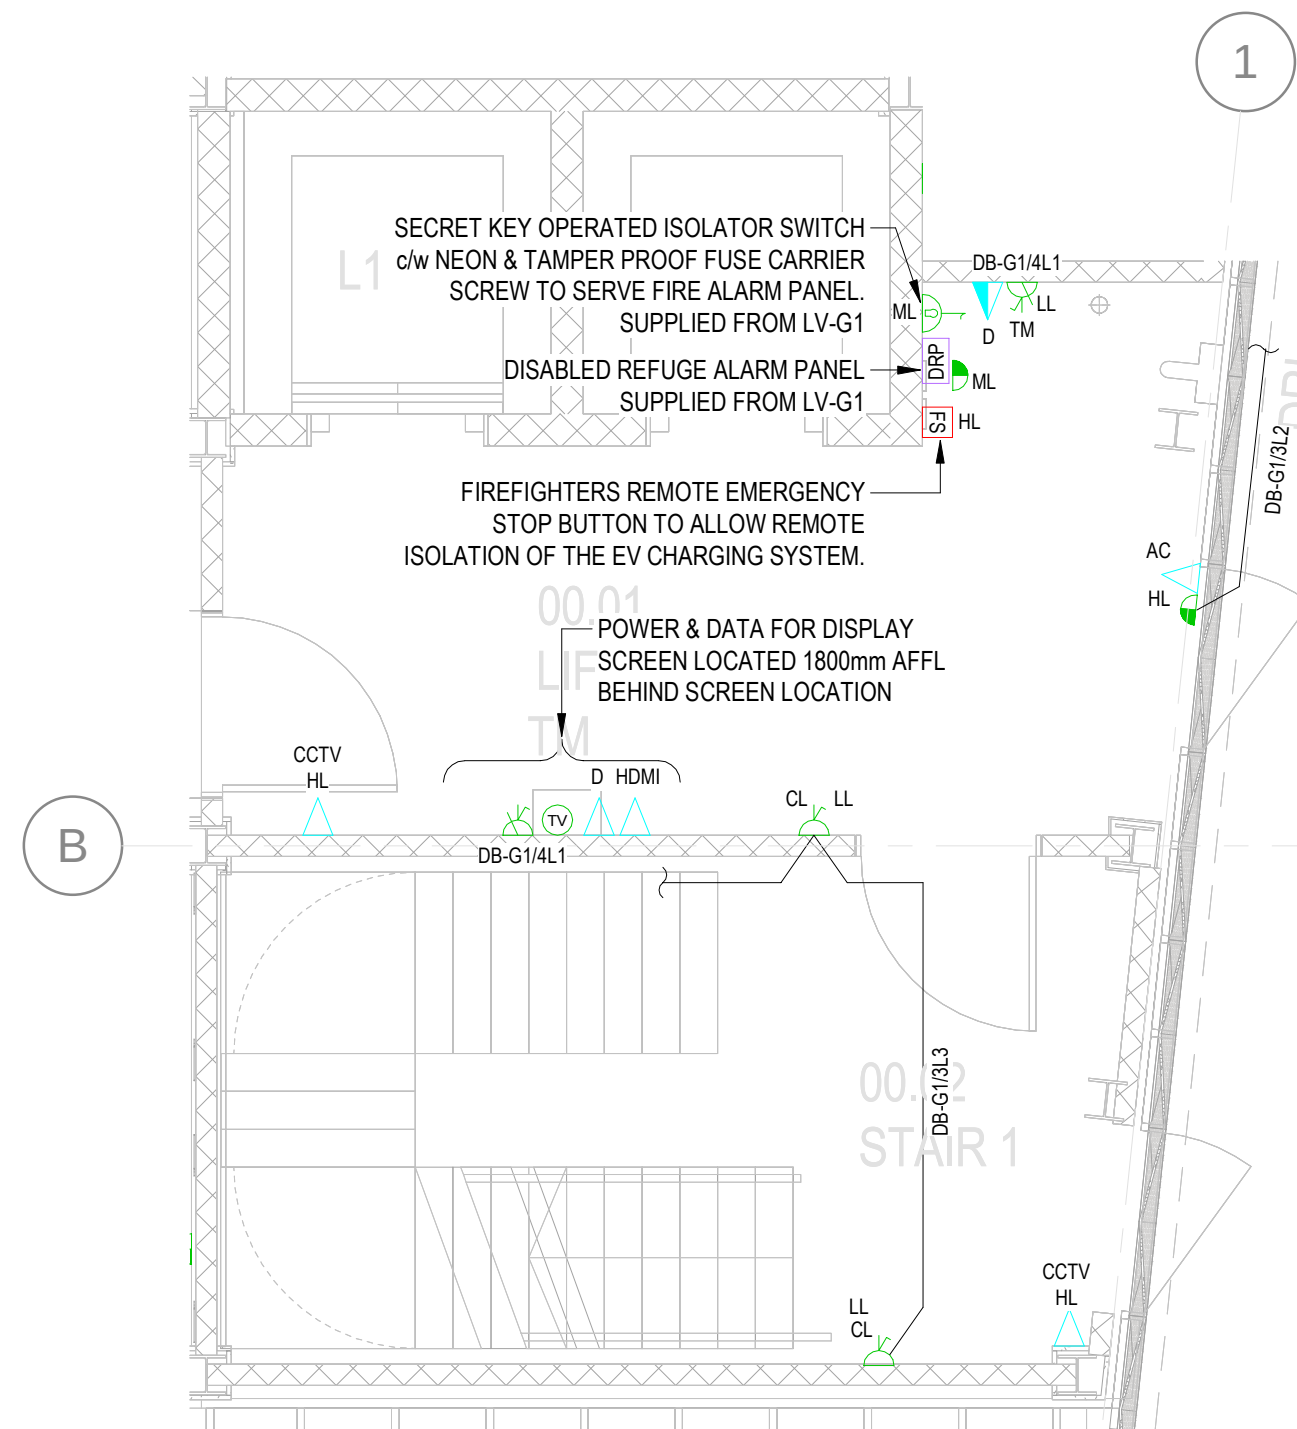

DETAIL B  
SCALE 1:50

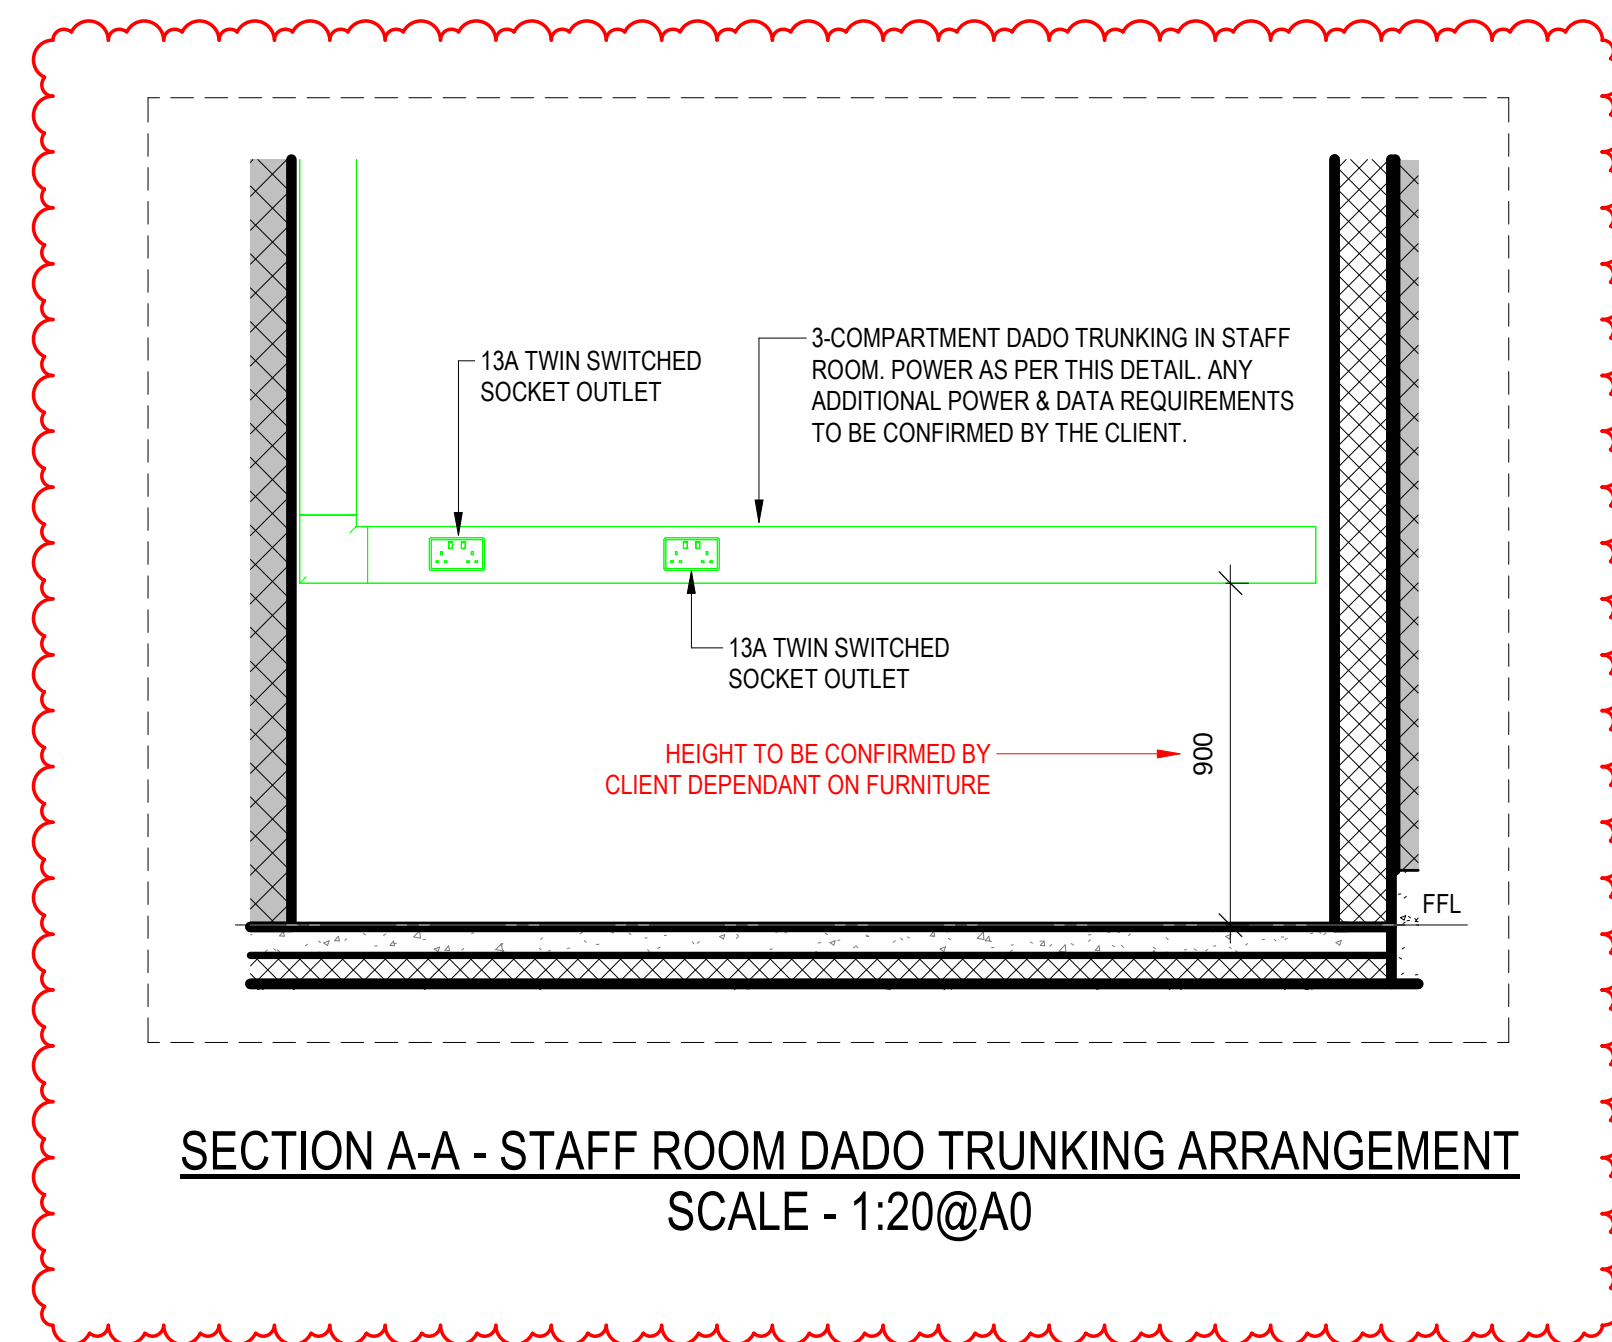

SECTION A-A - STAFF ROOM DADO TRUNKING ARRANGEMENT  
SCALE - 1:20@A0

|     |                    |    |    |            |
|-----|--------------------|----|----|------------|
| C01 | CONSTRUCTION ISSUE | JD | JM | 15/08/2025 |
| P01 | PRELIMINARY ISSUE  | JD | JM | 22/07/2025 |

| rev | description | dwn | chld | date |
|-----|-------------|-----|------|------|
|-----|-------------|-----|------|------|

Status CONSTRUCTION

Client



Architect/Proj Jon Matthews Architects



Unit 5, Cranford Drive, Knebworth, Herts SG9 6BN

0161 8200047 | mail@24-7group.co.uk | www.24-7group.co.uk

project PRESTWICH TRAVEL HUB

title  
GROUND FLOOR  
SMALL POWER & ANCILLARY  
SERVICES LAYOUT  
SHEET 2 OF 2

| project no. | drawn by | date      | checked | scale             |
|-------------|----------|-----------|---------|-------------------|
| PN01725     | JD       | JUNE 2025 | JM      | As indicated @ A0 |

drawing no. 17300-247-P1-00-D-E-620001

C01