

D&B NOTES

THIS DRAWING IS AN INDICATIVE LAYOUT ONLY, DEMONSTRATING THE CONCEPTUAL REQUIREMENTS CORRELATING WITH THE AGREED SCHEMATIC SOLUTIONS. THE PURPOSE OF THIS DRAWING IS TO DEMONSTRATE DESIGN INTENT FOR FURTHER DEVELOPMENT BY THE RELEVANT SERVICES DESIGNER ONLY.

© 2021 COUCH PERRY WILKES
All rights reserved. No part of this publication may be reproduced, stored in a retrieval system, or transmitted, in any form or by any means, electronic, mechanical, photocopying, recording, or by any information storage and retrieval system, without prior written permission from Couch Perry Wilkes.


NOTES

1. THIS DRAWING IS NOT AN INSTALLATION DRAWING.
2. SCALED DIMENSIONS SHALL NOT BE TAKEN FROM THIS DRAWING.
3. THIS DRAWING SHALL BE READ IN CONJUNCTION WITH ALL RELEVANT REPORTS, SPECIFICATIONS, ARCHITECTURAL AND ENGINEERING DRAWINGS.
4. THIS DRAWING IS FOR TENDER PURPOSES ONLY. DETAILED DESIGN AND INSTALLATION DRAWINGS SHALL BE PROVIDED BY THE CONTRACTOR IN ACCORDANCE WITH THE SPECIFICATION.
5. THE CONTRACTOR SHALL BE DEEMED TO HAVE INCLUDED FOR ALL ITEMS OF EQUIPMENT INCLUDING MANUFACTURER AND TYPE AS DETAILED ON THIS DRAWING AND WITHIN THE SPECIFICATION.
6. THE CONTRACTOR SHALL BE RESPONSIBLE FOR THE CORRECT AND FINAL POSITIONING OF ALL OUTLETS TO MEET THE END-USER REQUIREMENTS. THIS SHALL BE CARRIED OUT IN CONJUNCTION WITH THE PROJECT ARCHITECT. FINAL SETTING OUT EQUIPMENT SHALL BE TO THE ARCHITECT'S ROOM LAYOUT AND REFLECTED CEILING PLANS.
7. THE CONTRACTOR SHALL CO-ORDINATE ALL ELECTRICAL SERVICES WITH MECHANICAL SERVICES AND STRUCTURE.
8. ALL POWER SUPPLIES TO SPECIALIST SYSTEMS INCLUDING SECURITY, CALL SYSTEMS, EMERGENCY LIGHTING, FIRE ALARM, I.T., ETC ARE TO BE PROVIDED AS REQUIRED. THE CONTRACTOR SHALL Liaise WITH ALL SPECIALISTS TO ENSURE THAT THEIR POWER REQUIREMENTS ARE PROVIDED.
9. THE CONTRACTOR SHALL EMPLOY A REPRESENTATIVE OF THE SYSTEM MANUFACTURER TO TEST AND COMMISSION EACH SYSTEM UPON COMPLETION OF EACH PHASE OF WORKS.
10. THE CONTRACTOR SHALL PROVIDE A GRADE 2 INTRUDER ALARM SYSTEM ZONED AS PER THE FIRE ALARM ALLOWING FOR ISOLATION OF INDIVIDUAL AREAS OF THE BUILDING.

Legend

- Intruder Alarm Zone 1
- Intruder Alarm Zone 2
- Intruder Alarm Zone 3
- Intruder Alarm Zone 4
- Intruder Alarm Zone 5

- ACCESS CONTROL PANEL
- MAGNETIC LOCK
- MAGNETIC SHUNT LOCK
- CARD READER C/W KEYSWITCH OVERRIDE BENEATH
- SECURITY KEY OVERRIDE SWITCH
- INTRUDER ALARM PANEL
- AUDIO INTERCOM PANEL
- WALL MOUNTED FIXED 'DOME TYPE' CCTV CAMERA
- CEILING MOUNTED FIXED 'DOME TYPE' CCTV CAMERA

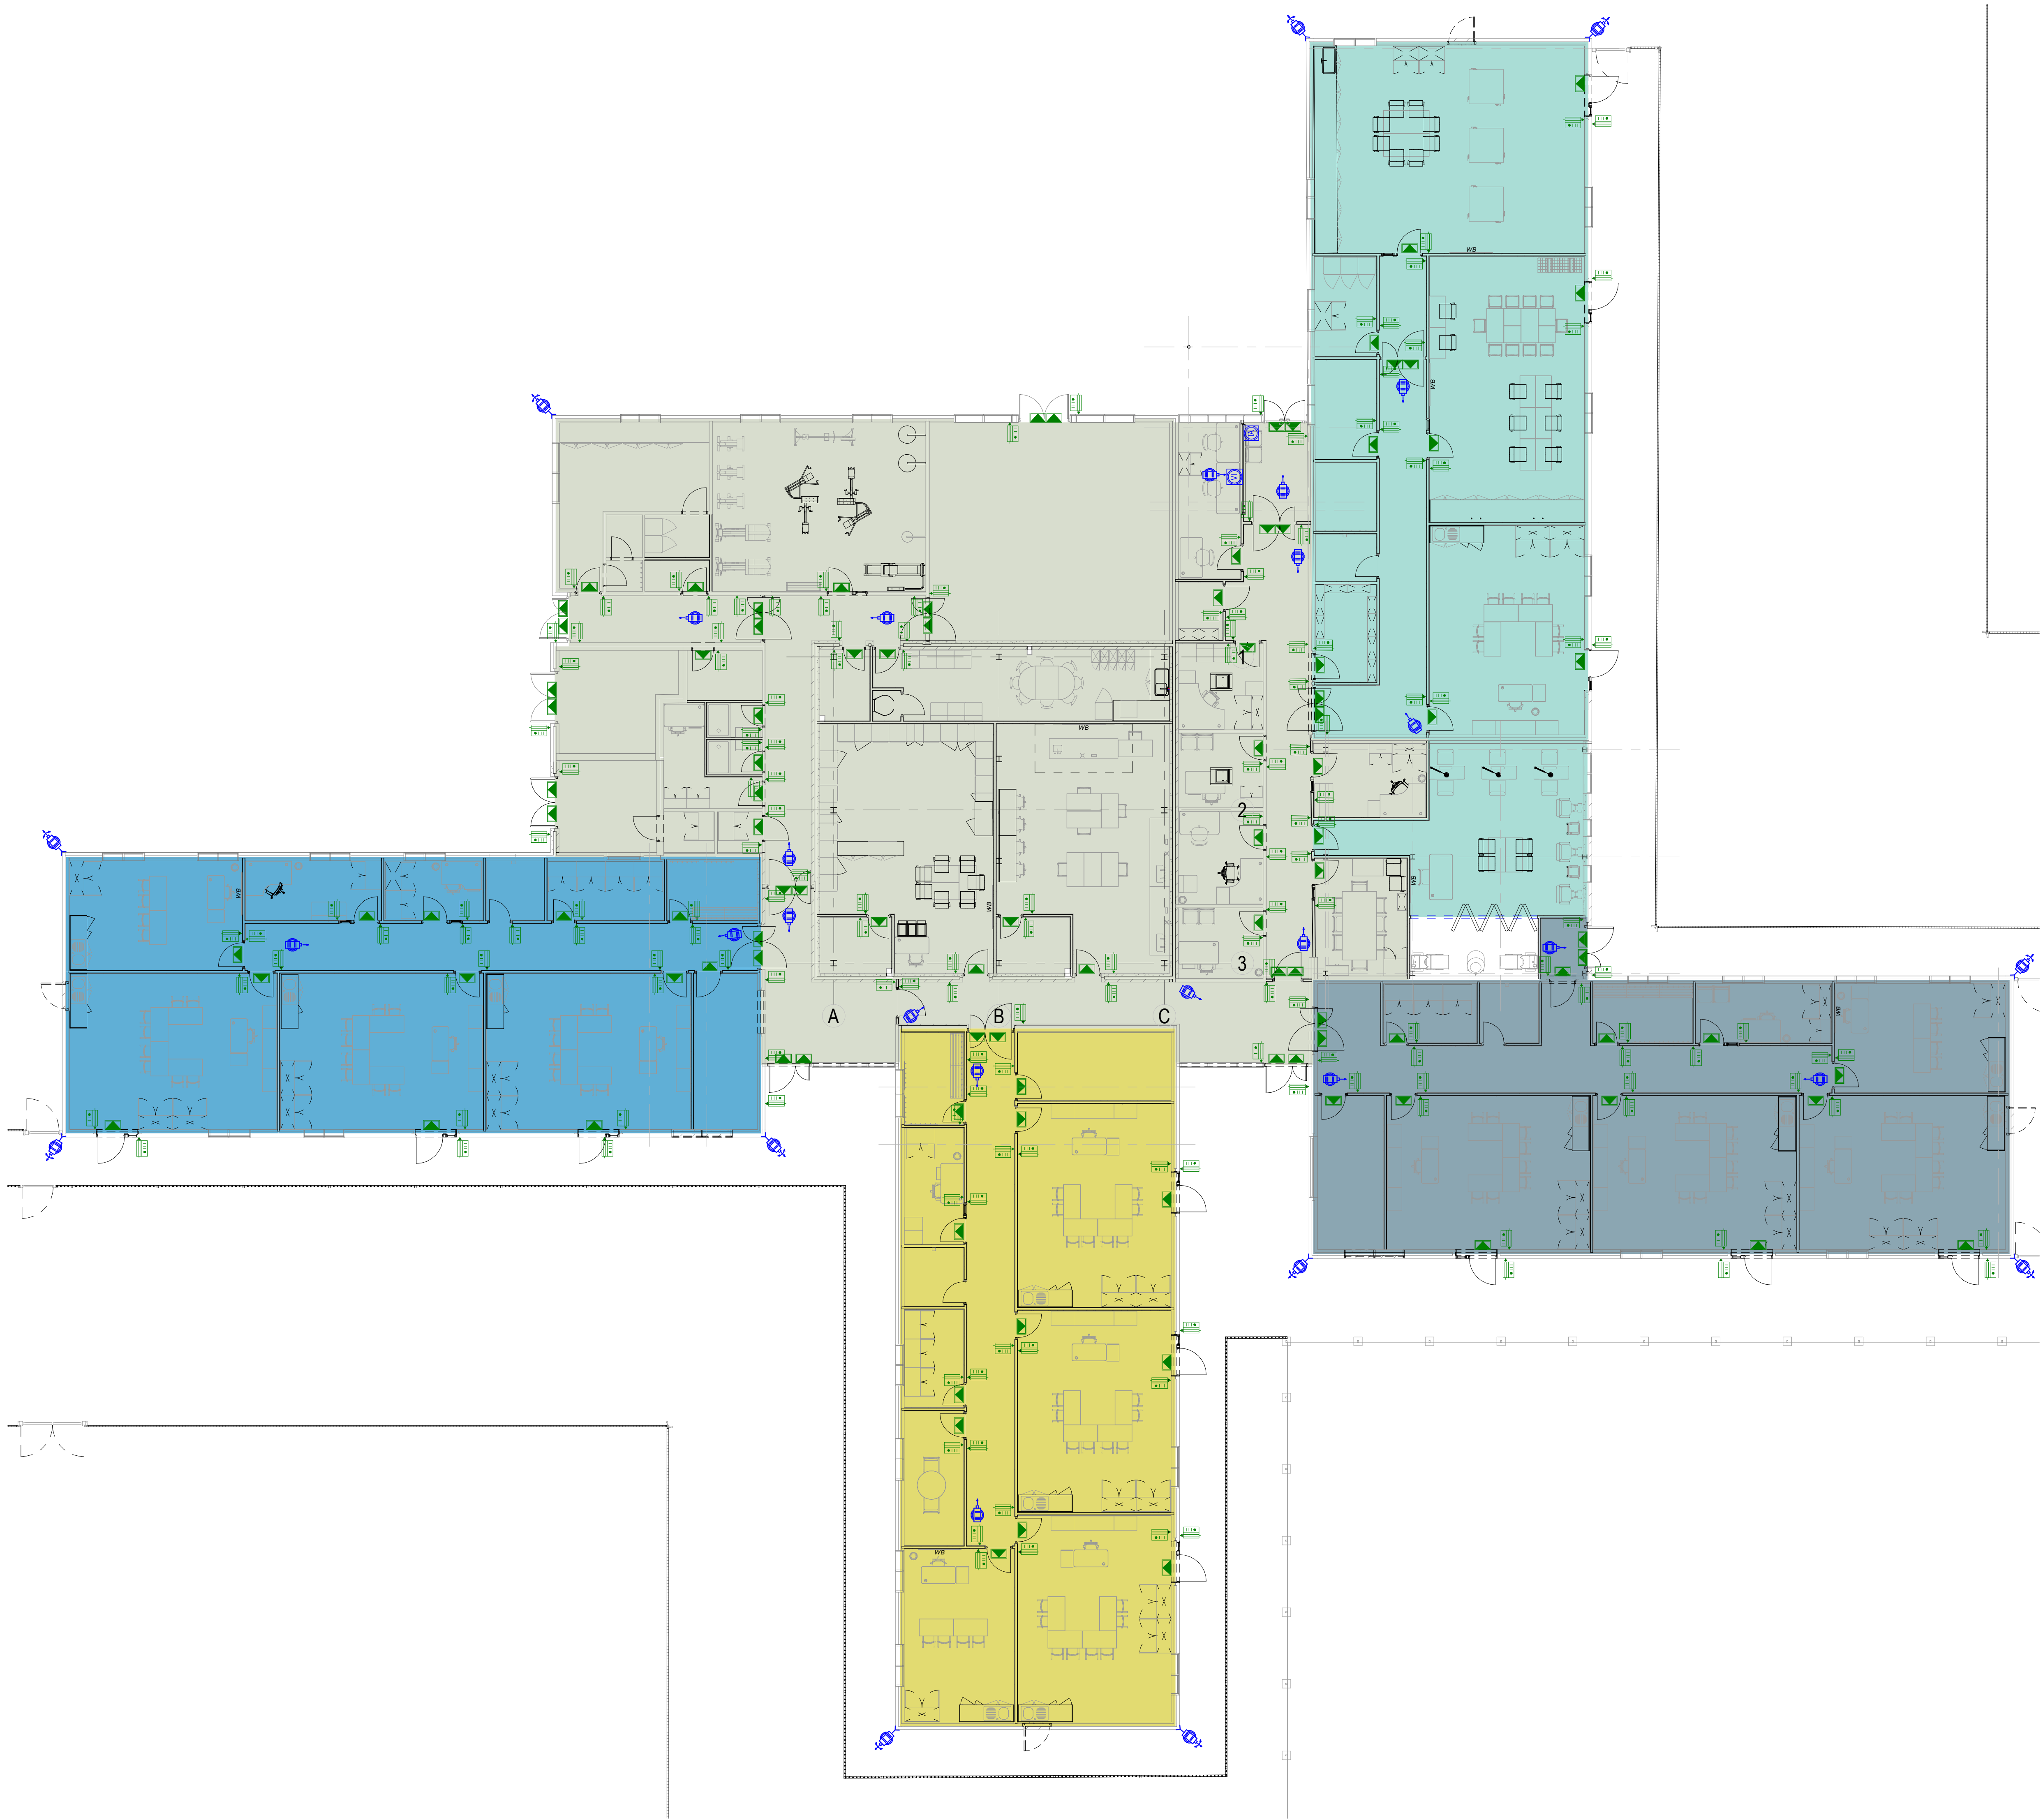

DATE	09/09/2022	STAGE	TENDER ISSUE	BY	JA	DATE	09/09/2022
REV	01	BY	CPW	DATE	09/09/2022	REV	01

www.cpwgroup.com

STUDIO
Studio 25-26
40 The Cattle Leazes
LS2 7EY

Phone
+44 (0) 113 247 0709
hello@cpwgroup.com

RIBA STAGE

STAGE 3

STATUS

TENDER ISSUE

CLIENT

BURY COUNCIL

PROJECT

SPURR HOUSE

DRAWING TITLE

SECURITY SERVICES PHILOSOPHY

SCALE (A0)	DATE	BY	VT
1:100	09/09/2022	JA	DJ

220244	CPW	XX	XX	DR	E	50001	53	P01
--------	-----	----	----	----	---	-------	----	-----

220244-CPW-XX-XX-DR-E-50001 53 P01

CPW Project No. 220244

LINKED FILES

Spring lane model