


Ⓢⓓ = Interlinked, mains wired (with battery back up) smoke detector positions.

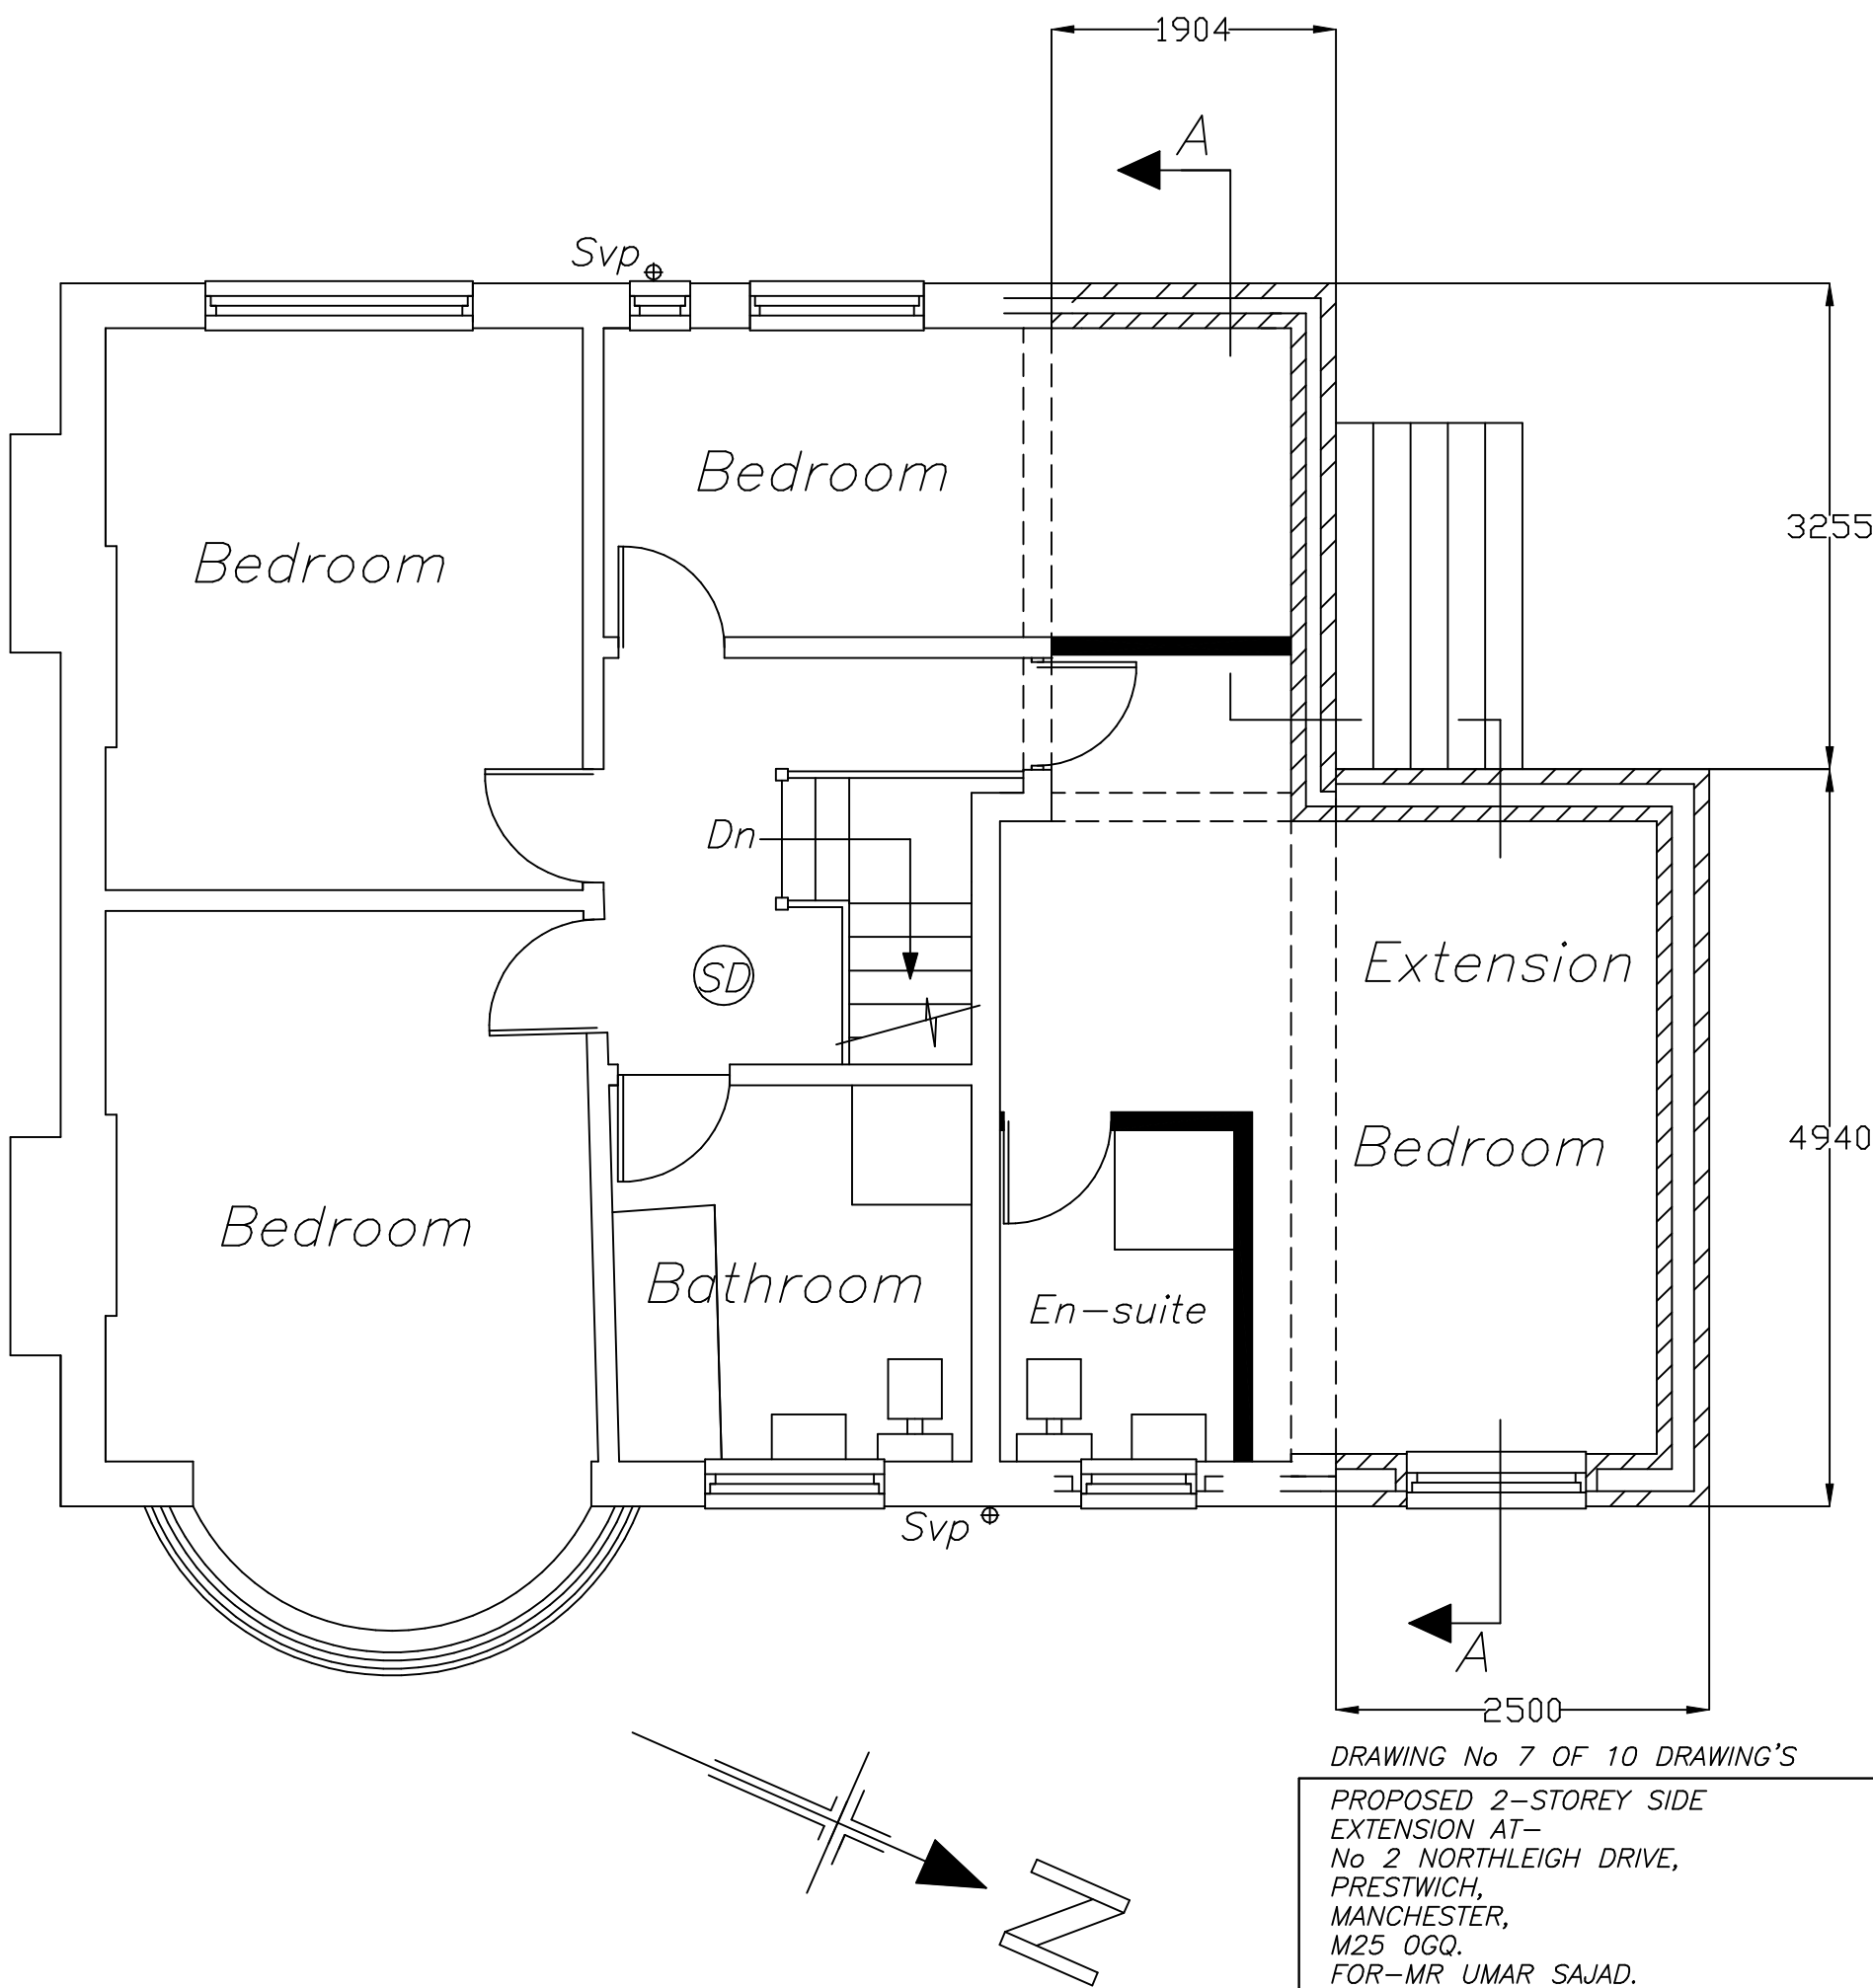

DRAWING No 7 OF 10 DRAWING'S

PROPOSED 2-STOREY SIDE
EXTENSION AT-
No 2 NORTHLEIGH DRIVE,
PRESTWICH,
MANCHESTER,
M25 0GQ.
FOR-MR UMAR SAJAD.

SCALE:- 1:50 DATE:- DEC 2023

PROPOSED FIRST FLOOR PLAN

kevin foey

BUILDING
DESIGN CONSULTANTS

28 CHEW VALE,
GREENFIELD,
OLDHAM, OL3 7EQ.
TEL- 0798 676 1559