


Legend	
Key	Description
	Primary supply air ductwork
	Extract air ductwork
	Dirty extract air ductwork
	Attenuator
	Supply air grille
	Extract air grille
	Return air grille
	Flexible ductwork
	Volume control damper
	Fire damper
	Ceiling concealed ducted indoor unit

- Notes**
1. All ductwork runs and diffuser positions must be checked and set out against a fully detailed ceiling layout, structural engineering and electrical services drawings. All dimensions must be checked out on site prior to the installation being executed. The contractor will be expected to co-ordinate the ductwork with all other trades.
 2. All ductwork shall be manufactured, installed, tested and commissioned in strict accordance with DW144 and CIBSE commissioning codes.
 3. Access doors shall be provided adjacent all fire dampers, volume control dampers and at least 9m intervals on ductwork routes to allow future maintenance/cleaning of ductwork.
 4. All ductwork to be identified in accordance with BS: 1710.
 5. All VCDs are to be located above lay in ceiling grids for future access.
 6. Volume control dampers to be installed on all ductwork branches.
 7. Fresh air ductwork to terminate 300mm from rear of VRF units.
 8. Final connections to grilles/diffusers to be in flexible ductwork - 500mm long maximum.
 9. Fire and fire/smoke dampers are not shown on this drawing. Final fire compartmentation drawings to be checked to confirm locations of fire dampers & fire / smoke dampers required.
 10. The output capacities & sizes of plant, equipment & main distribution systems indicated on this drawing are provided to demonstrate spatial allocation only. All capacities & sizes must be determined & confirmed during
 11. the Contractor's Stage 4 Technical Design.

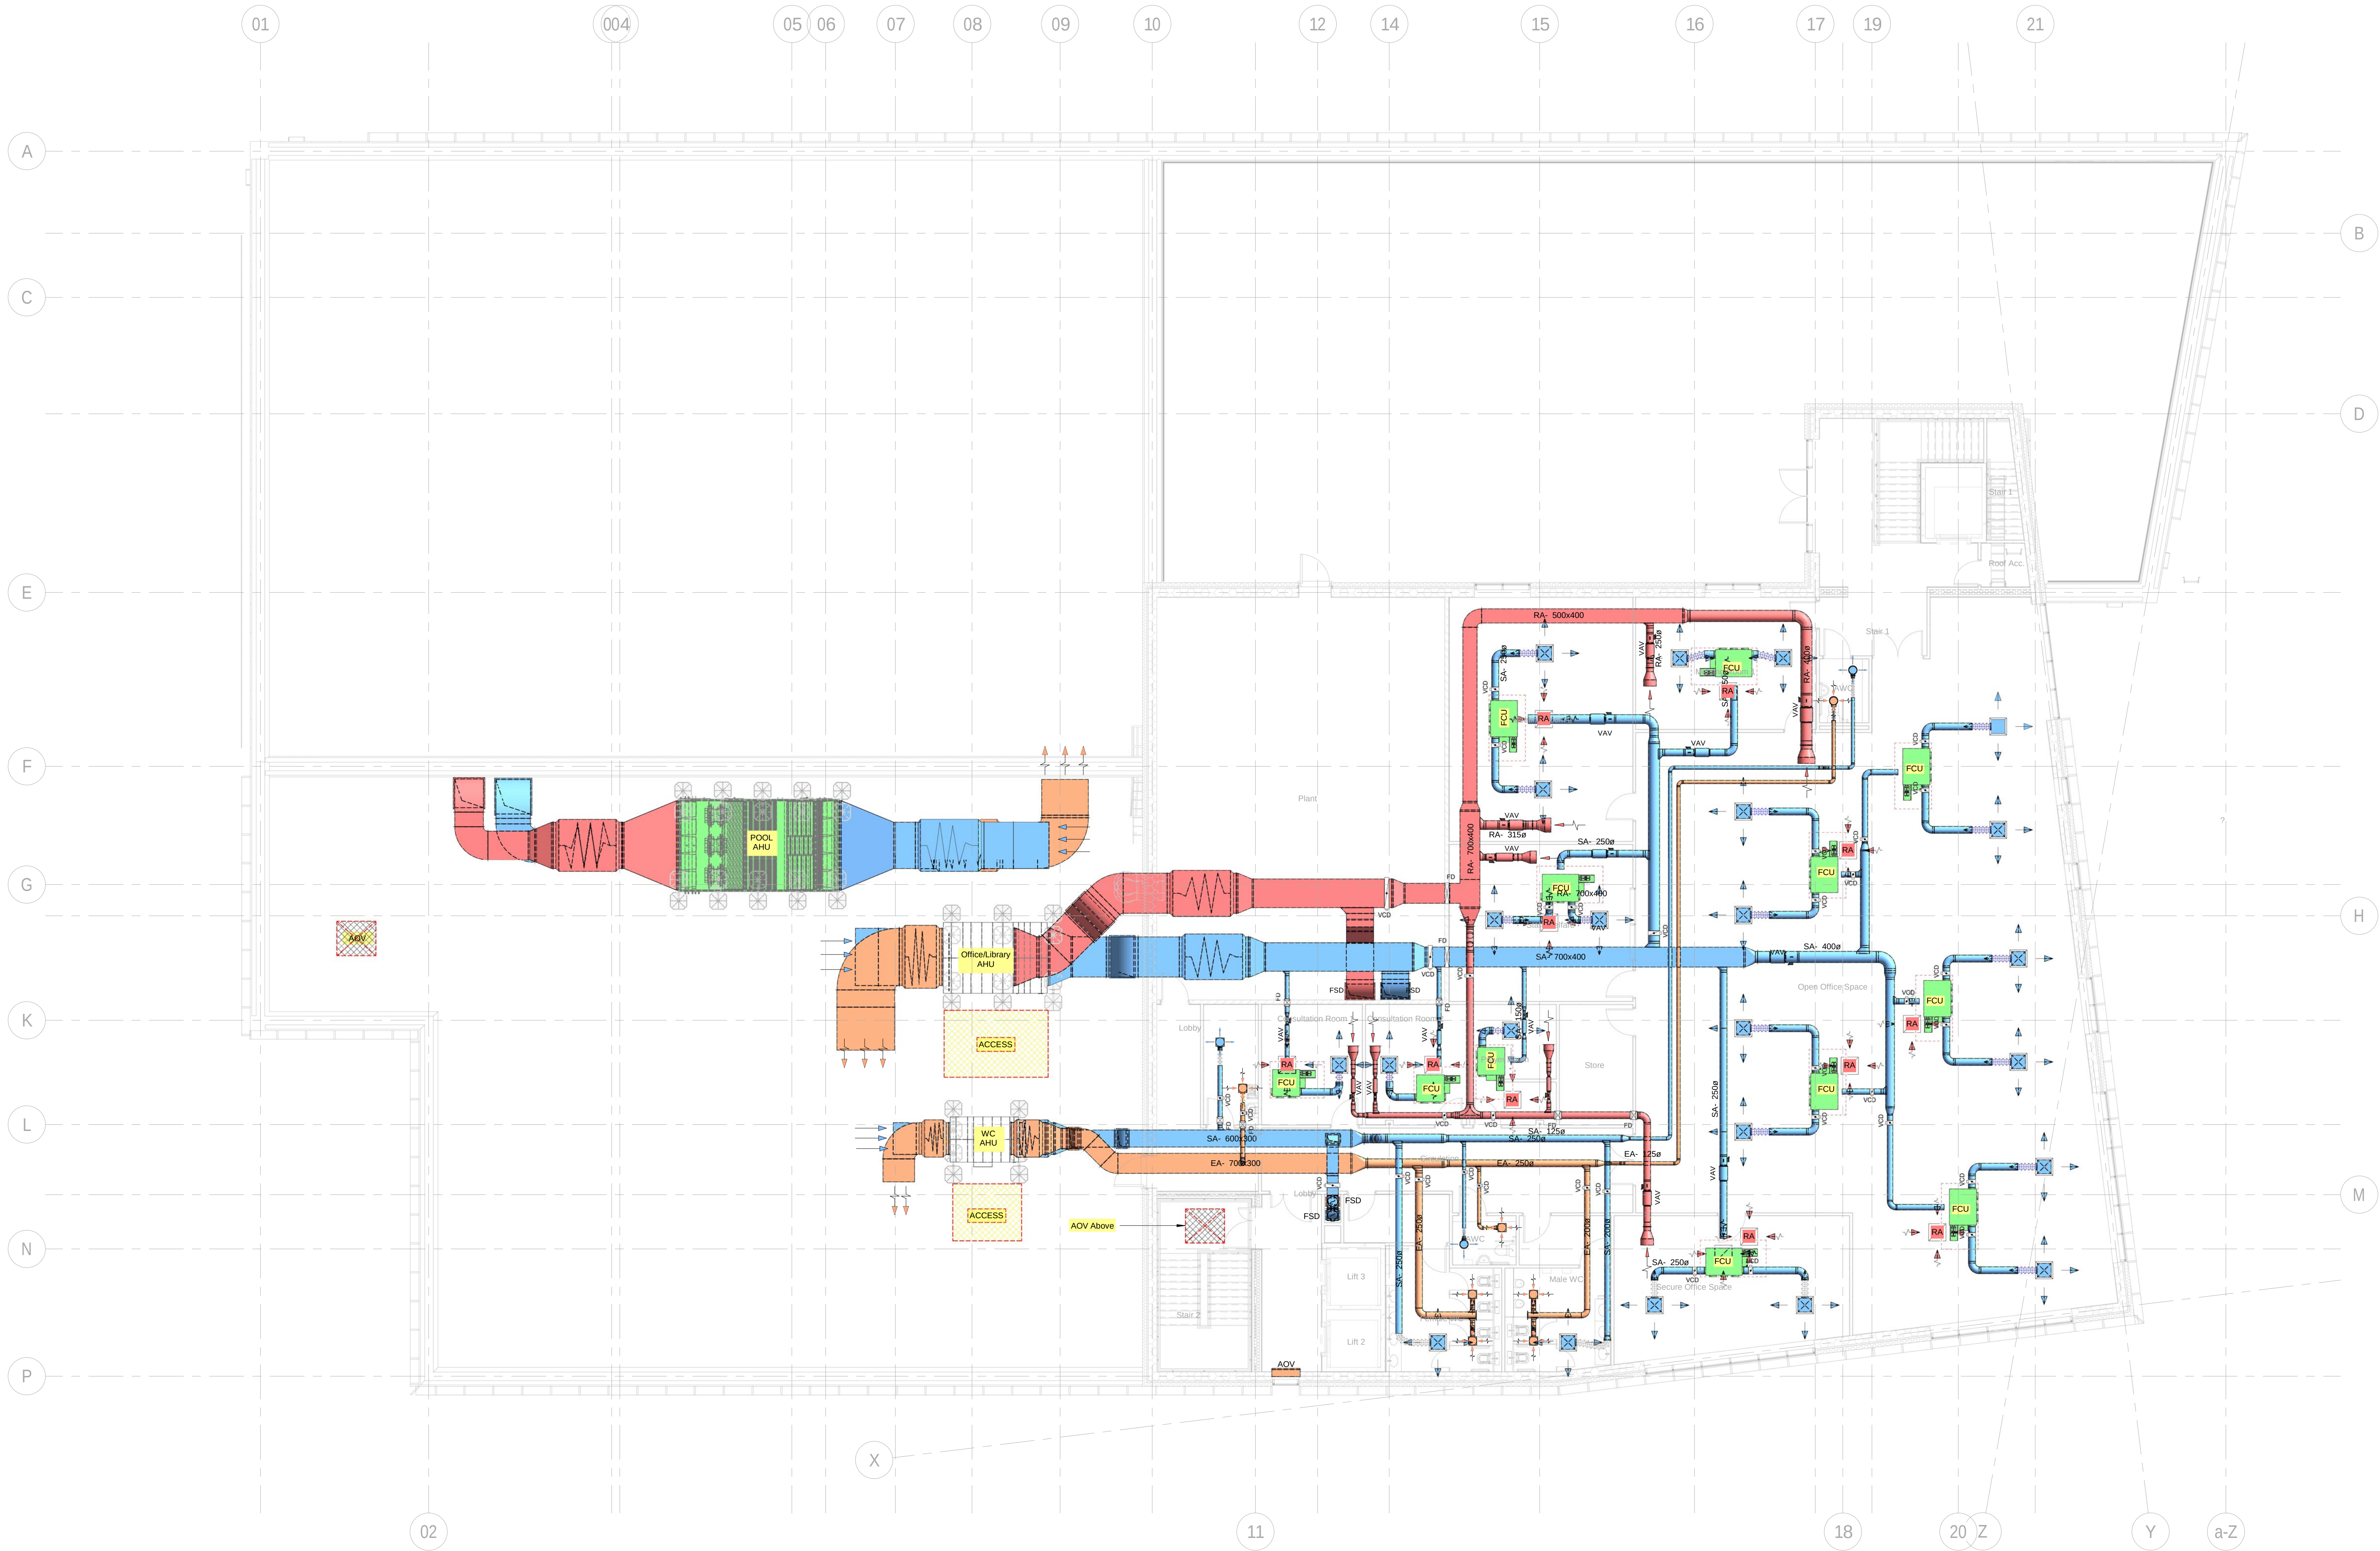

P3 27.02.23	For Information - Stage 3 update	AC	JC
P2 21.10.22	For Information - Stage 3 update	AC	JC
P1 19.08.22	For Information	AC	JC
Rev	Date	Description	Drawn / Checked
			
Hannan Associates MEP Design Solutions		Hannan Associates Ltd Belle House, Altrincham Drive Manchester Road, Denton M20 5SH Tel: +44 (0)161 337 2200 Email: info@hannan-uk.com Web: www.hannan-uk.com	
Client: VINCI Construction UK			
Project: New Civic Building - Radcliffe Hub			
Design Stage: Design Stage 3			
Drawing Title: Second Floor Notional Ventilation Layout			
Scale: As indicated	Page Size: A0L		
Status: For Information			
Project: RADHUB-HAN-V4	Originator: Volume	Level: 02-DR-M-5712	Drawn / Checked
This drawing is the property of Hannan Associates. It must not be copied or used in any form without the written consent of Hannan Associates, and must be returned upon request.			
Viewpoint Status: S4 Viewpoint Status: S4			