



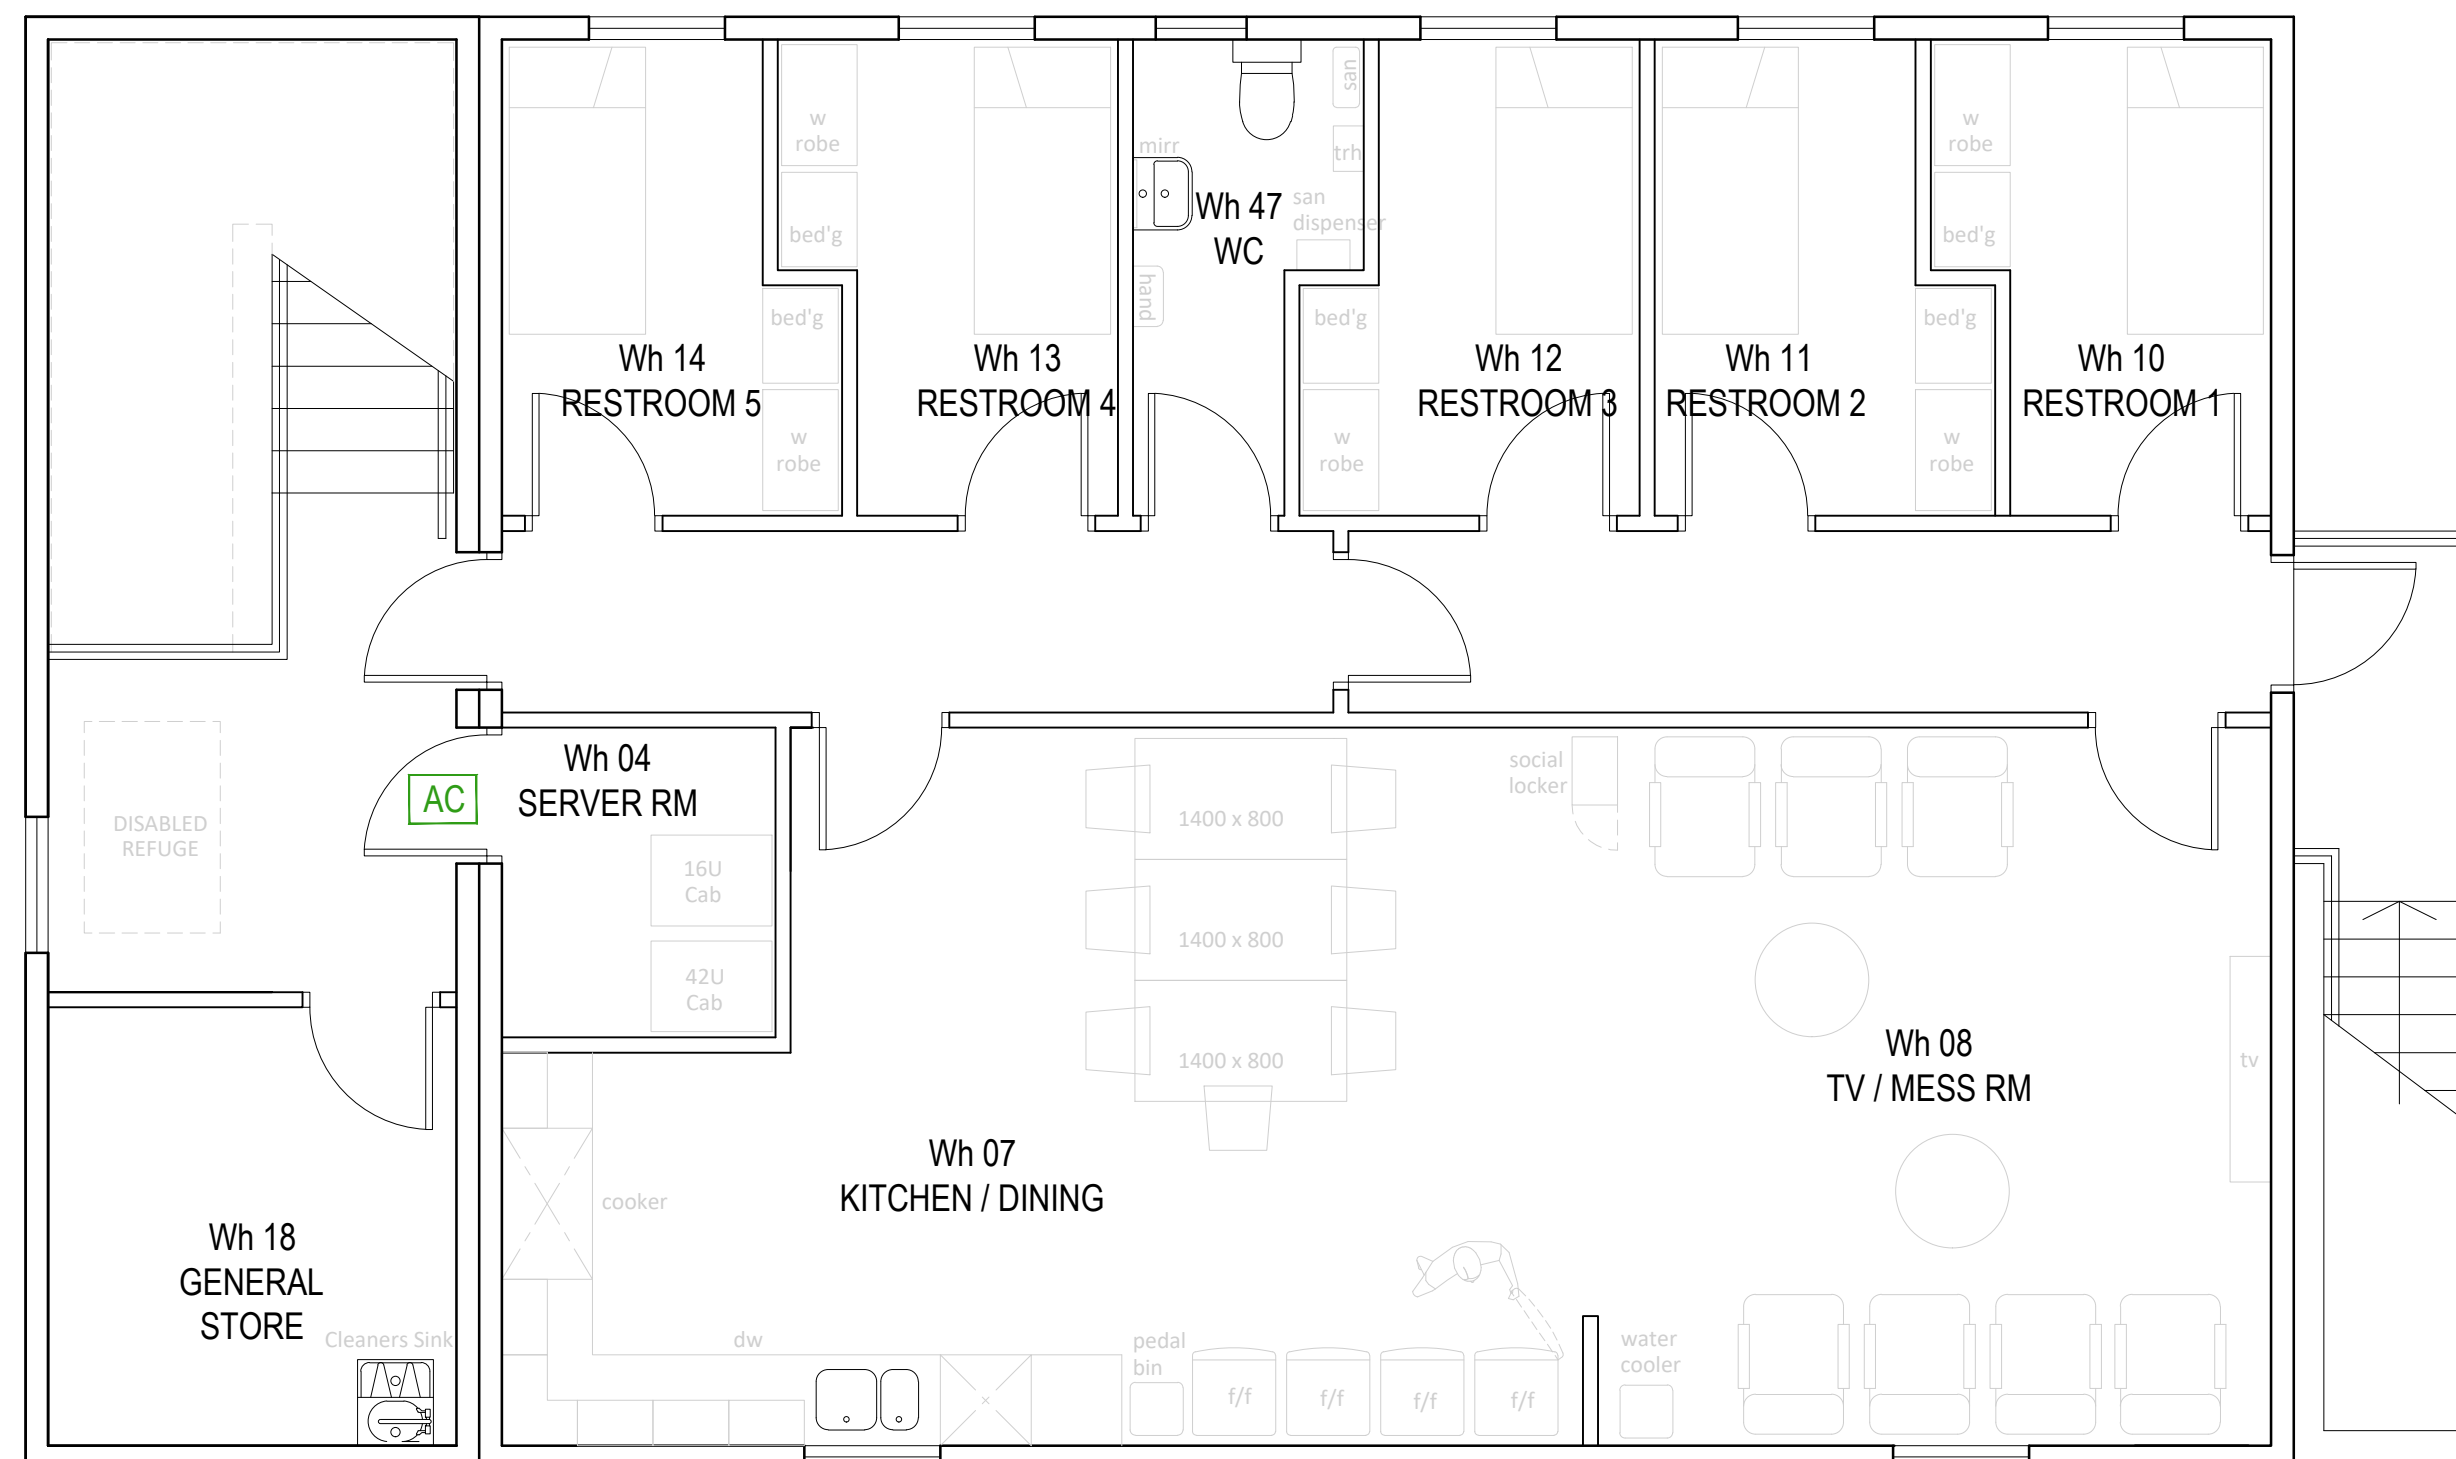

LEVEL 1

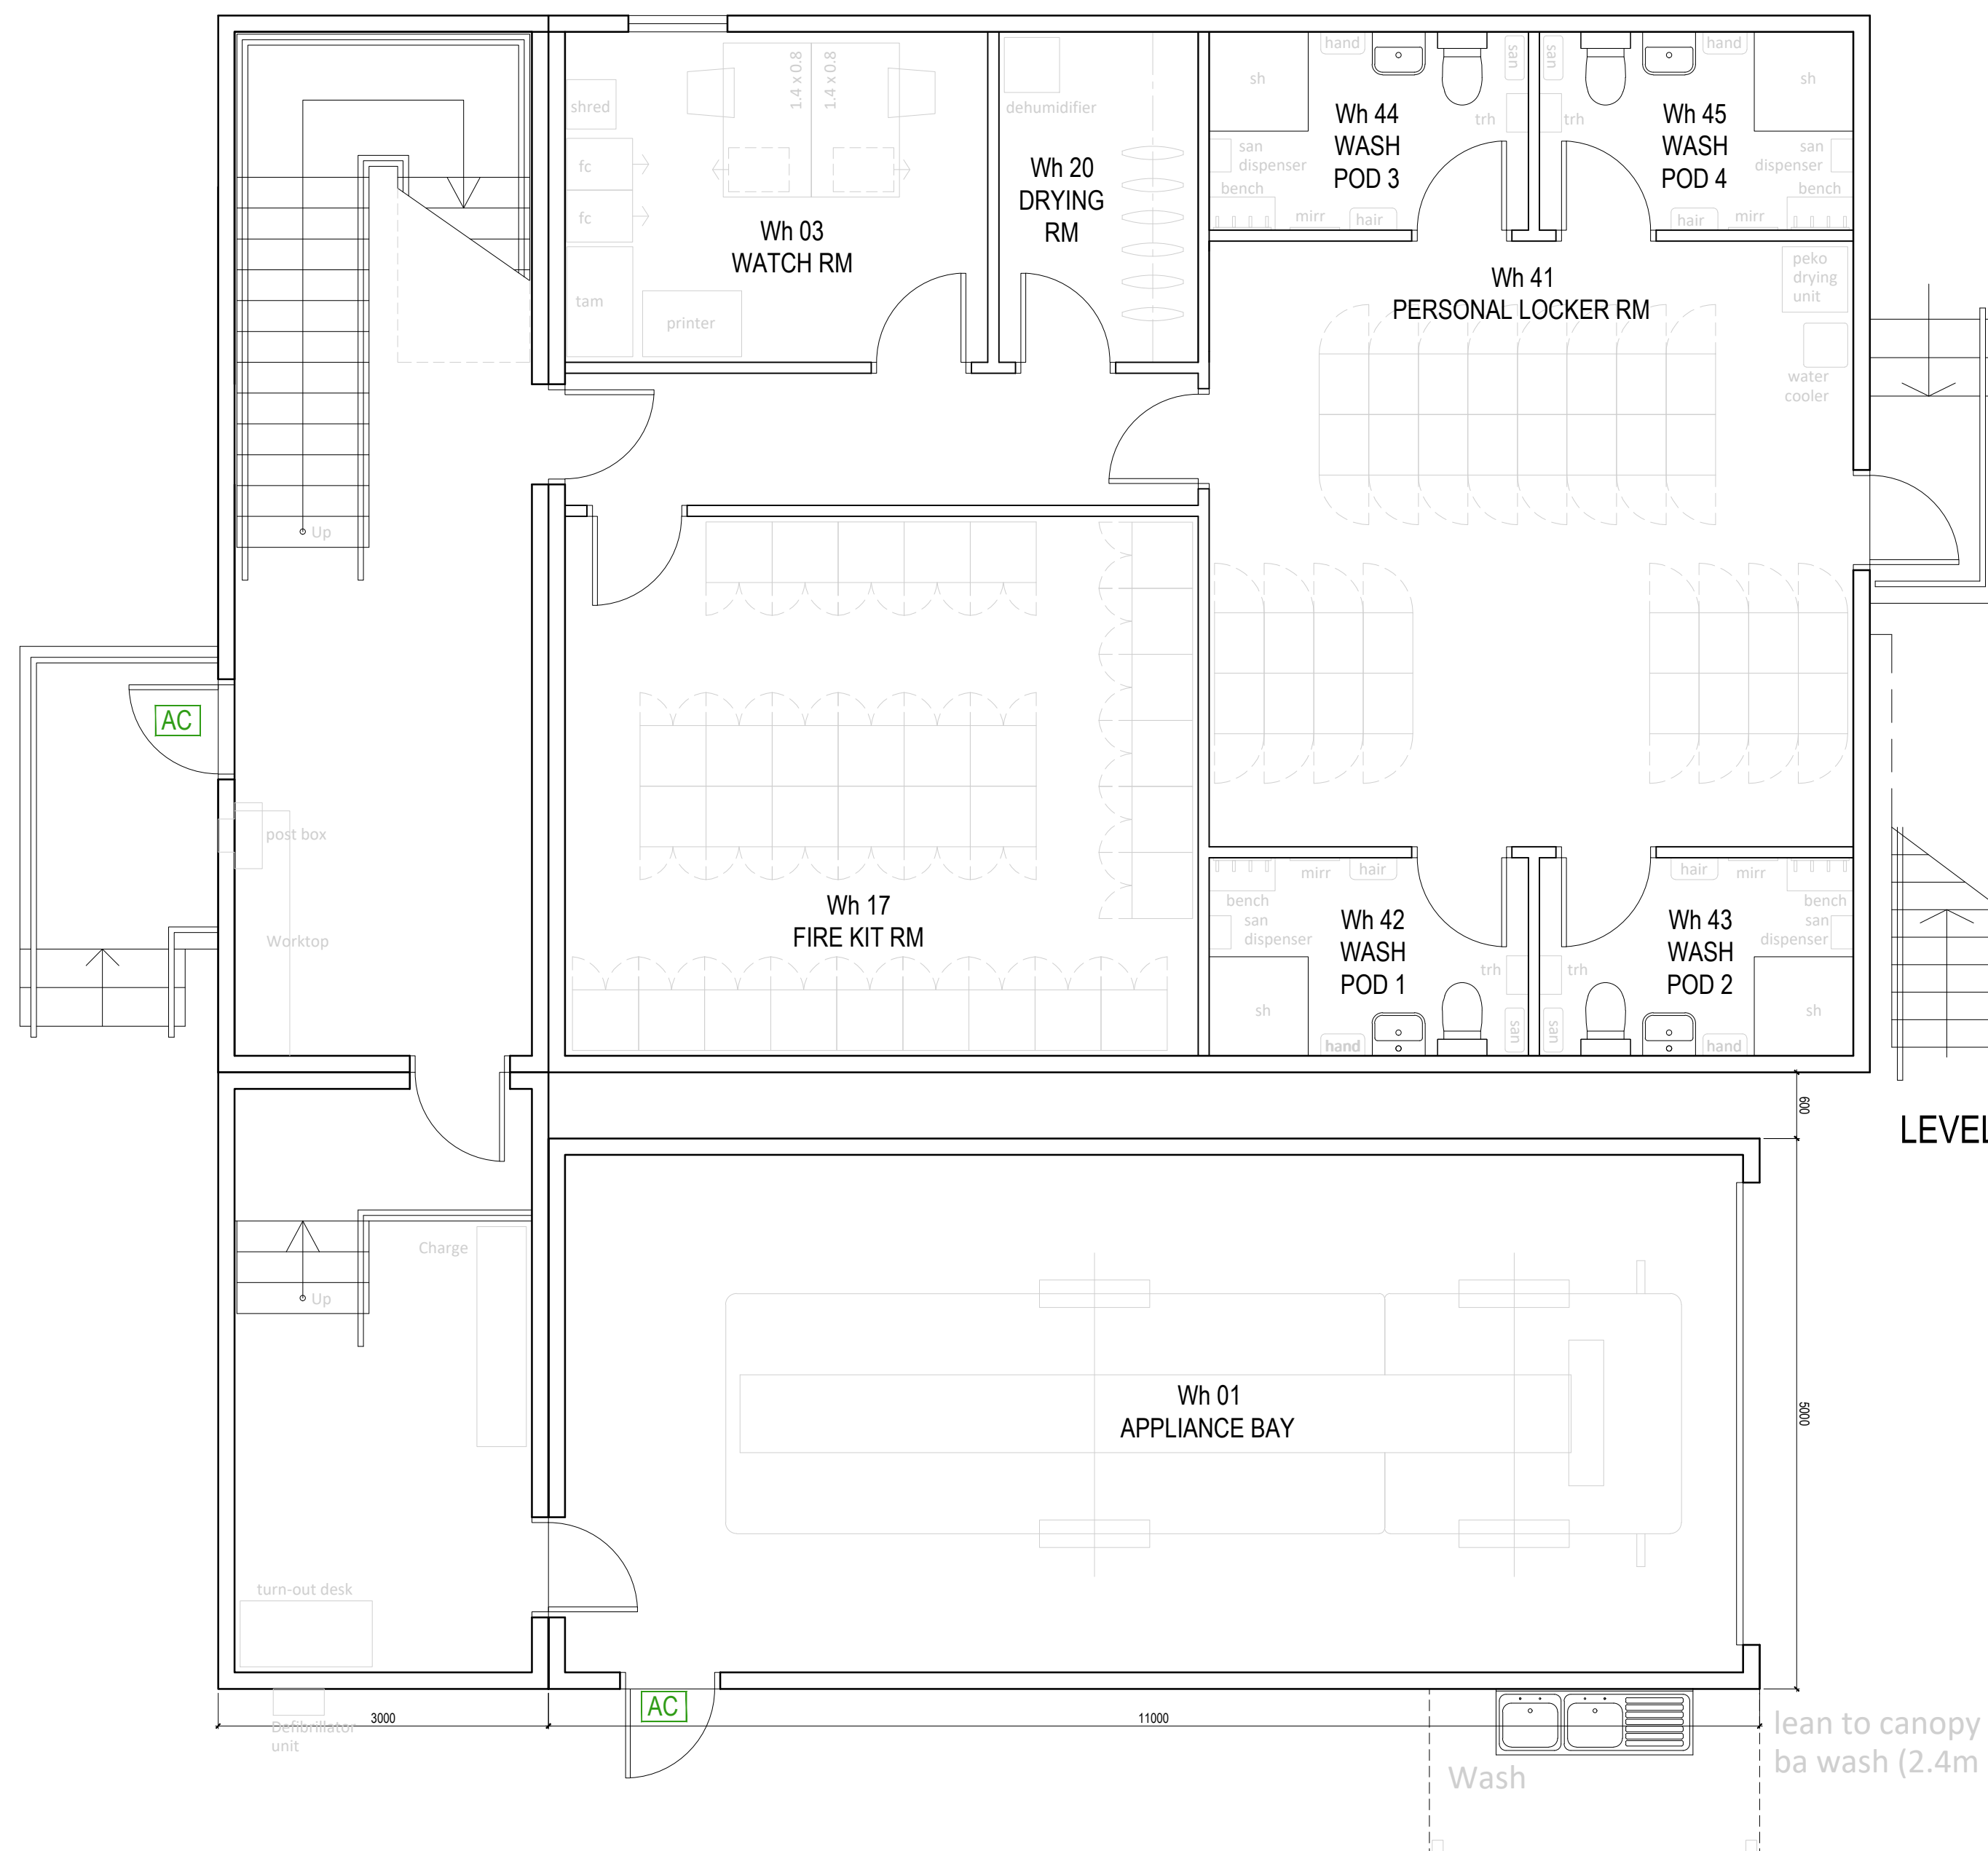

LEVEL 0

[illegible]


Architects
Consulting Engineers
Quantity Surveyors

Bradshaw Gass & Hope LLP

client
ISG CONSTRUCTION LTD

project

WHITEFIELD FIRE STATION

PROPOSED FLOOR PLANS

TEMPORARY FIRE STATION

drawn by	ST	date	AUG 23
checked by		date	

scale	1:50	A1
-------	------	----

dwg no WFS-BGH-02-ZZ-DR-A-0301	rev P8
--	------------------