

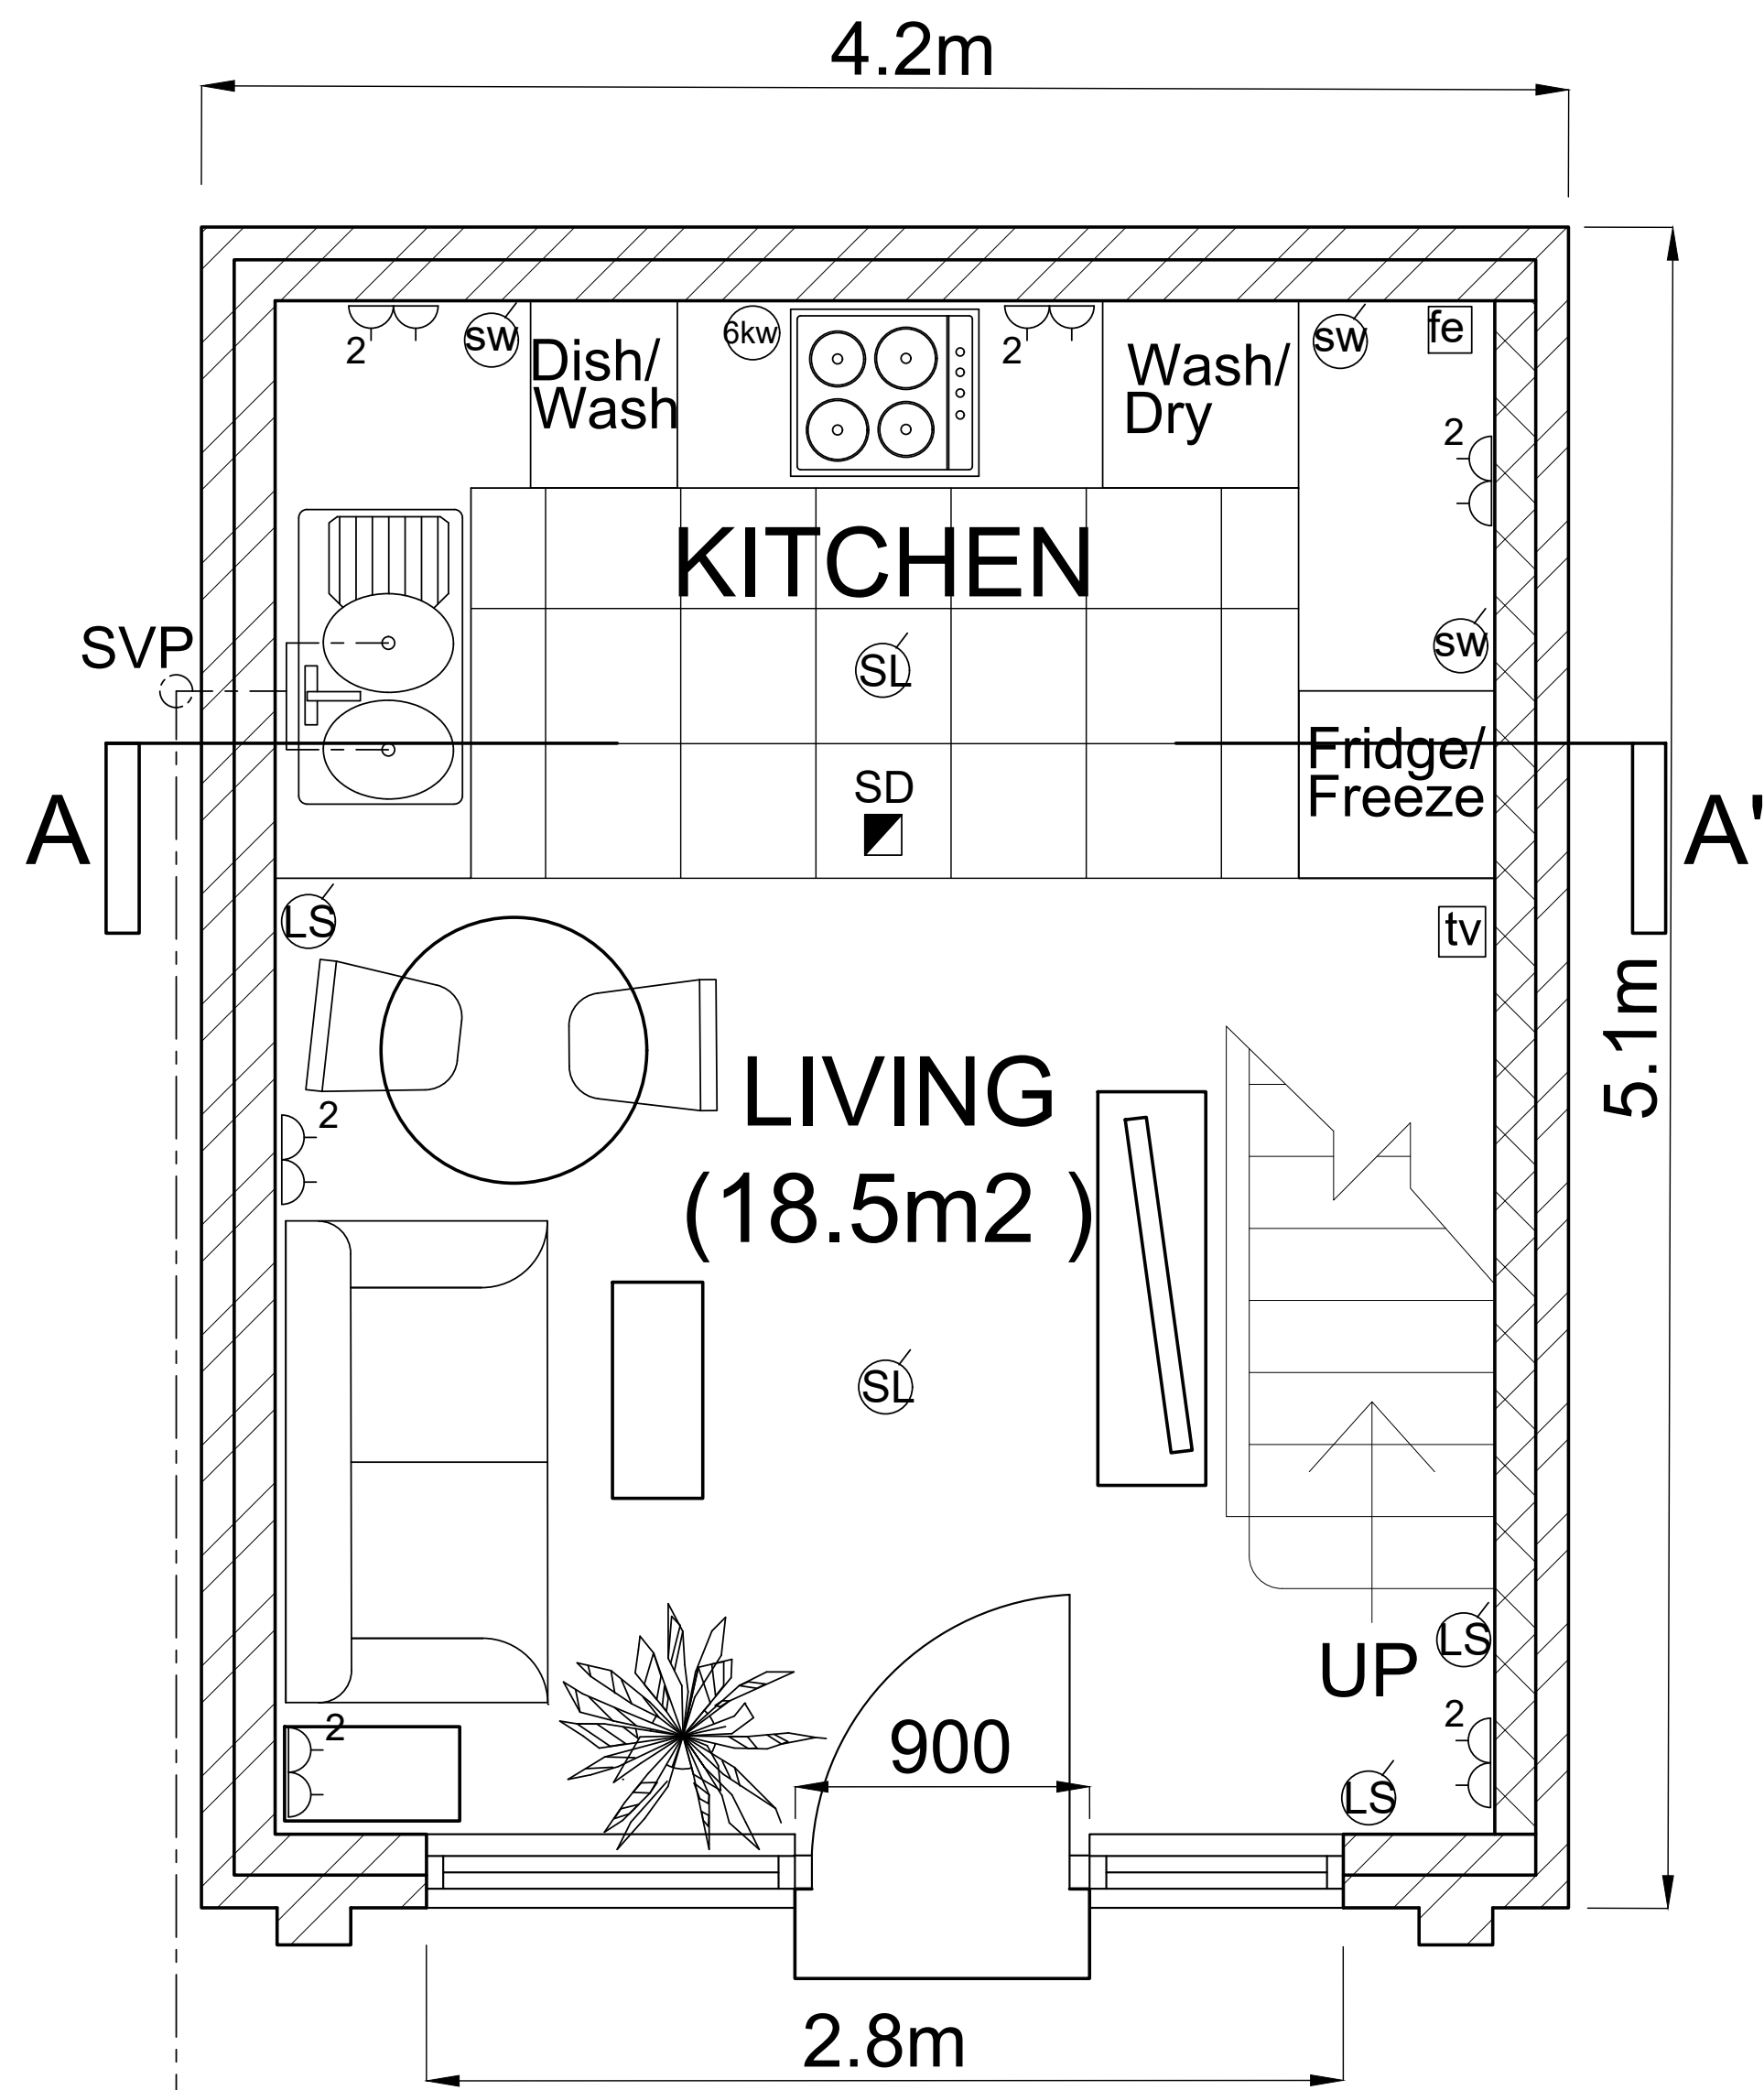


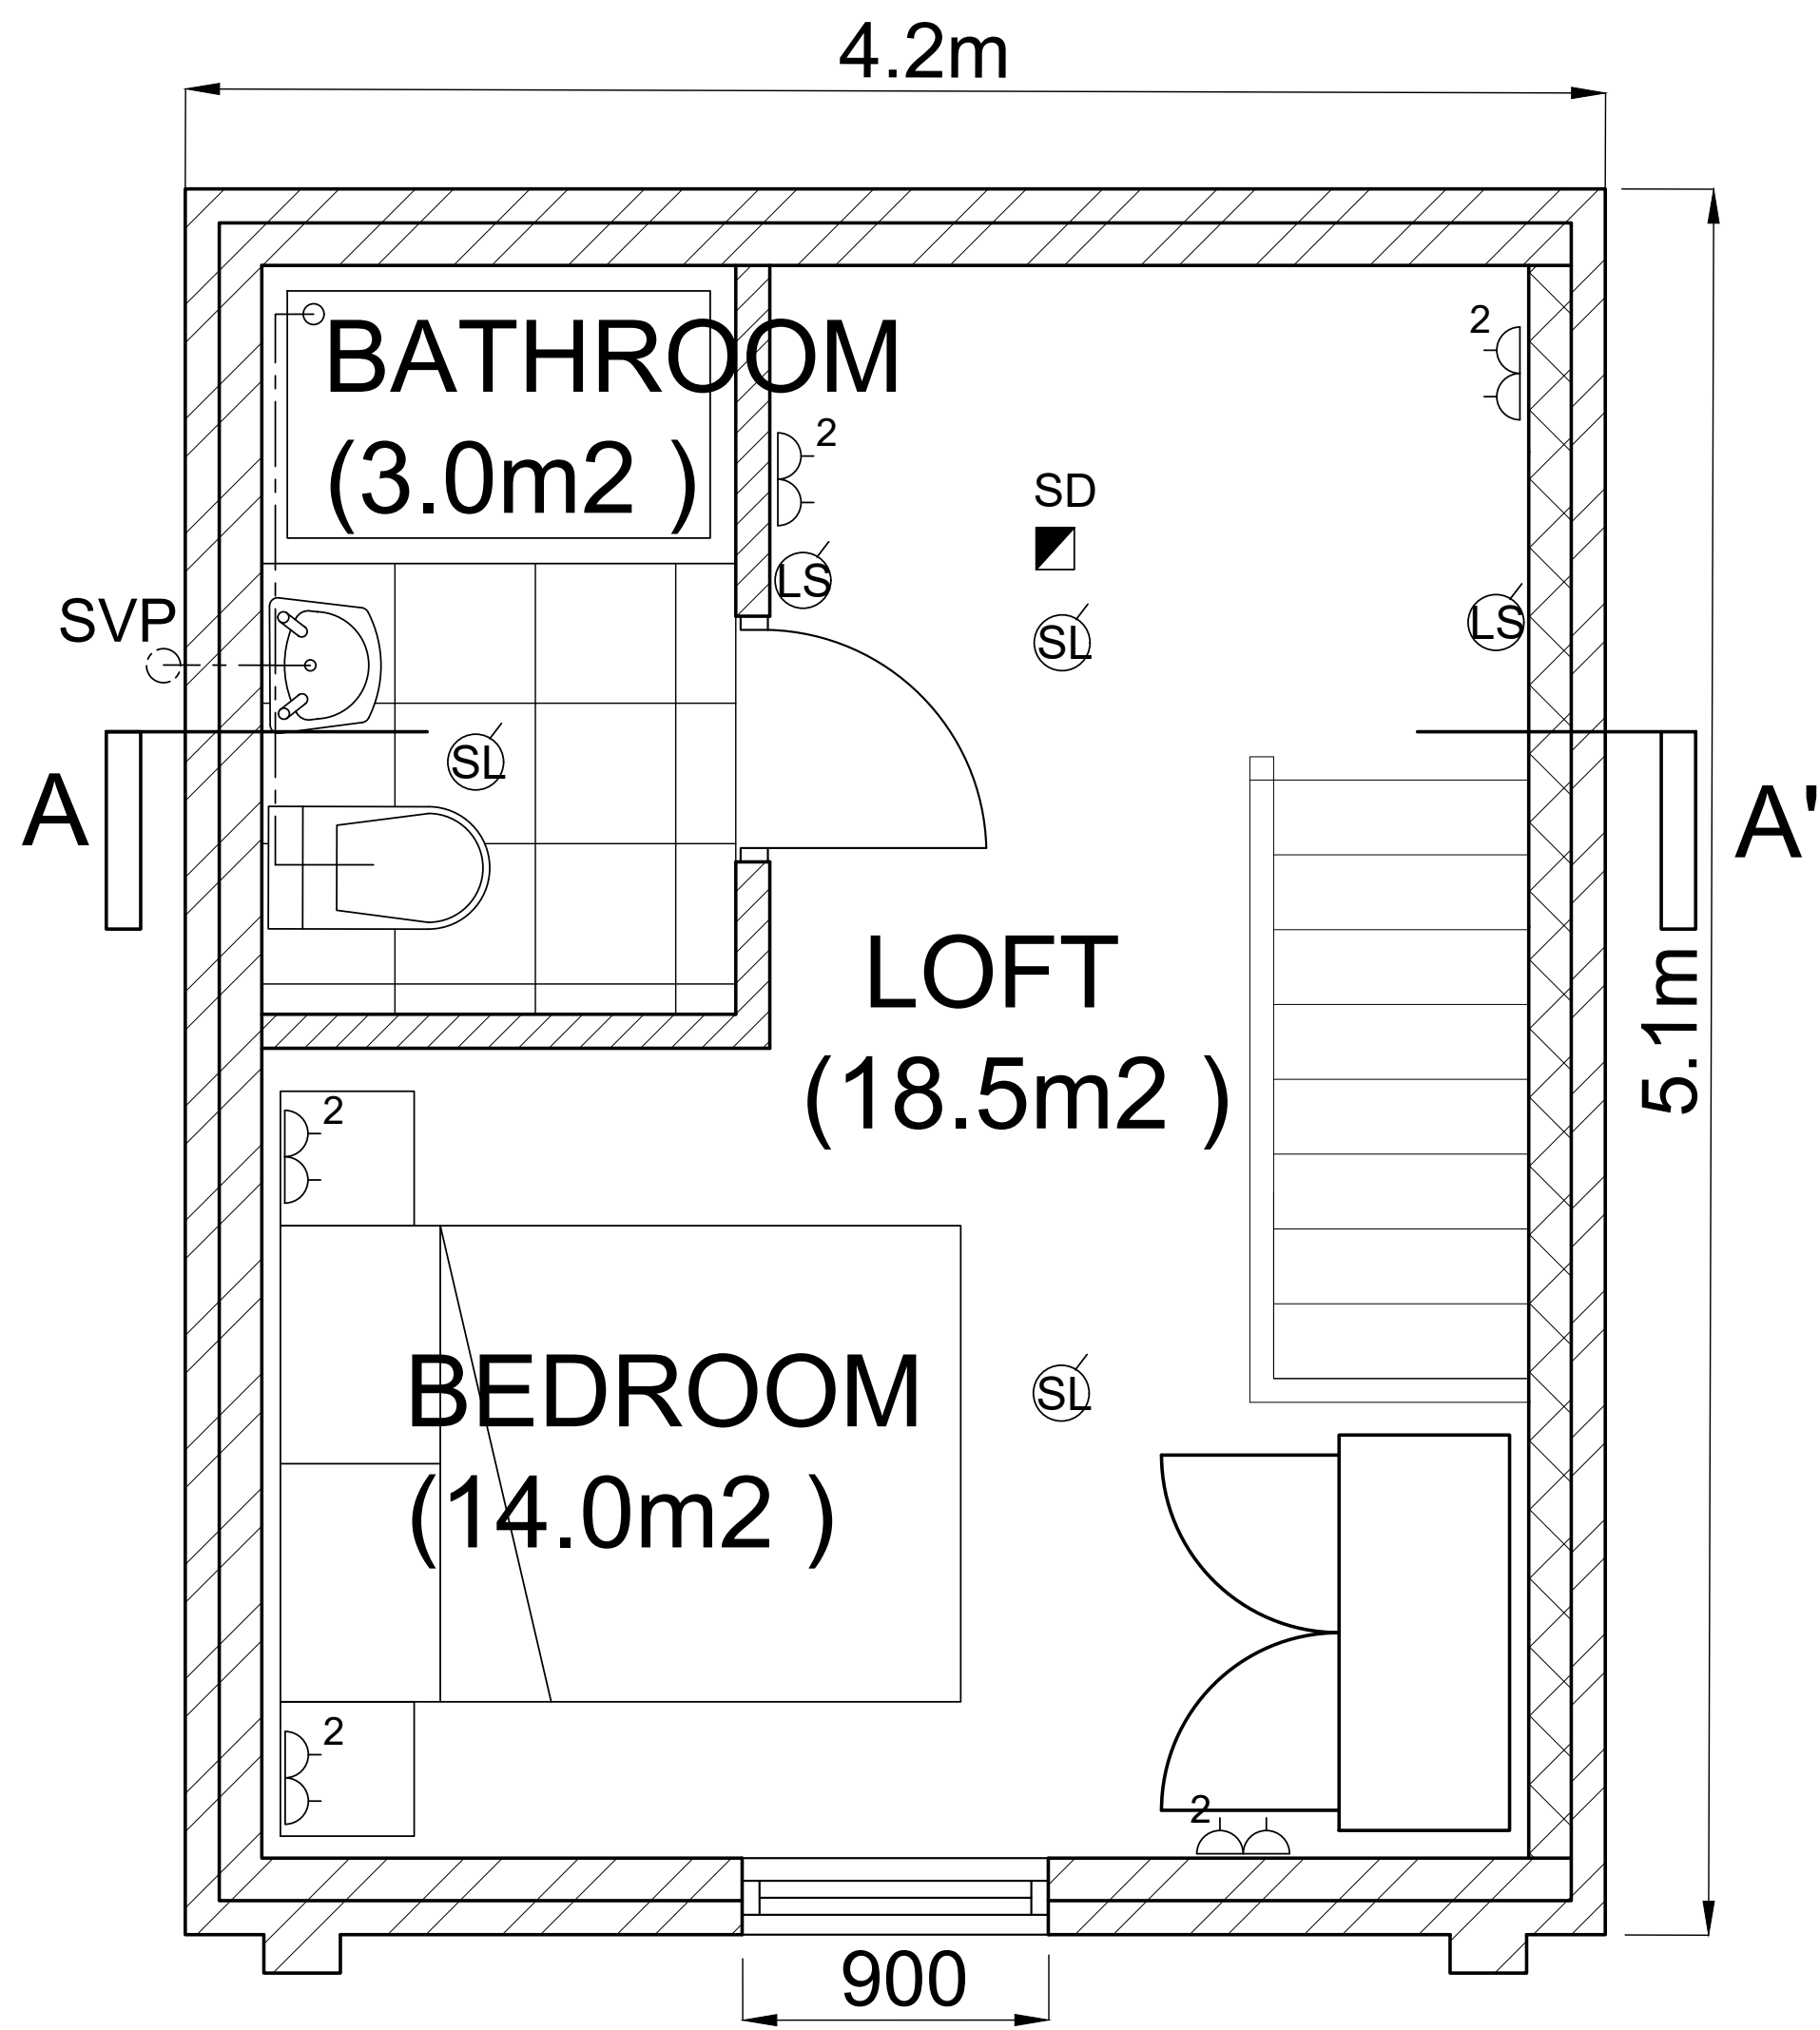

GROUND FLOOR PLAN

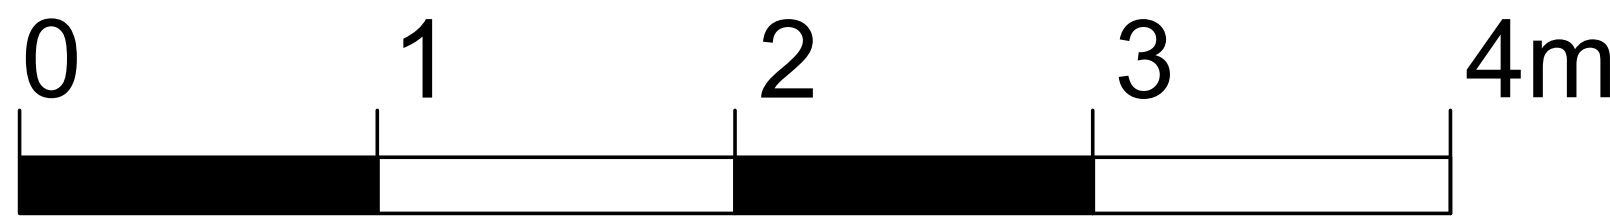


FIRST FLOOR PLAN

KEY TO SYMBOLS

- 6kw 6kw oven supply
- 13 amp double socket
- SW electrical switch over worktop with concealed socket under
- LS Lightswitch
- WL Exterior wall mounted LED movement sensor operated light
- SL Surface mounted LED downlight
- LED batten light under wall unit
- sh Shaving Point

- Wash hand basin in vanity unit with LED down lighter over back mirror operated by string pull cord
- fe CO2 fire extinguisher/ fire blanket mounted on wall brackets
- tv Television Point
- Control Panel (for Intruder Alarm)
- Smoke Detector
- Heat Detector
- Sounder

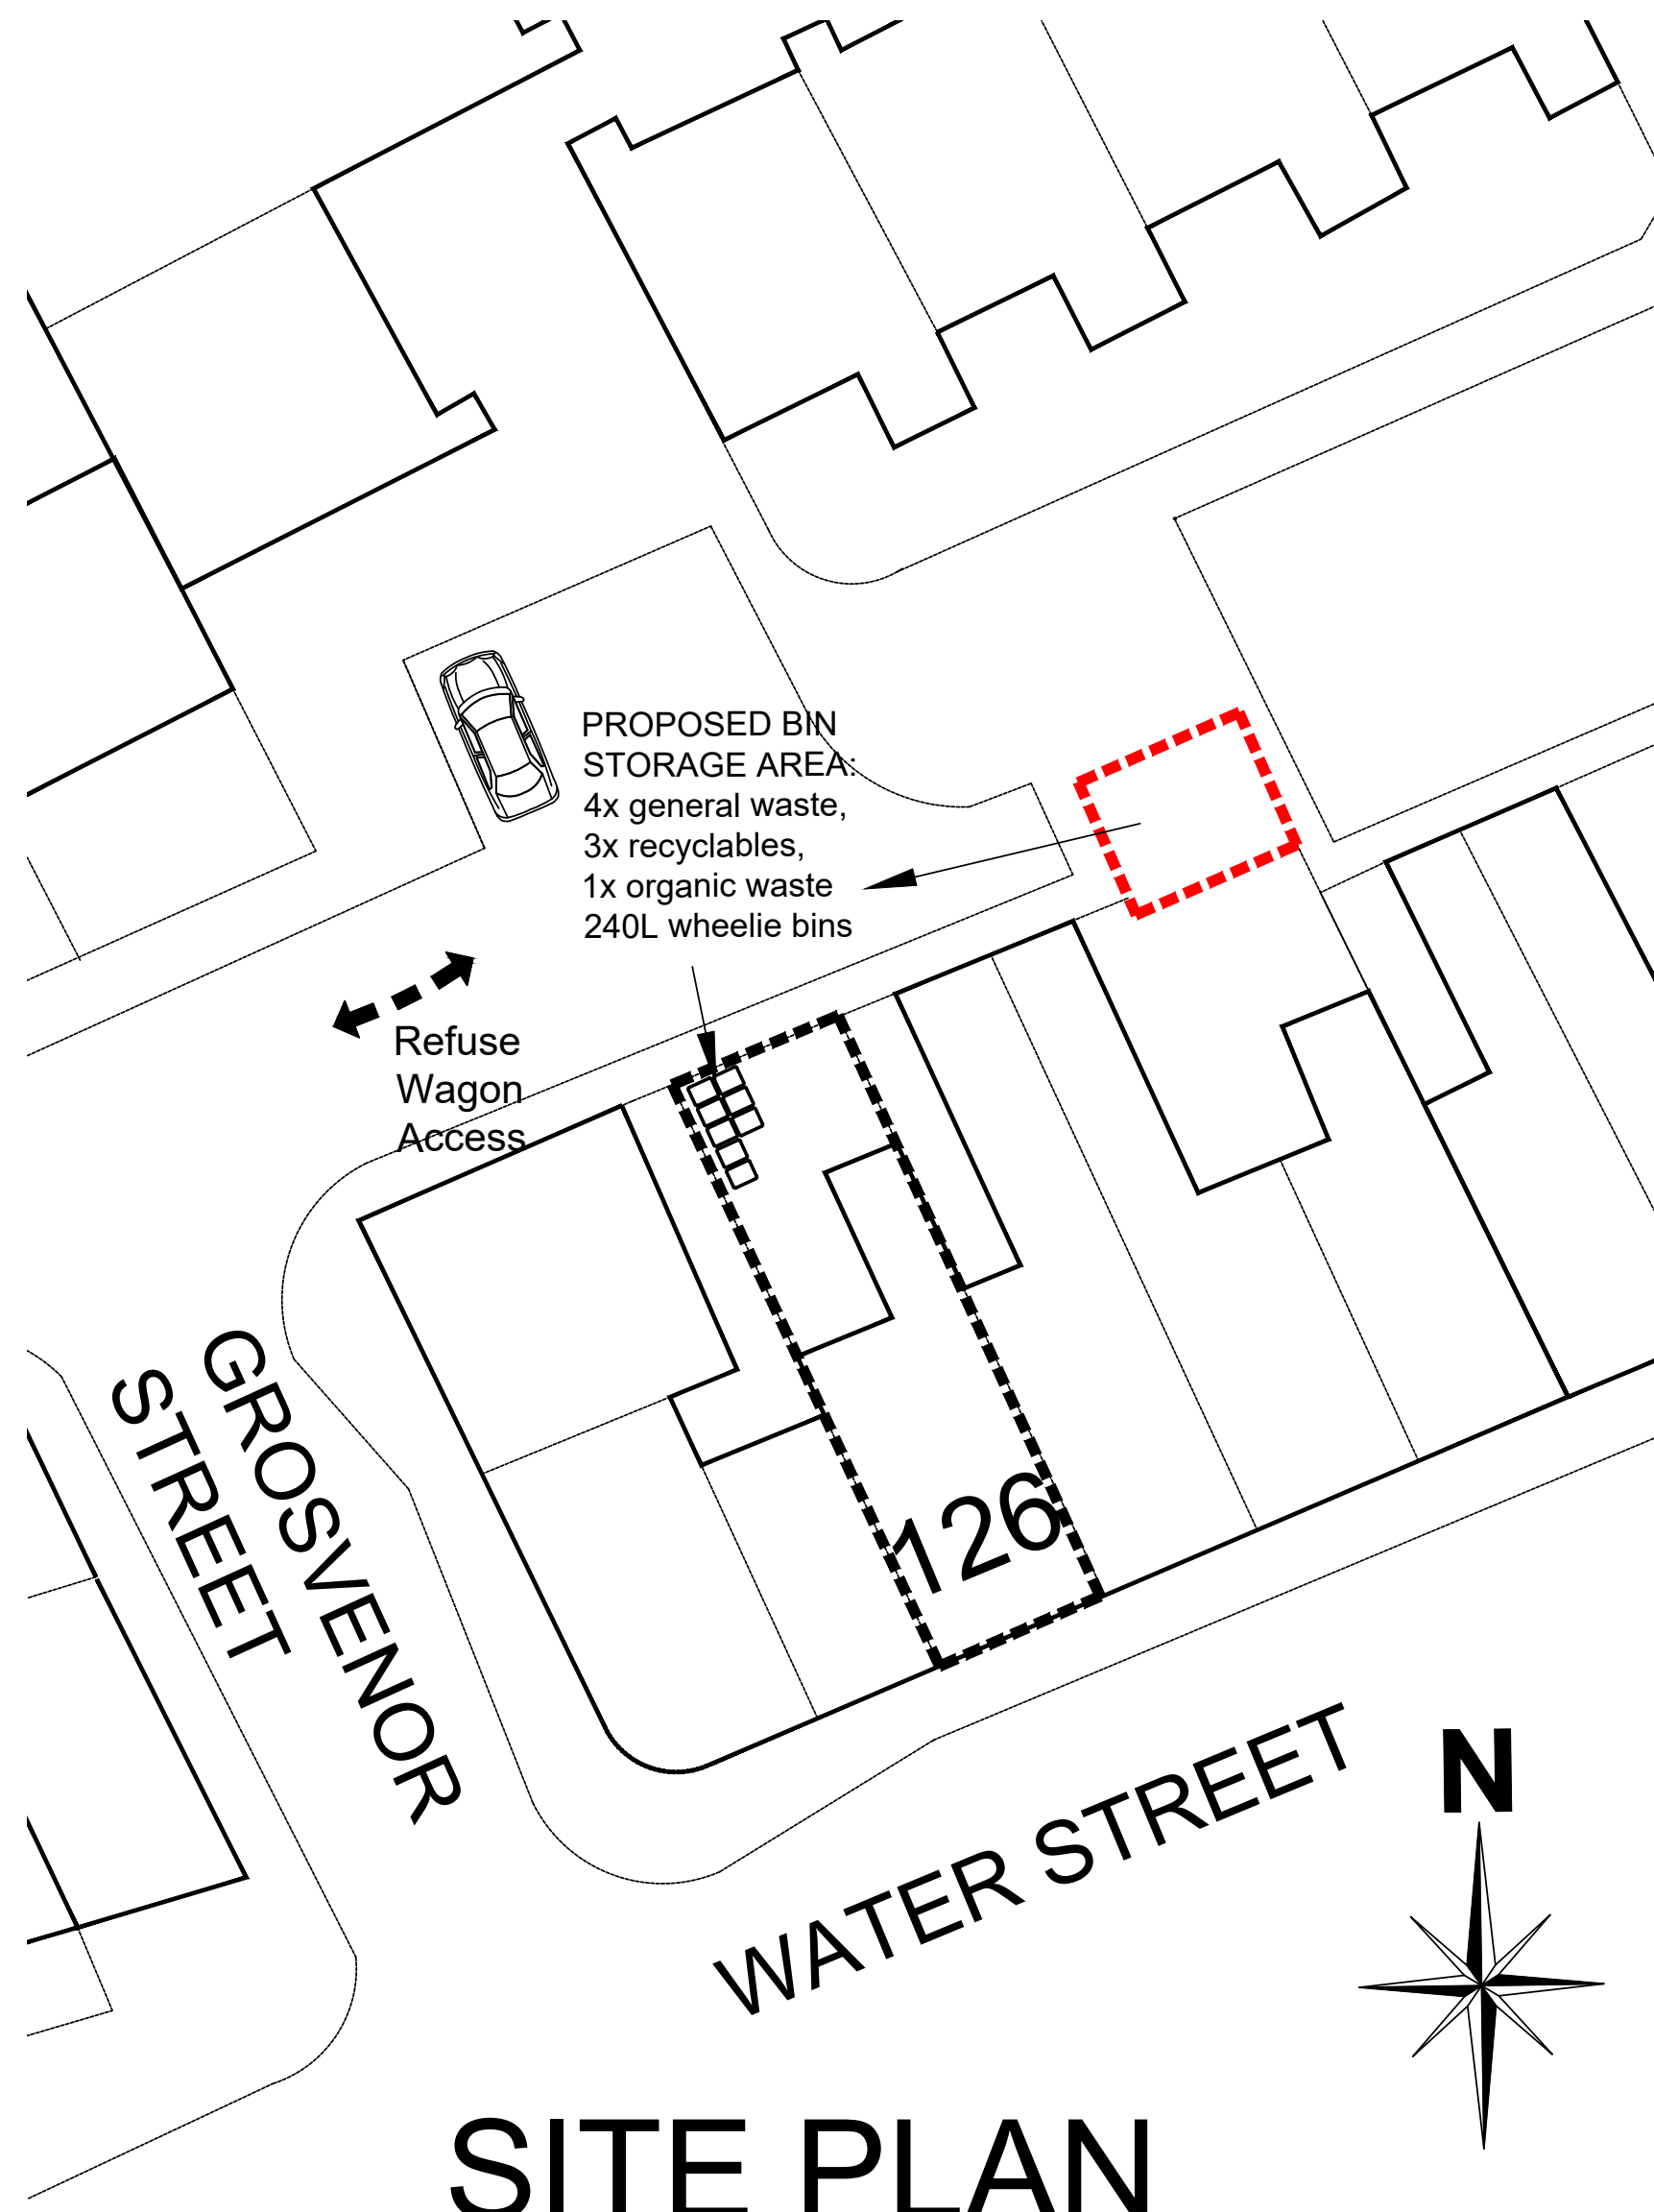

SITE PLAN
SCALE= 1:200

[REV:] DATE: [DETAILS:]
BM ARCHITECTURAL DESIGNS,
APARTMENT 8,
224 GREAT CLOWES STREET,
MANCHESTER M7 2ZS
TEL: 07415 493002
email- benjamin.maguire10@gmail.com
Project: CONVERSION OF FORMER WORKSHOP
BUILDING TO THE REAR OF
WATER STREET, RADCLIFFE,
BURY M26 4BE
Title: PROPOSED PLANS
Client: CASSEL AND FLETCHER
PROPERTY MANAGEMENT
Scale: 1:50@A1 Date: 03/ 2023 Drawn: BM
Status: PLANNING
Drawing no: BM/0323/WATER/PL2 Rev:
Architectural Design/ Planning/ Construction/ Building Regs