


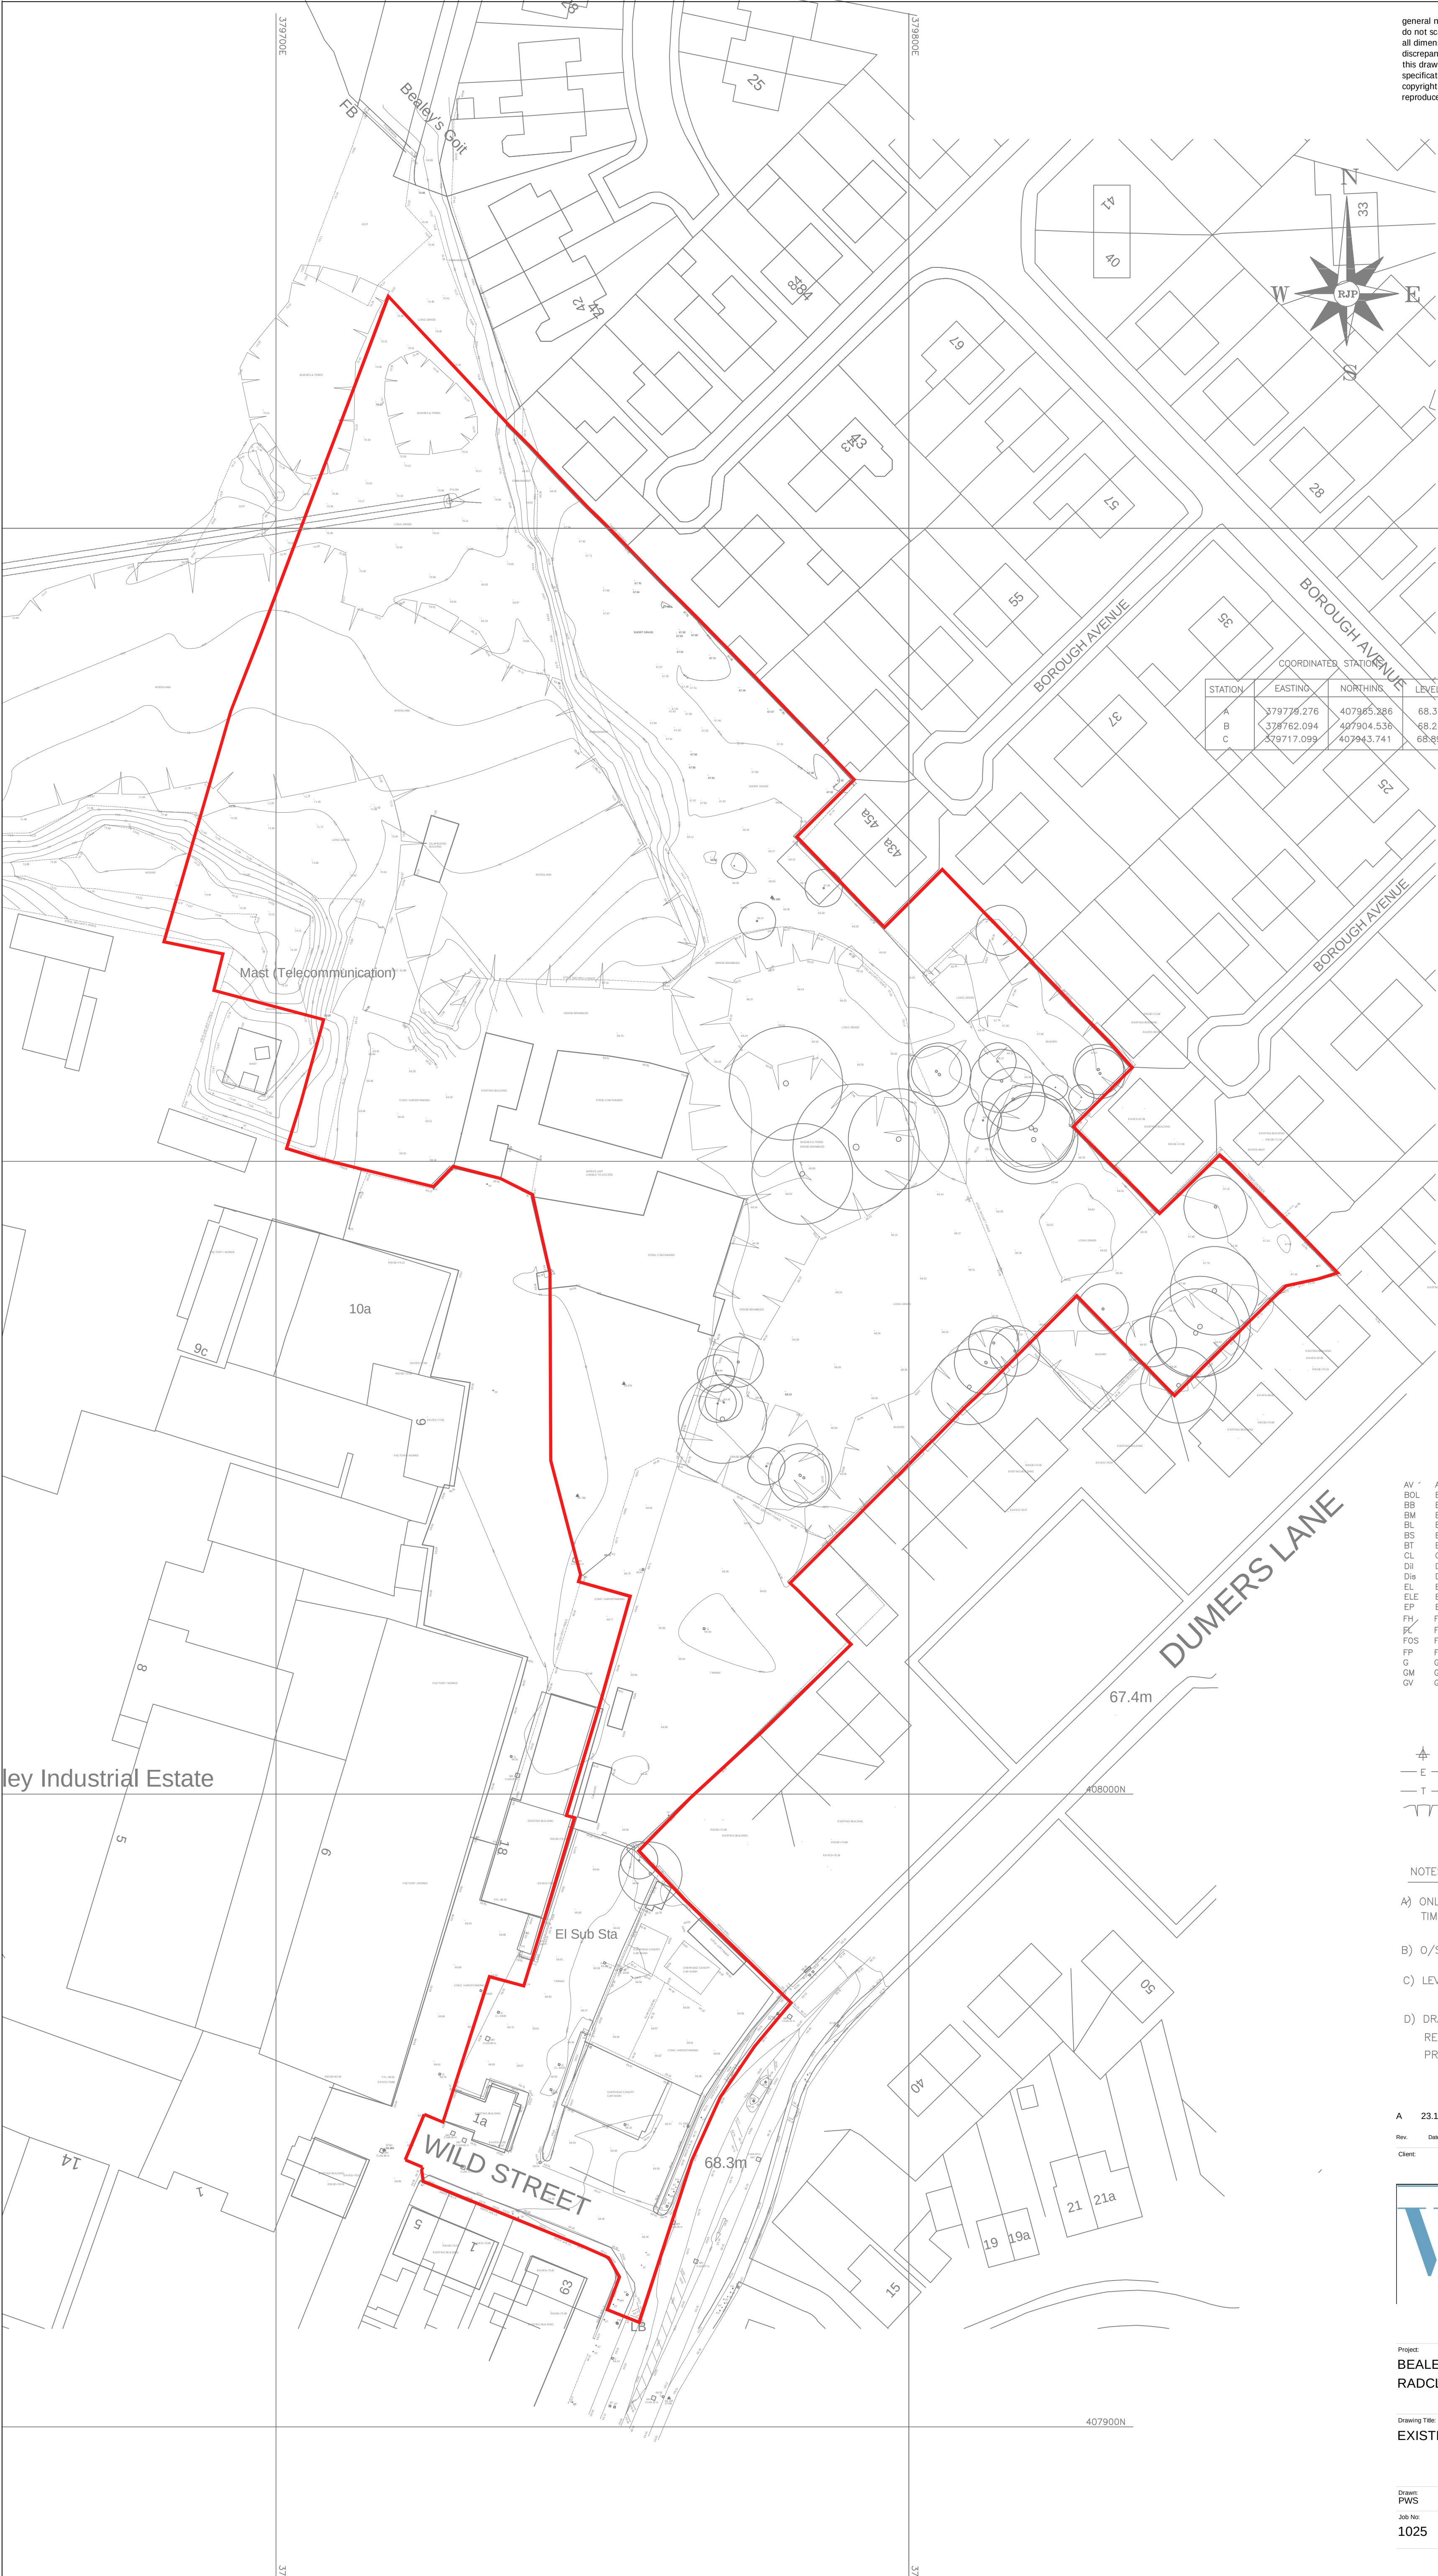

general notes:
do not scale the drawing.
all dimensions to be checked on site prior to commencement of work and any discrepancy shall be immediately reported and resolved prior to work commencing.
this drawing is to be read in conjunction with all relevant drawings and specifications relating to the job whether or not indicated on the drawing.
copyright reserved to mck associates ltd. and this drawing may not be used or reproduced without prior written consent.

COORDINATED STATIONING			
STATION	EASTING	NORTHING	LEVEL (m)
A	379778.276	407965.286	68.395
B	378762.094	407904.536	68.248
C	379717.099	407943.741	68.893

ABBREVIATIONS

AV	AIR VALVE/VENT	IC	INSPECT CHAMBER
BOL	BOLLARD	IL	INVERT LEVEL
BB	BELISHA BEACON	JKW	JAPANESE KNOTT WEED
BM	BENCH MARK	LH	LAMP HOLE
BL	BED LEVEL	LP	LAMP POST
BS	BUS STOP	NP	NAME PLATE
BT	BRITISH TELECOM	MH	MANHOLE
CL	COVER LEVEL	PS	POST/SIGN POST
DII	DILAPIDATED	PB	POST BOX
Dis	DISUSED	PX	UNKNOWN SERVICE
EL	EAVES LEVEL	RE	RODDING EYE
ELE	ELEC JUNCT. BOX	RL	RIDGE LEVEL
EP	ELECTRICITY POLE	RS	ROAD SIGN
FH	FIRE HYDRANT	ST	STOP TAP
FL	FLOOR LEVEL	TH	TRIAL HOLE
FOS	FULL OF SEDIMENT	TL	TRAFFIC LIGHT
FP	FLAG POLE	TP	TELEGRAPH POLE
G	GULLY	TV	CABLE TV BOX
GM	GAS METER	UH	UNABLE TO LIFT
GV	GAS VALVE	WM	WATER METER

SYMBOLS

	SURVEY STATION		TREE
	O/H ELEC CABLE		BENCH MARK
	O/H PHONE LINE		TRIAL PIT
	CANOPY/HEDGE		BOREHOLE

NOTES

- A) ONLY MANHOLES AND SERVICES VISIBLE AT TIME OF SURVEY SHOWN
- B) O/S USED AND ORIENTATED TO TRUE NORTH
- C) LEVELS IN METRES RELATED TO G.P.S.
- D) DRAINAGE INFORMATION TAKEN FROM LA RECORDS. INFORMATION MUST BE CHECKED PRIOR TO WORK COMMENCING

A 23.10.25 PWS ADDITIONAL LEVELS TAKEN CLOSE TO BOUNDARY OF 45 BOROUGH AV

Rev: Date By Description

Client:



Project:
BEALEY IND EST
RADCLIFFE

Drawing Title:
EXISTING SITE PLAN

Drawn PWS	Checked	Scale 1:500	Date NOV 2024
Job No 1025	Drawing No ESP	Rev: A	