
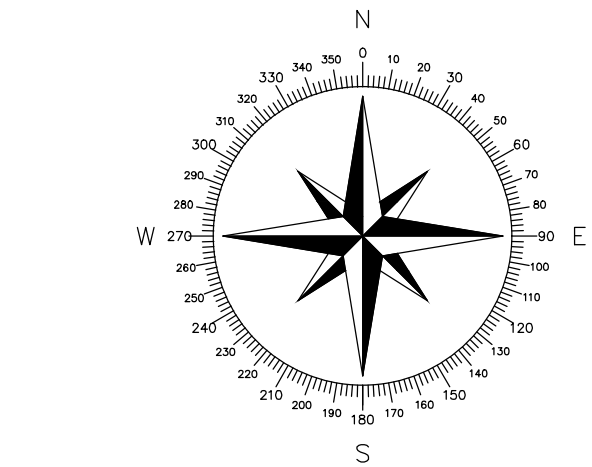


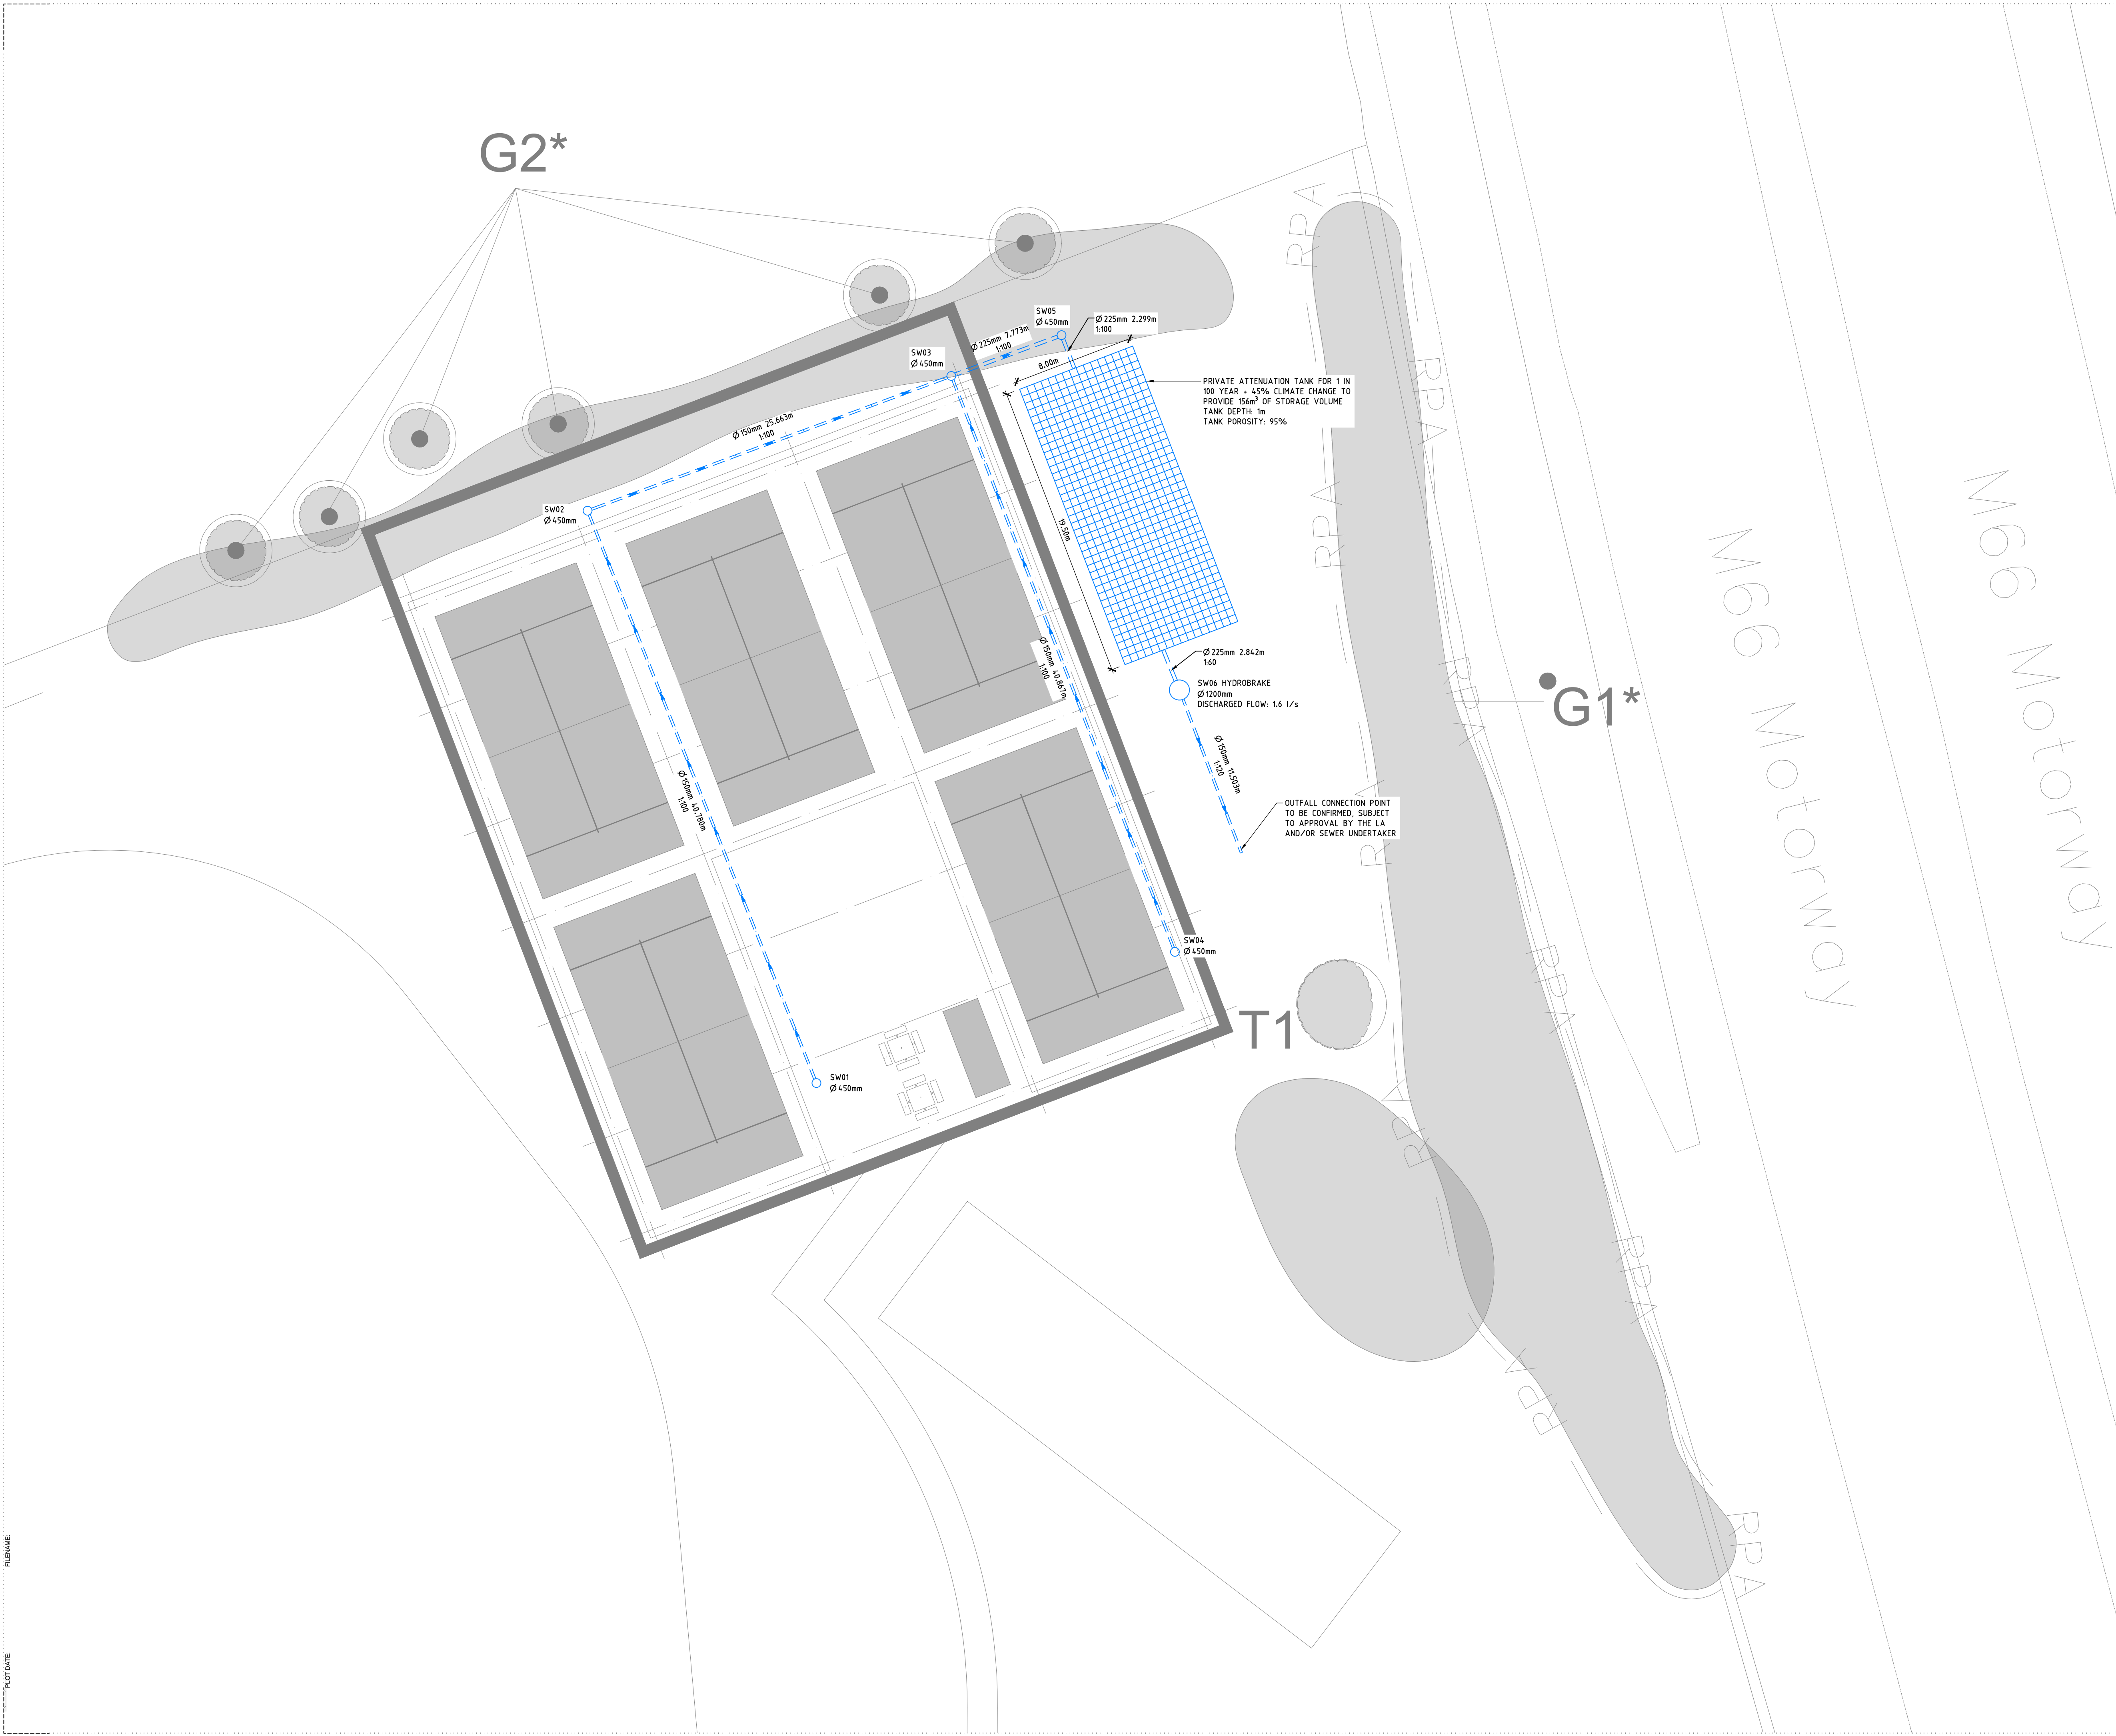

KEY:
PROPOSED SURFACE WATER SEWER

- NOTES:
1. THIS DRAWING IS NOT FOR CONSTRUCTION AND THE INFORMATION PROVIDED IS FOR FEASIBILITY PURPOSES.
 2. PROPOSED SEWERS SHOWN ARE INDICATIVE. ALL LENGTHS, SIZES AND PROPOSED LEVELS SHOWN ALONG WITH STORAGE VOLUMES QUOTED SHOULD BE CONFIRMED AT DETAILED DESIGN STAGE.
 3. CONNECTION TO THE EXISTING PIPE TO BE IN STRICT ACCORDANCE WITH LLFA/00 WITH ALL RELEVANT PERMITS TO BE OBTAINED PRIOR TO WORKS COMMENCING.
 4. THE SURFACE WATER DISCHARGE RATE FROM THE PROPOSED PADDEL COURT TO THE EXISTING SEWER IS TO MIMIC THE GREENFIELD RATE OF THE SITE 1.6 l/s.

P01 25.03.26 PRELIMINARY - Issued for Information		M.A.	R.A.
Rev	Date	Description	By
EDGE CONSULTING ENGINEERS www.edgece.com		Manchester . UK 3rd Floor, Cornovan Court, 12 Blackfriars Street, Manchester, M3 9BQ, United Kingdom T: +44 (0) 161 834 1938 E: manchester@edgece.com	
The concepts + information contained in this document are the copyright of EDGE Consulting Engineers. Use or copying of this document in whole or in part without the written permission of EDGE Consulting Engineers constitutes an infringement of copyright. DO NOT SCALE DRAWINGS. IF IN DOUBT, ASK!			
Project Name: UNSWORTH CC PADEL COURT			
Client: ON PADEL LTD			
Designed	Drawn	Checked	Scale @ A1
M.A.	M.A.	R.A.	1:200
Drawing Title: SCHEMATIC DRAINAGE LAYOUT			
Project No. 260020		PRELIMINARY NOT FOR CONSTRUCTION	
Drawing No. 260020-EDGE-XX-XX-DR-C-2001		Revision P01	