



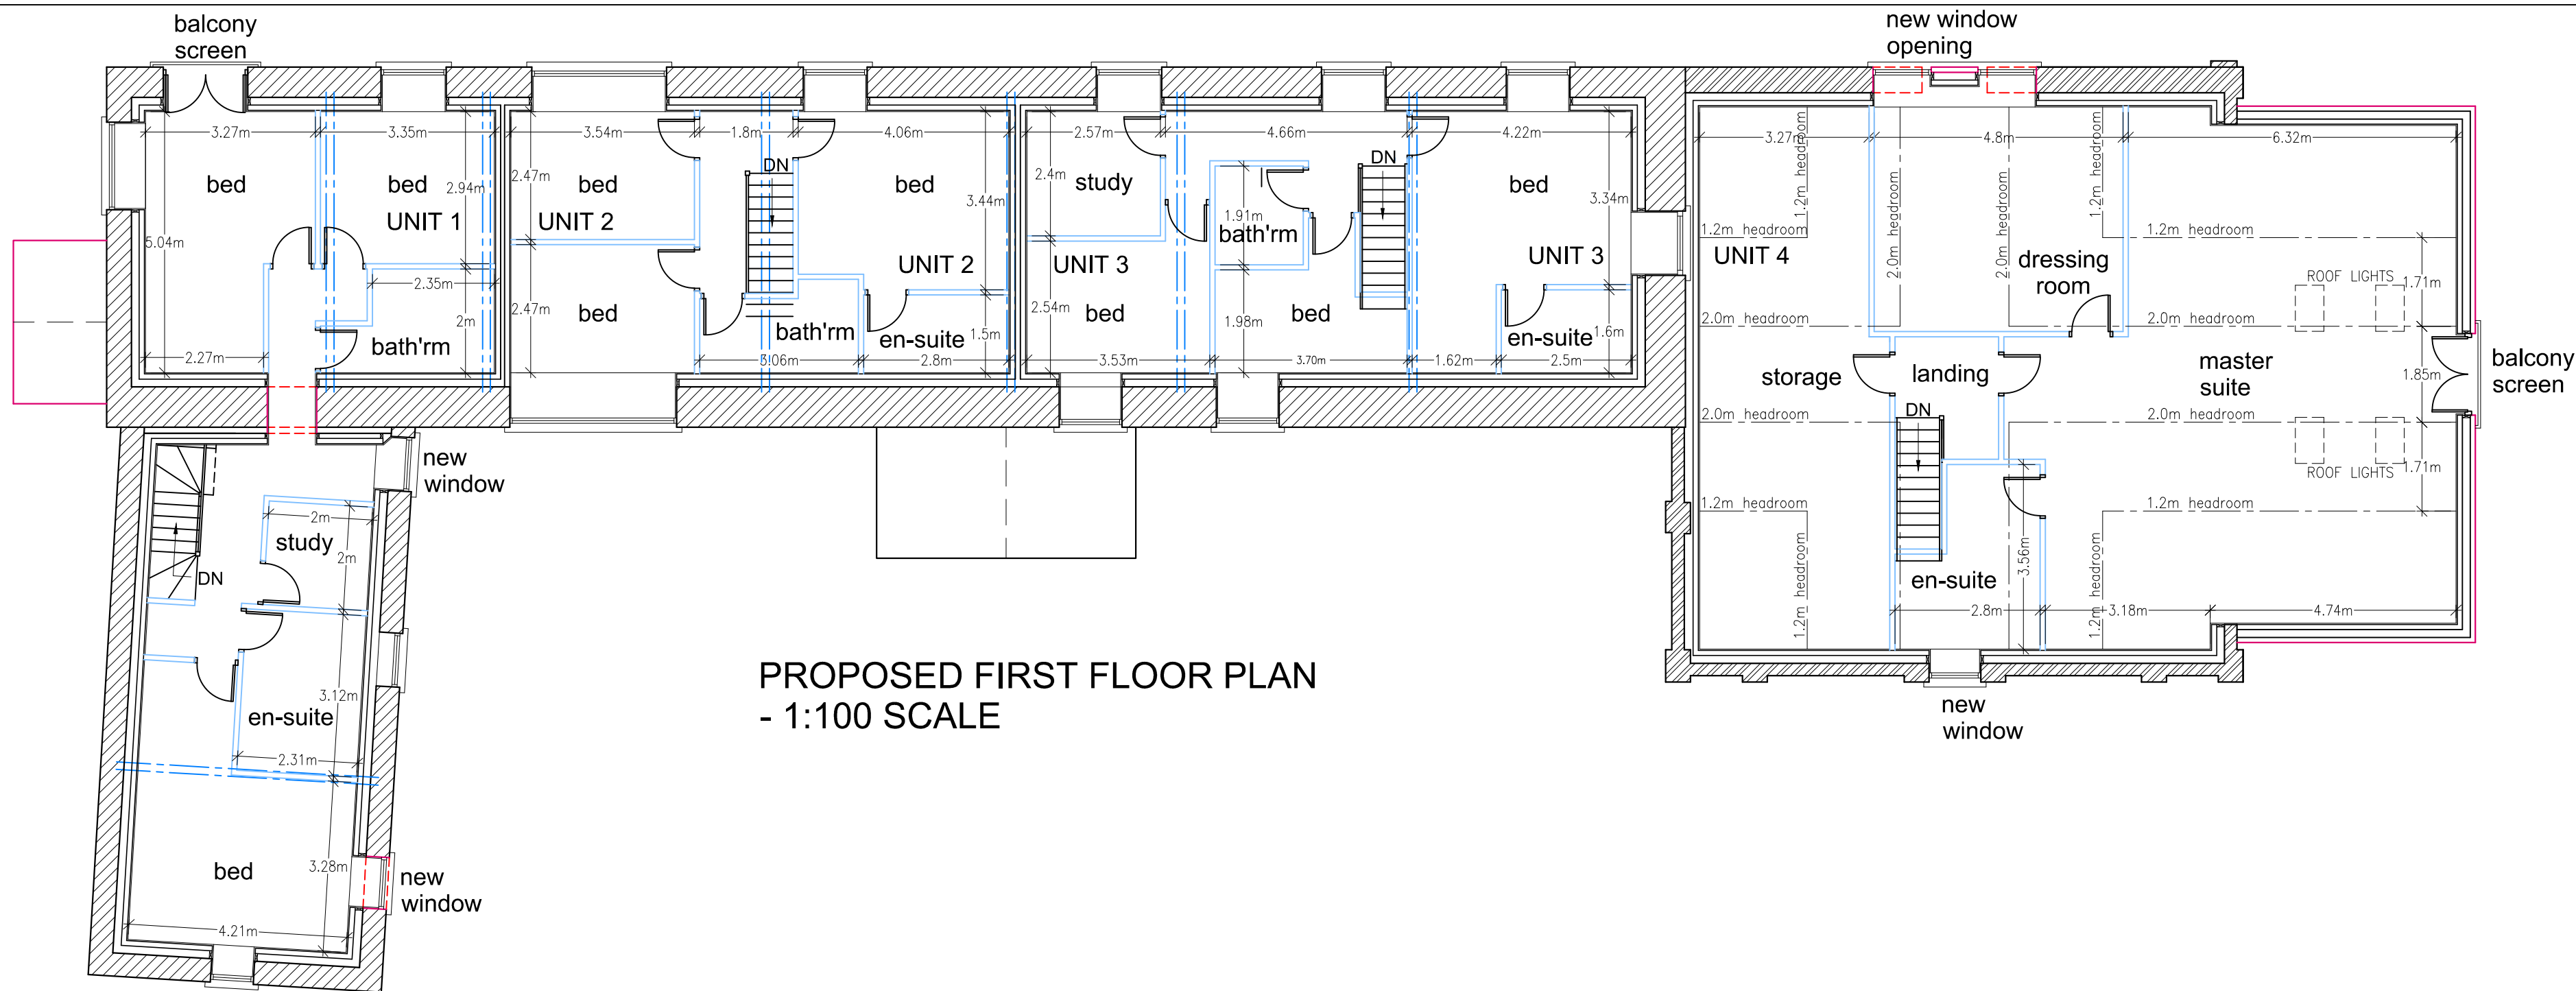

PROPOSED FIRST FLOOR PLAN
- 1:100 SCALE

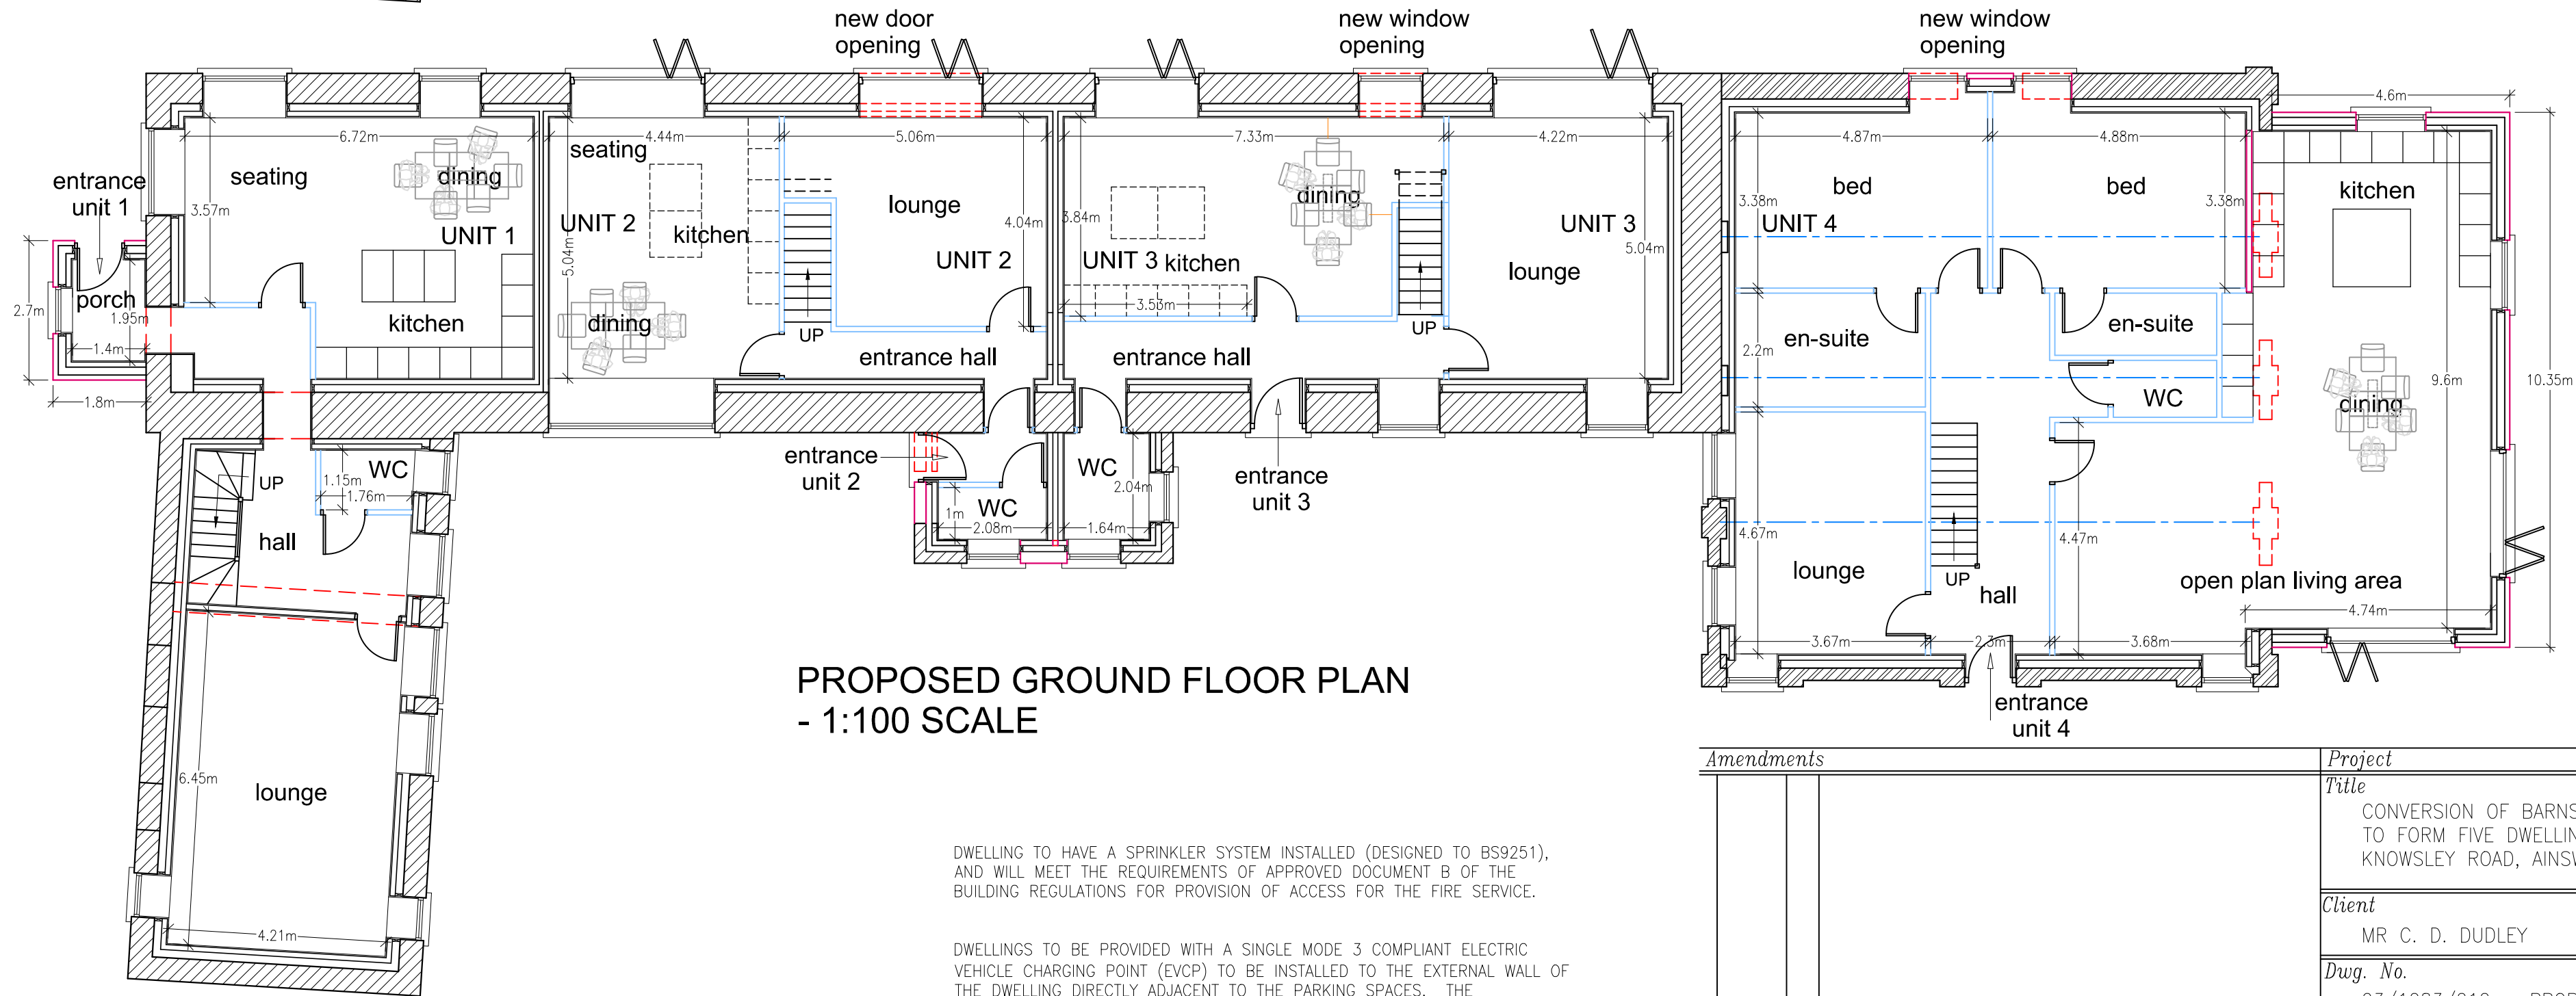

PROPOSED GROUND FLOOR PLAN
- 1:100 SCALE

DWELLING TO HAVE A SPRINKLER SYSTEM INSTALLED (DESIGNED TO BS9251), AND WILL MEET THE REQUIREMENTS OF APPROVED DOCUMENT B OF THE BUILDING REGULATIONS FOR PROVISION OF ACCESS FOR THE FIRE SERVICE.

DWELLINGS TO BE PROVIDED WITH A SINGLE MODE 3 COMPLIANT ELECTRIC VEHICLE CHARGING POINT (EVCP) TO BE INSTALLED TO THE EXTERNAL WALL OF THE DWELLING DIRECTLY ADJACENT TO THE PARKING SPACES. THE SPECIFICATION FOR THE EVCP'S ARE TO BE; ROLEK WALLPOD:EV TYPE 2 MODE 3 CHARGING SOCKET.

Amendments

Project

Title	CONVERSION OF BARNs & REPLACEMENT OF STABLES TO FORM FIVE DWELLINGS AT BARRACK FOLD FARM, KNOWSLEY ROAD, AINSWORTH, BL2 5PU~		
Client	MR C. D. DUDLEY		
Dwg. No.	23/1283/212 - PROPOSED PLANS - UNITS 1-4		
Date	19.10.2022	Plot Scale	A2@1:100
Drawn by	JPE	Status	PLANNING