
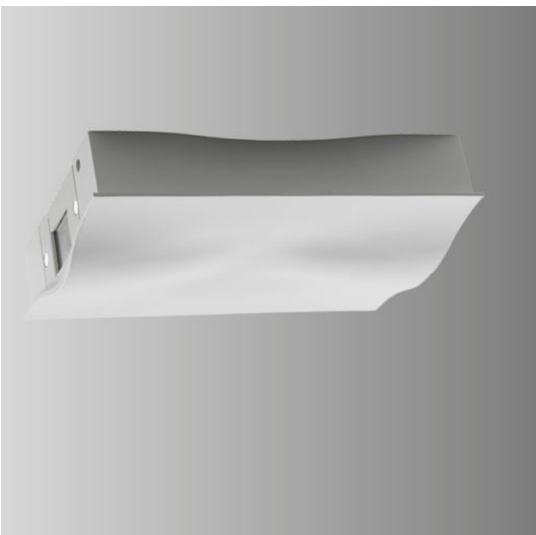
 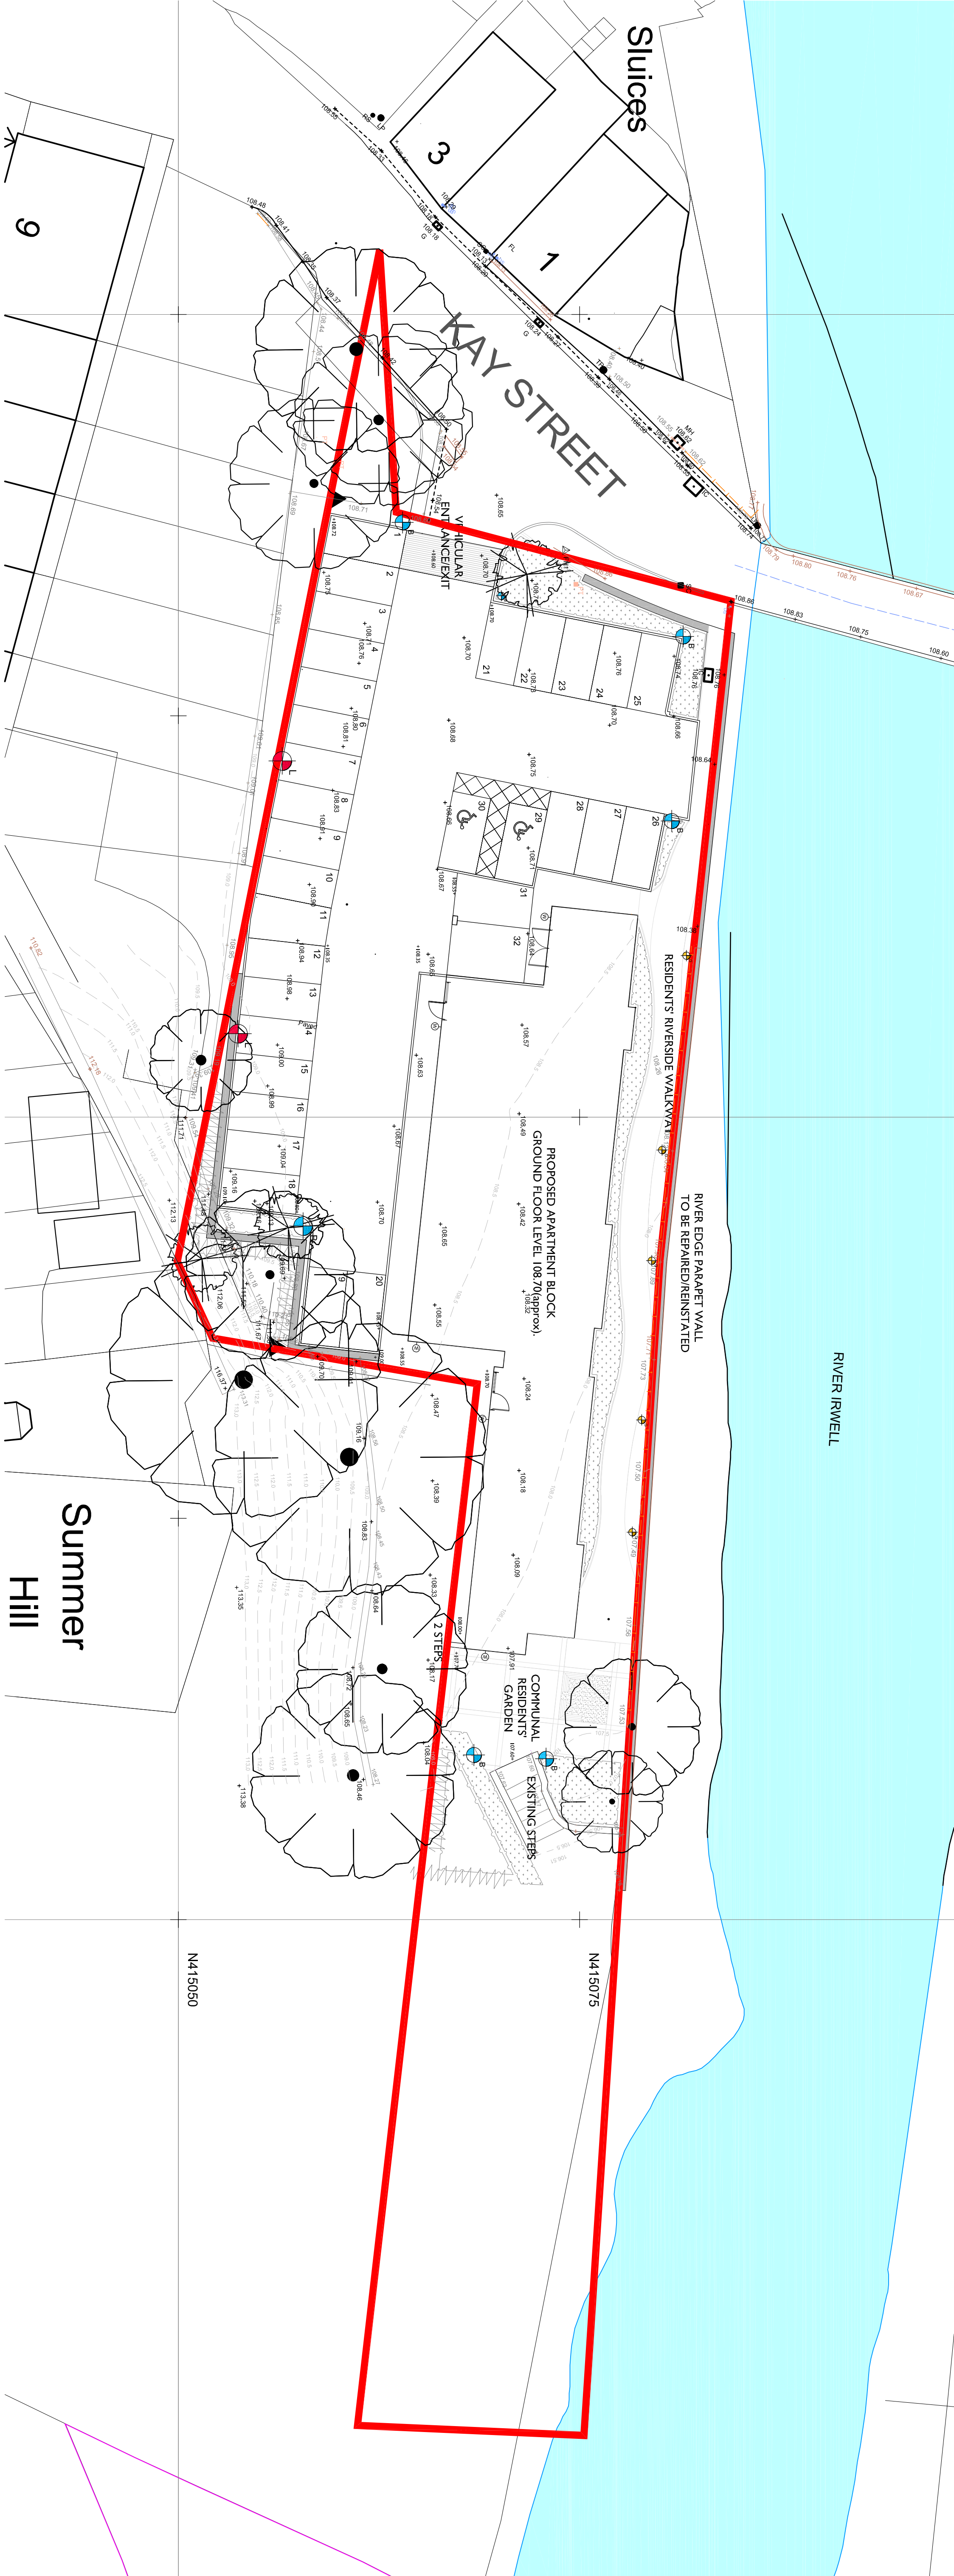




NOTES:

CONTRACTORS MUST VERIFY ALL DIMENSIONS ON SITE BEFORE
COMMENCEMENT OF ANY WORK OR PREPARING
MANUFACTURING DRAWINGS
DO NOT SCALE FROM THIS DRAWING
ANY DISCREPANCIES ON THIS DRAWING ARE TO BE
NOTIFIED TO THE ARCHITECT IMMEDIATELY
HATTRELL DS ONE ARCHITECTS LLP COPYRIGHT

REV	AMENDMENT	DATE	CHKD




Steon : Elara Midi
2x26W LED Light Wall Light with PPR
Luminous Efficacy: 108lm/w
Finish: Metallic Grey Powder Coated
Aluminium
Colour Temperature: 3000K
Size: H25mmxW16mmxD56mm

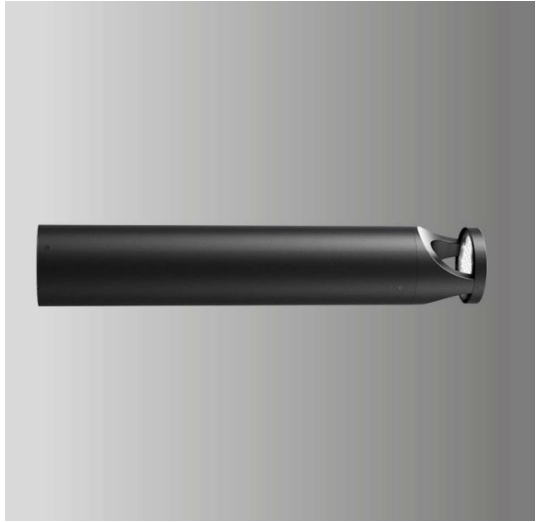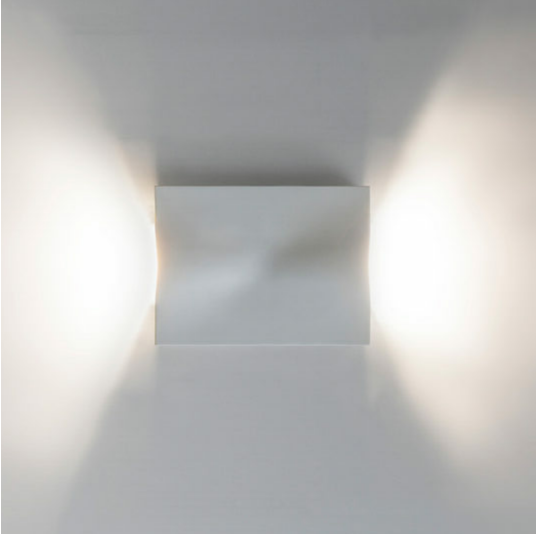



Steon : Monarch 14W LED Bollard
Luminous Efficacy: 35lm/w
Finish: Black Powder Coated
Aluminium
Colour Temperature: 4000K
Dims Dia65mm XH900mm



Steon : Nomus 1.5W LED
Groundlight
Finish: Stainless Steel
Colour Temperature: 3500K
Size: Dia88mm

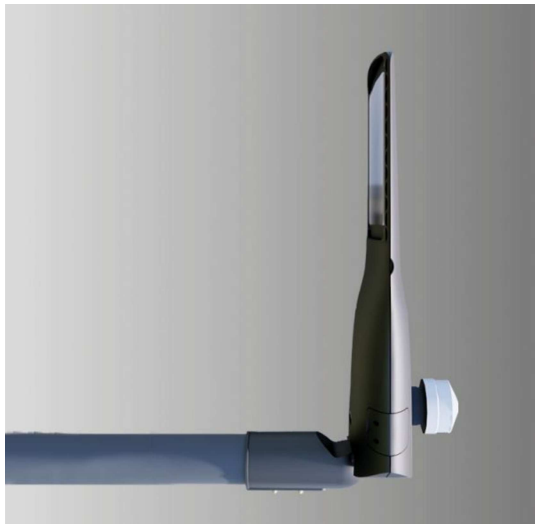

Steon : Conдор Midi 150W LED
Luminous Efficacy: 116lm/w
Finish : Grey Powder Coated
Aluminium
Colour Temperature: 4000K
Asymmetric 150° beam angle

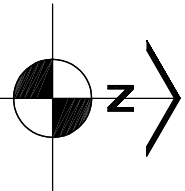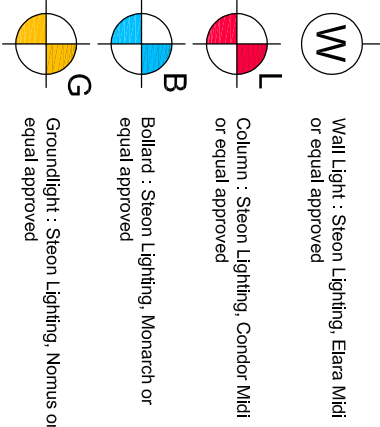

HATTRELL LLP

SHARPE E. KINGS COURT RAILWAY STREET ALTRINCHAM CHESHIRE WA14 2RD
TELEPHONE 0161 1820 4207
e-mail: design@hattrrell.co.uk / www.hattrrell.co.uk

CLIENT

Opuilwood Developments Ltd

PROJECT

Waterside,
Summerseat

DRAWING TITLE
Proposed External
Lighting Layout

SCALE @A1 DRAWN BY IS CHECKED DATE
1:200 ST 03/22

DRAWING No 2492-2-11 REVISION -

PLANNING