


ISO A1 594mm x 841mm
Last saved by: AL17(2023-08-04) Last Plotted: 2023-08-04
Filename: \\na.aecomnet.com\lfs\EMEA\Manchester-UK\CR5\DCS\Projects\BP\08240054_Bury_Hospice\900_CAD\GIS\910_CAD\Civils\Current Drawings\RIBA2 - Planning\08240054-ACM-XX-XX-DR-CE-00005 Drainage Layout

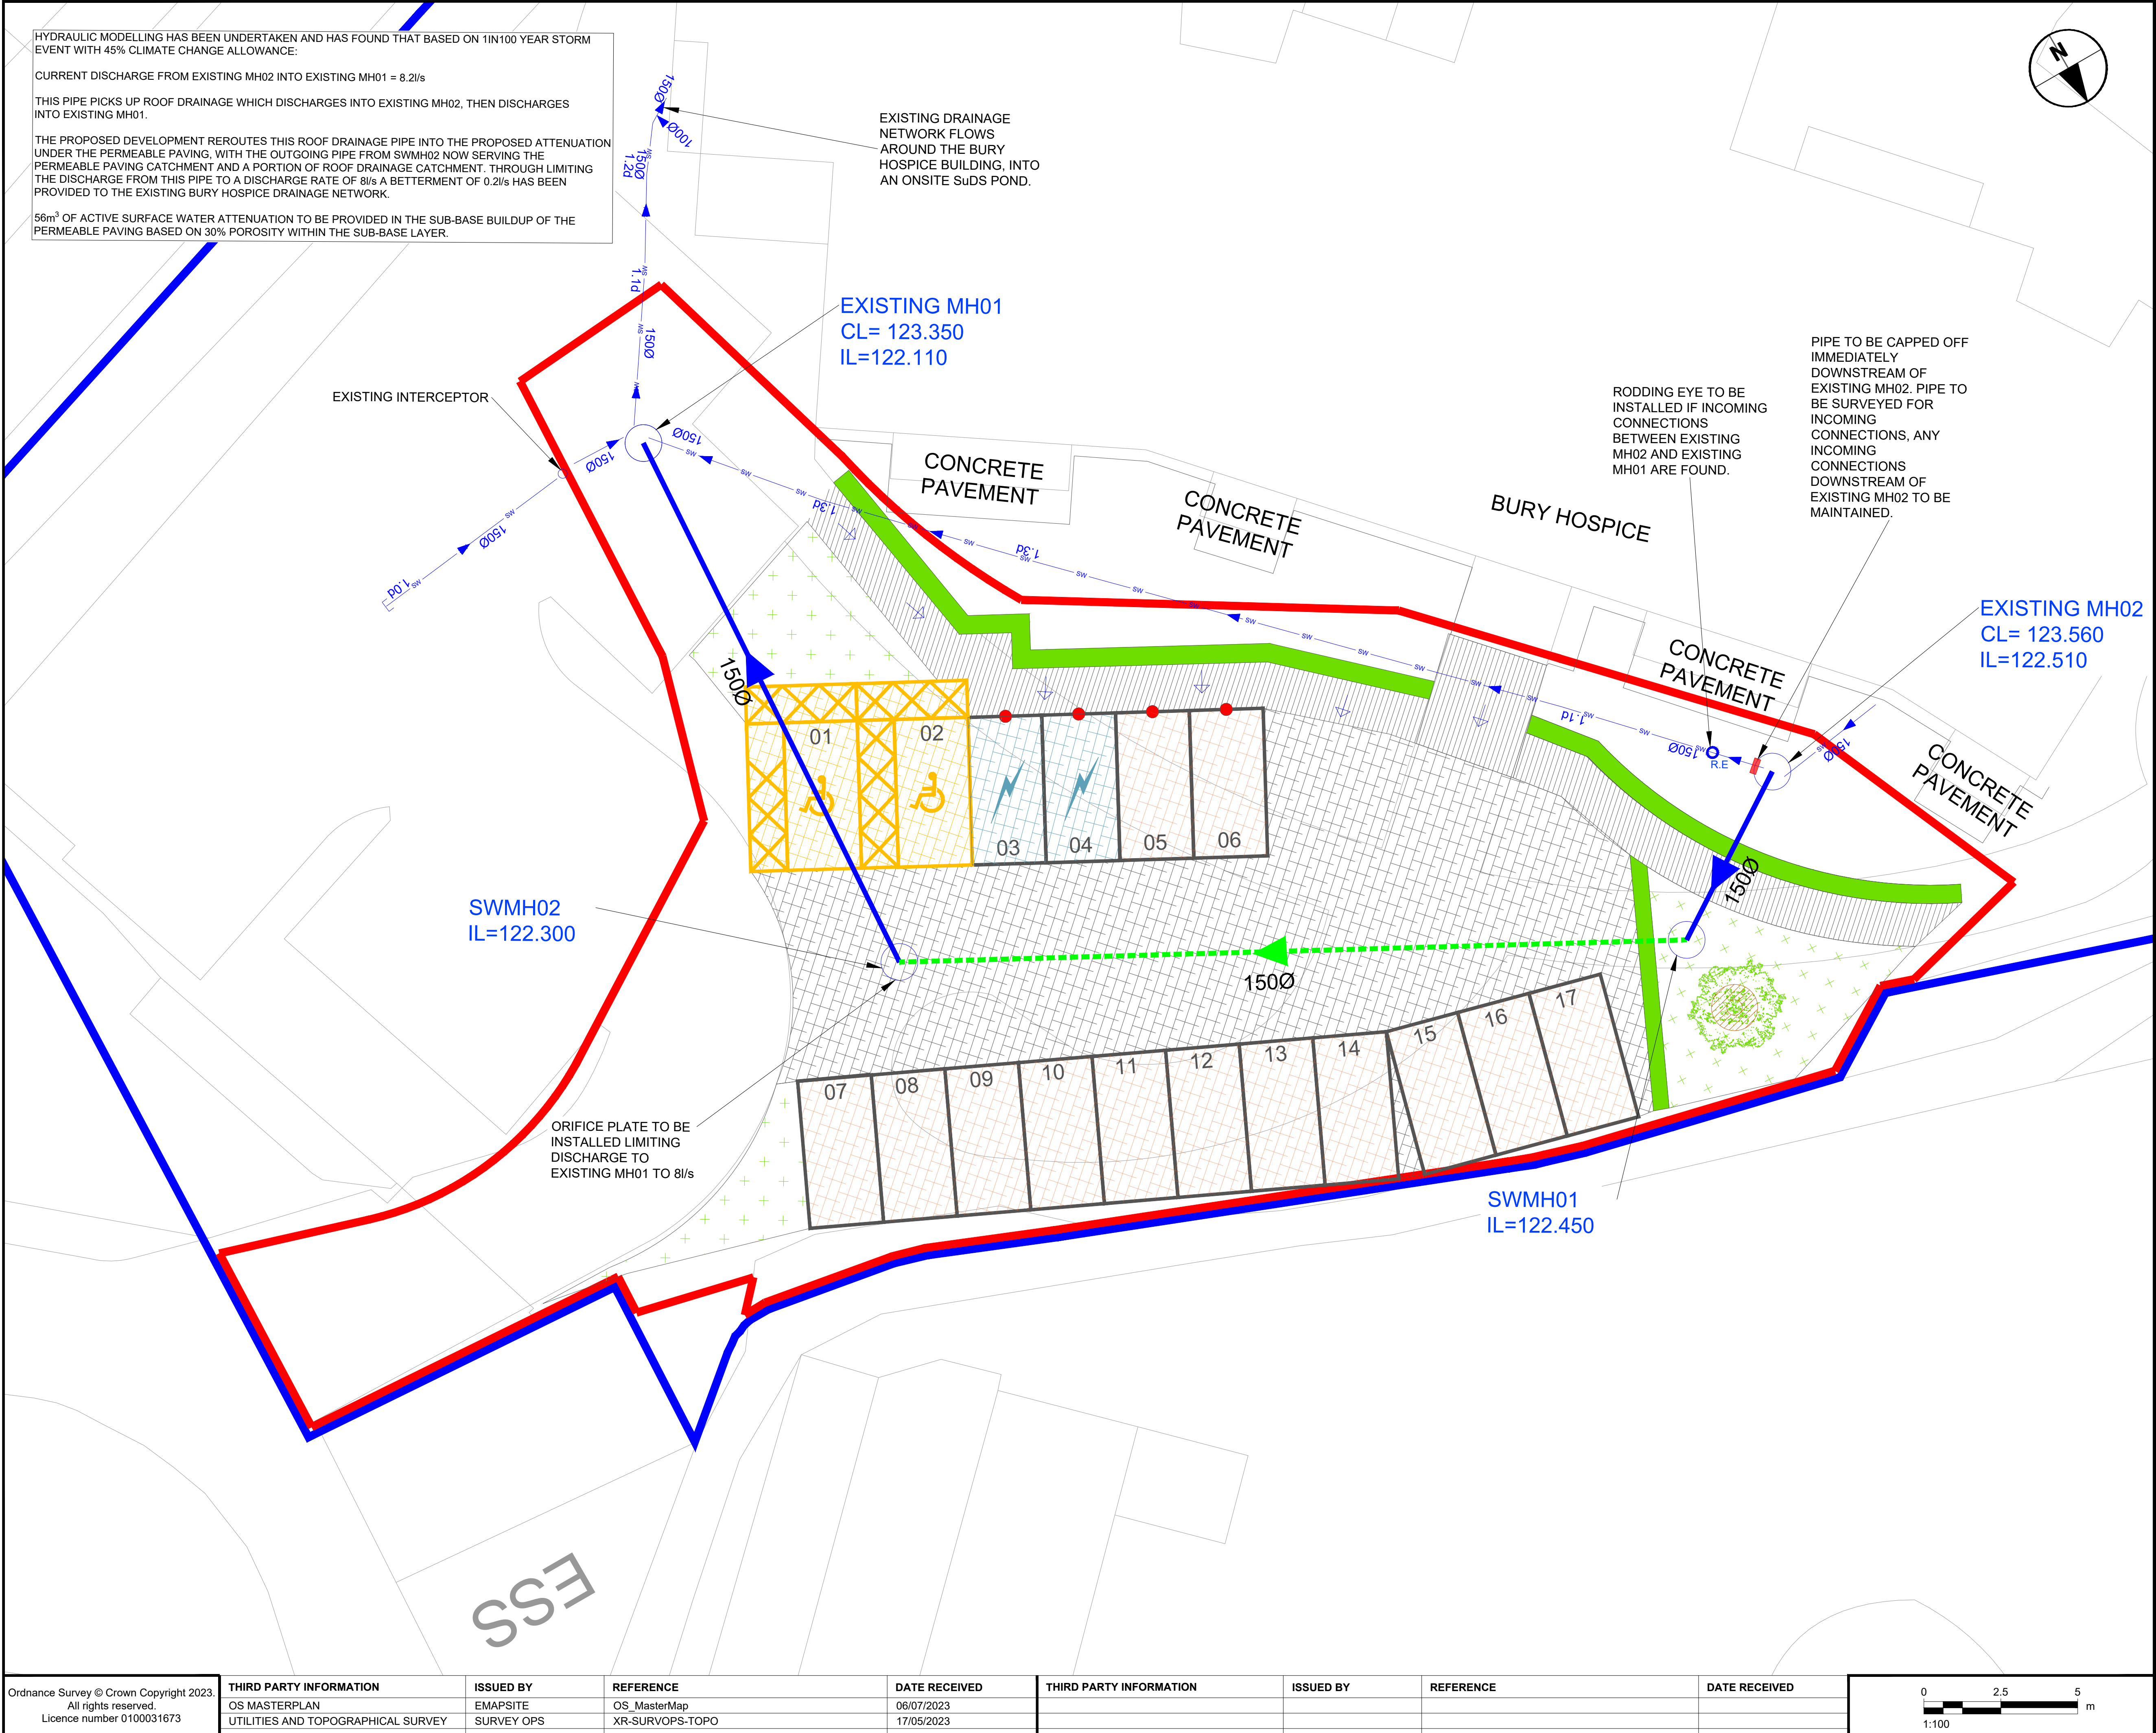

This drawing has been prepared for the use of AECOM's client. It may not be used, modified, reproduced or relied upon by third parties, except as agreed by AECOM or as required by law. AECOM accepts no responsibility, and denies any liability whatsoever, to any party that uses or relies on this drawing without AECOM's express written consent. Do not scale this document. All measurements must be obtained from the scaled dimensions.

AECOM

PROJECT

**BURY HOSPICE
CARPARK UPGRADE**

CLIENT

BURY HOSPICE

CONSULTANT

AECOM Limited
100 Embankment
Cathedral Approach
United Kingdom, M3 7FB
T: +44-20-7061-7000
www.aecom.com

NOTES

- ALL DIMENSIONS ARE IN METRES AND ALL LEVELS IN METRES ABOVE ORDNANCE DATUM UNLESS NOTED OTHERWISE.
- THIS DRAWING IS TO BE READ IN CONJUNCTION WITH ALL OTHER SCHEME DRAWINGS AND DOCUMENTS.
- THIS DRAWING IS TO BE USED FOR THE STATED PURPOSE OF ISSUE ONLY AND MUST NOT BE USED FOR ANY OTHER PURPOSE THAN THAT INDICATED.
- ONLY WRITTEN DIMENSIONS SHALL BE USED. CRITICAL DIMENSIONS AND LEVELS SHALL BE VERIFIED ON SITE BY THE CONTRACTOR PRIOR TO WORK COMMENCEMENT.
- ANY DISCREPANCIES IN DIMENSIONS OR DETAILS ON OR BETWEEN THESE DRAWINGS SHALL BE DRAWN TO THE ATTENTION OF THE PROJECT MANAGER FOR CLARIFICATION.
- REFER TO DRAWING '08240054-ACM-XX-XX-DR-CE-000009' FOR MORE DETAILS REGARDING PERMEABLE PAVING DETAIL AND ASPHALT FOOTWAY.
- SURFACE WATER DISCHARGE VIA SOAKAWAY APPEARS TO BE INFEASIBLE DUE TO CLAYEY LAYERS IN EXISTING GROUND IDENTIFIED THROUGH LOCAL BOREHOLE RECORDS.

KEY

- ADJOINING LAND OWNED BY THE APPLICANT
- PROJECT BOUNDARY
- SURFACE WATER MANHOLE
- RODDING EYE
- NON PERFORATED DRAINAGE PIPE
- PERFORATED DRAINAGE PIPE
- CHANNEL DRAIN
- SURFACE WATER FLOW ARROWS
- END OF PIPE TO BE CAPPED

ISSUE/REVISION

P01	02/08/2023	PLANNING ISSUE	NM	JL	VB
I/R	DATE	DESCRIPTION	BY	CK	AP

SUITABILITY

S2 - Suitable for information

PROJECT NUMBER

08240054

SHEET TITLE

BURY HOSPICE
DRAINAGE LAYOUT PLAN

SHEET NUMBER

08240054-ACM-XX-XX-DR-CE-00005

SCALE

1:100 @ A1

REVISION

P01

Ordnance Survey © Crown Copyright 2023.
All rights reserved.
Licence number 0100031673

THIRD PARTY INFORMATION
OS MASTERPLAN
UTILITIES AND TOPOGRAPHICAL SURVEY

ISSUED BY
EMAPSITE
SURVEY OPS

REFERENCE
OS_MasterMap
XR-SURVOPS-TOPO

DATE RECEIVED
06/07/2023
17/05/2023

THIRD PARTY INFORMATION

ISSUED BY

REFERENCE

DATE RECEIVED

0 2.5 5
1:100 m