



NOTES

- THIS DRAWING SHALL BE READ IN CONJUNCTION WITH ALL OTHER 24-7 GROUP DRAWINGS AND DOCUMENTATION.
- THE ELECTRICAL INSTALLATION SHALL BE IN ACCORDANCE WITH THE LATEST EDITION OF THE IET WIRING REGULATIONS BS7671, INCLUDING ANY AMENDMENTS.
- ALL EQUIPMENT TO BE INSTALLED IN ACCORDANCE WITH THE MANUFACTURER'S RECOMMENDATIONS.
- REFER TO LIGHTING CONTROL PHILOSOPHY DRAWINGS (REF: 17300-247-P1-00-D-E-630000, 17300-247-P1-01-D-E-630001 & 17300-247-P1-02-D-E-630002) FOR LIGHTING CONTROL METHODS.
- EMERGENCY TEST KEY SWITCHES FOR TESTING OF EMERGENCY LIGHTING LUMINAIRES ARE LOCATED ADJACENT TO EACH RELEVANT DISTRIBUTION BOARD. EACH EMERGENCY LUMINAIRE CONTAINS AN INTEGRAL 3-HOUR BATTERY PACK.
- ALL GENERAL FINAL CIRCUITS ARE PROVIDED WITH EITHER MCB OR RCBO PROTECTION, AS STATED ON THE DISTRIBUTION BOARD SCHEDULES.

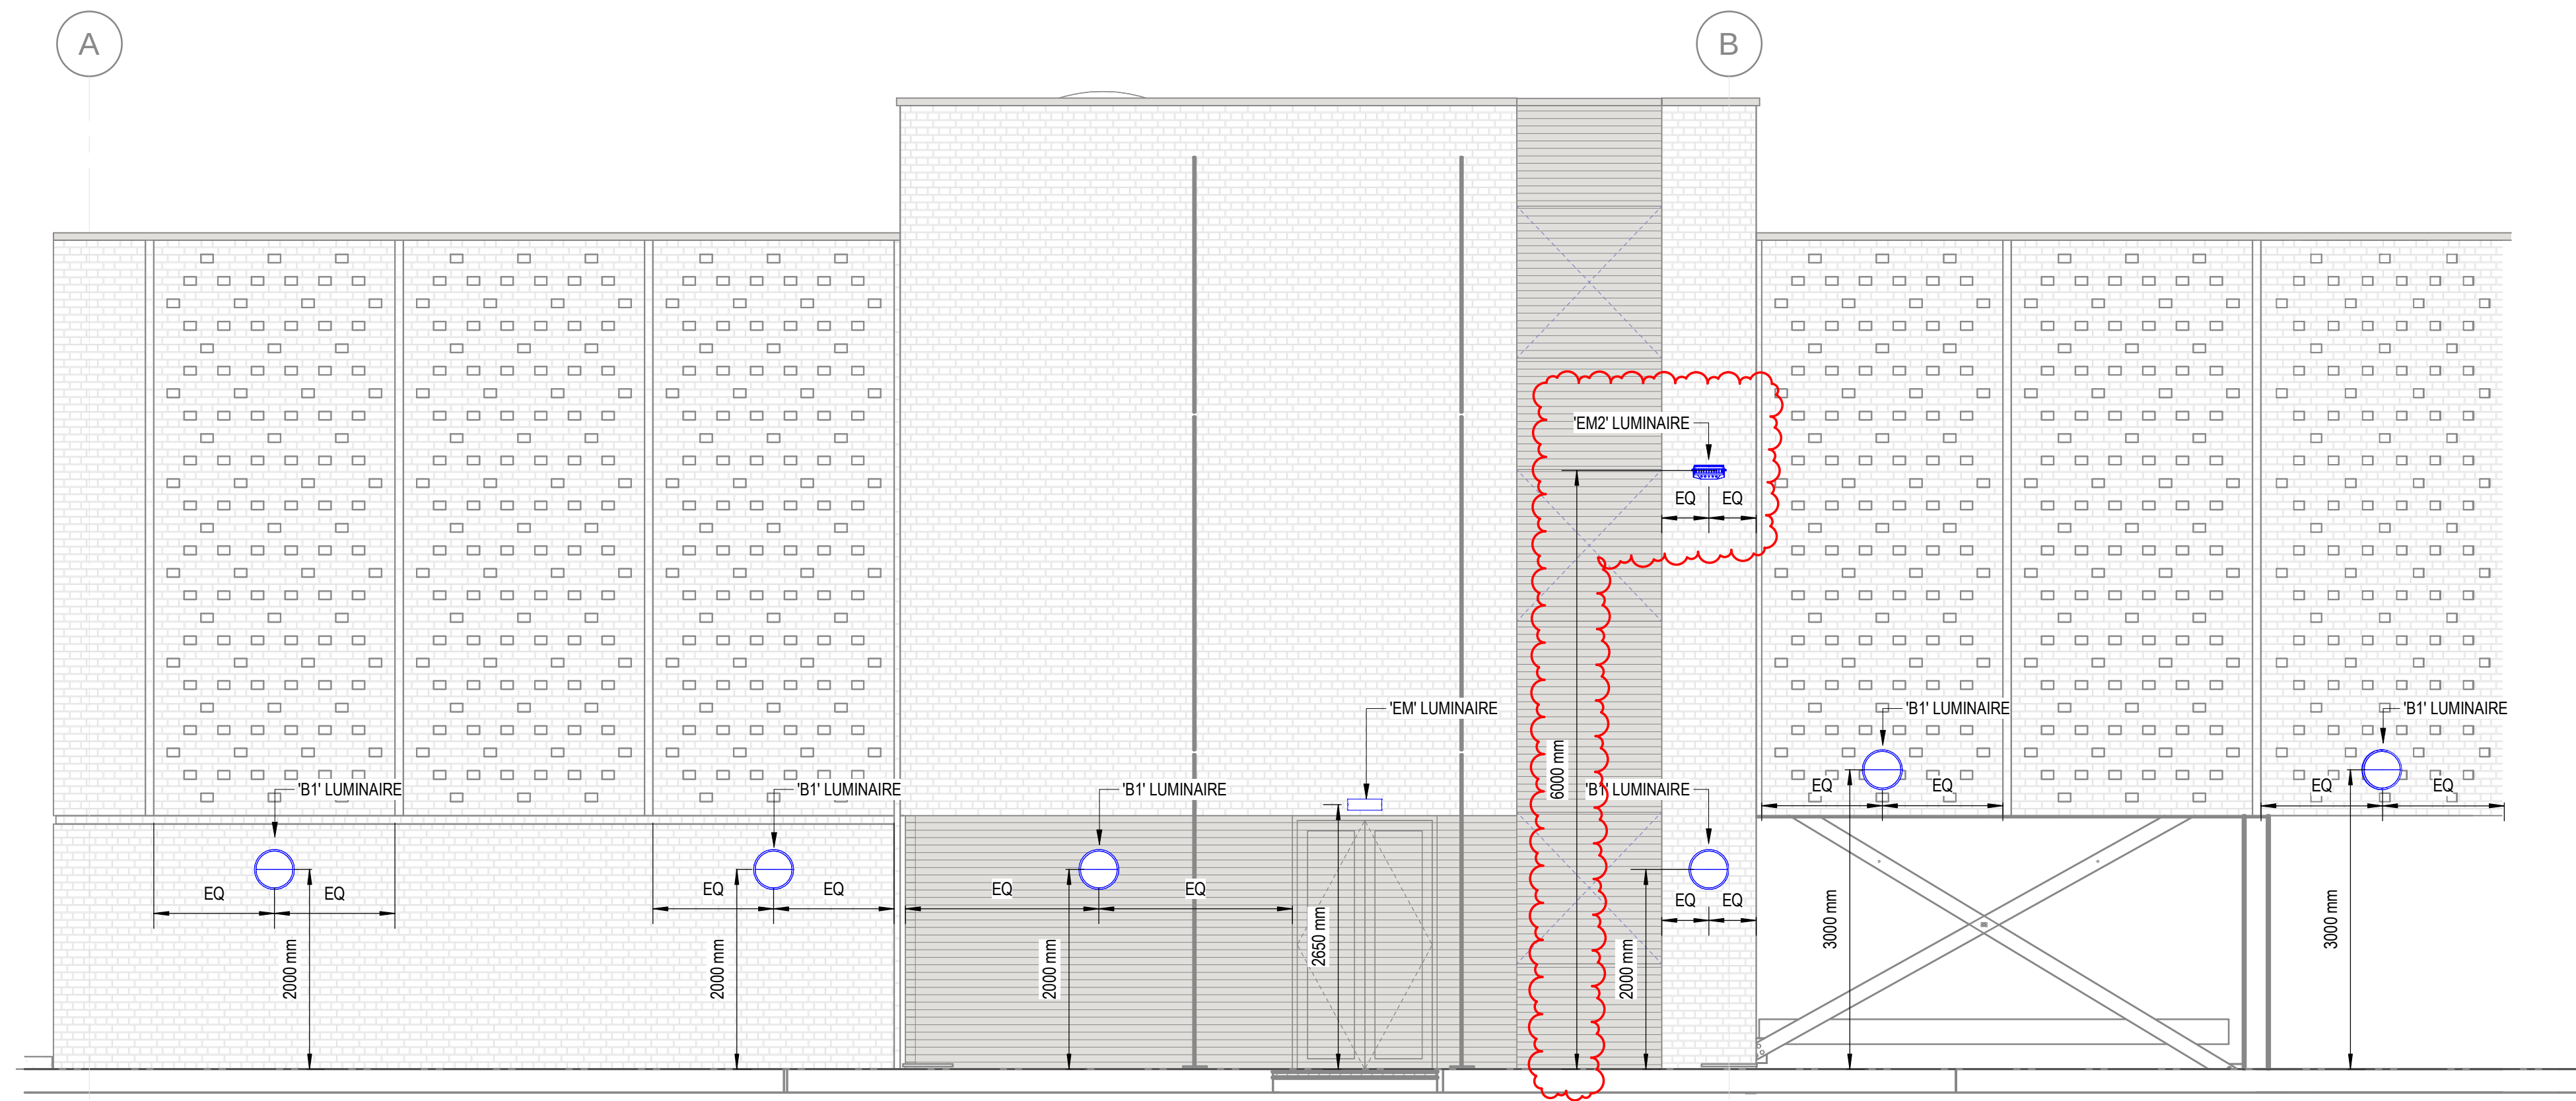

ELEVATION A-A PERIMETER WALKWAY
NORTH FACING ELEVATION (FACING HIGHFIELD PLACE)
REFER TO DRAWING REF
17300-247-P1-00-D-E-630000
FOR LIGHTING LAYOUT

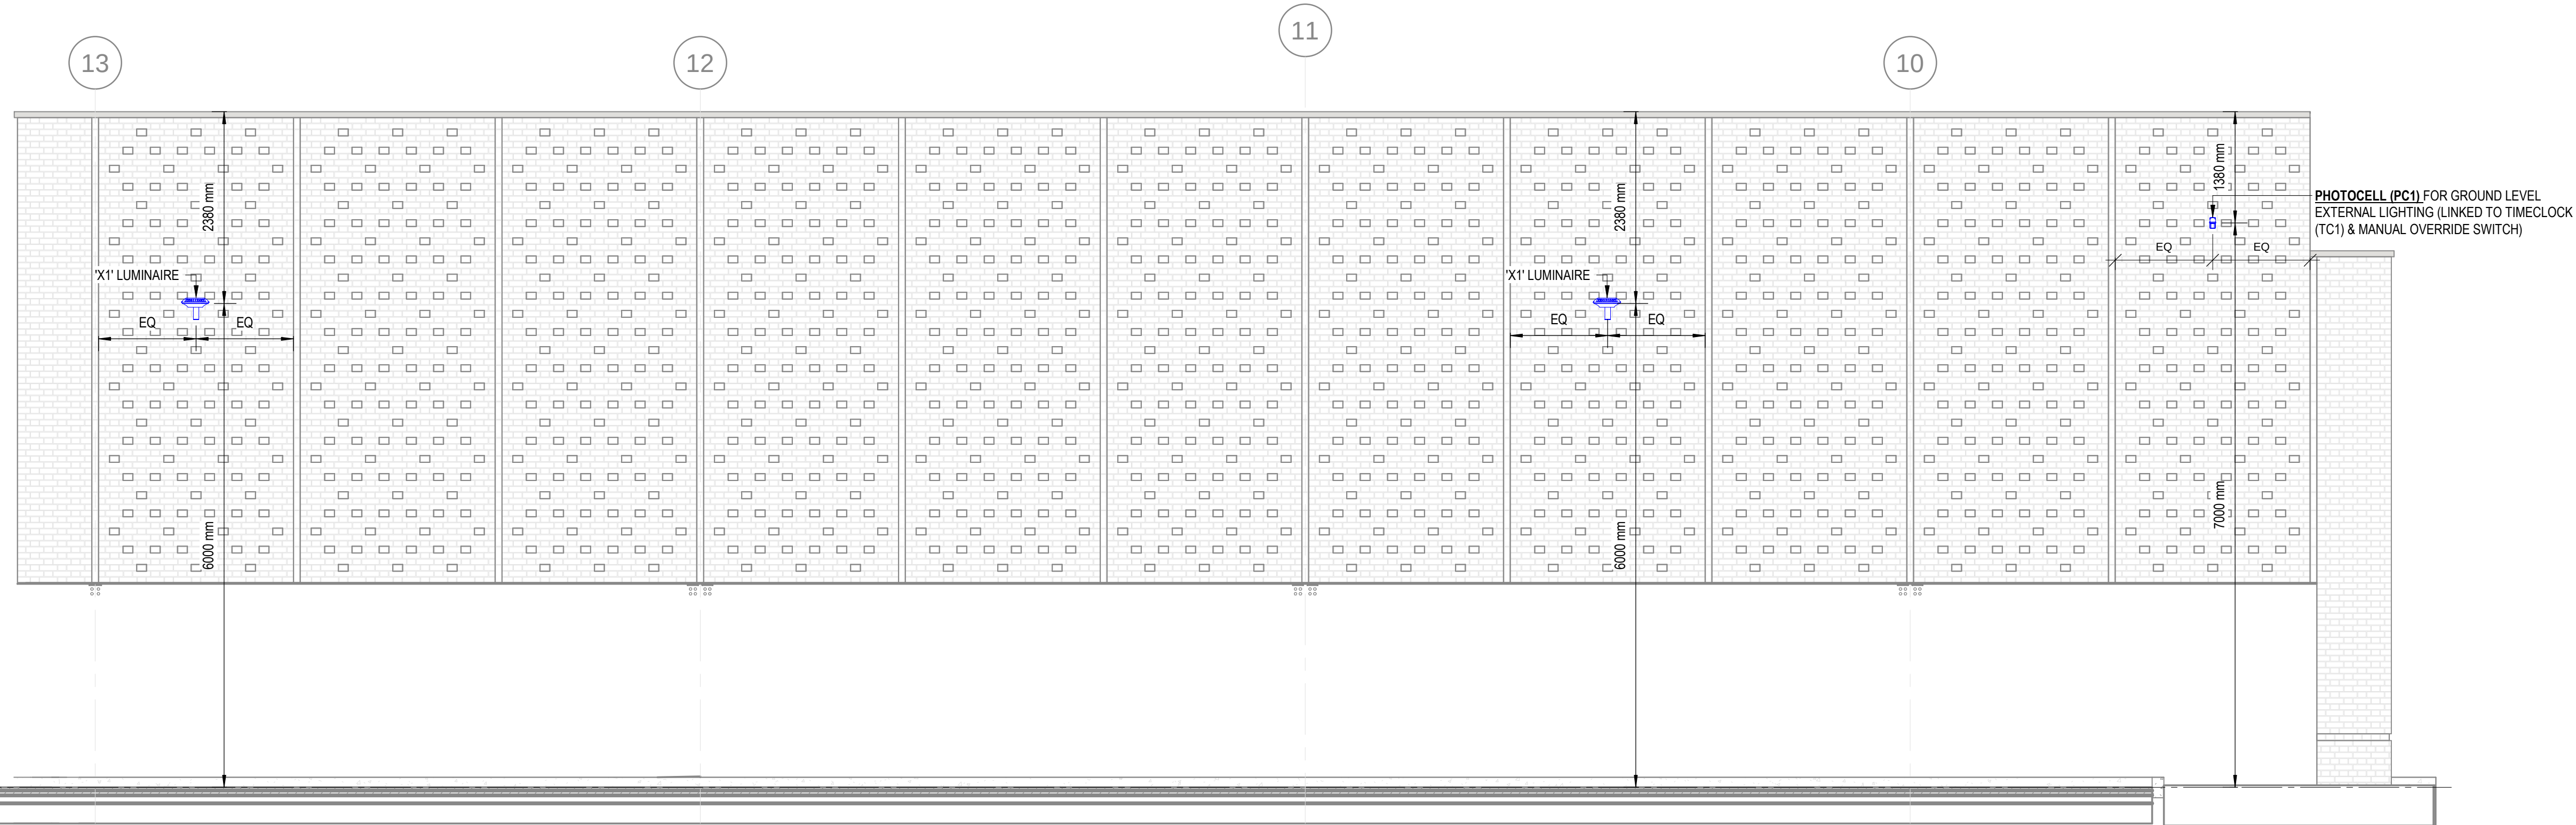

ELEVATION B-B EXTERNAL CAR PARK
WEST FACING ELEVATION (FACING HIGHFIELD ROAD)
REFER TO DRAWING REF
17300-247-P1-00-D-E-630000
FOR LIGHTING LAYOUT



ELEVATION G-G EXTERNAL CANOPY
SOUTH FACING ELEVATION (FACING FAIRFAX ROAD)
REFER TO DRAWING REF
17300-247-P1-00-D-E-630001
FOR LIGHTING LAYOUT

C02	EMERGENCY FLOODLIGHT & CENTRAL BATTERY SYSTEM ADDED	JD	JM	03/03/2025
C01	CONSTRUCTION ISSUE	JA	JM	24/12/2025
P01	PRELIMINARY ISSUE	JD	JM	14/10/2025
rev	description	dwn	chld	date

Status **CONSTRUCTION**

Client **VINCI BUILDING**

Architect/Proj **Jon Matthews Architects**

project **24-7 Group**
Unit 5, Cranford Drive, Knaresborough, Wetherby, W.A.S 16 82R
0161 8202047 | mail@24-7group.co.uk | www.24-7group.co.uk

PRESTWICH TRAVEL HUB

title **GROUND FLOOR
EXTERNAL ELEVATIONS**

project no.	drawn by	date	checked	scale
P010725	JD	SEPT 2025	JM	1:50 @ A0
drawing no.	revision			
17300-247-P1-00-D-E-630008				C02