


ELECTRICITY service into existing buildings., care must be taken when any excavation is taking place near these positions. Confirm position of electricity cables with Scottish Power [0151] 609 2394, before commencing on site, position of service cable to be marked on site, and also on copy of plans, once position of cable has

NOTE, Positions of proposed drainage runs and types of drainage indicated on drawings are provisional only, and may be altered to suit site conditions. Contractor to check invert & position of existing drainage systems to ensure adequate fall & to ensure BCO is satisfied with proposed drainage layout, fall and site inverts before excavation of drainage runs

WATER supply to be located & isolated prior to removal of any pipework, water supply pipe to be adequately protected from accidental / wilful damage at all times, contact United Utilities 0845 746 2200

GAS service into existing buildings., care must be taken when any excavation is taking place near these positions. Confirm position of gas supply pipe with Transco 01204 - 546900, before commencing on site, position of service pipe to be marked on site, and also on copy of plans, once position of pipe has been established. IN AN EMERGENCY CALL 0800 111999 IMMEDIATELY

Maintain any existing floor ventilation from the existing dwelling with 100mm dia PVC duct over / under new floor and extending telescopic air vents and air bricks with cavity trays over at maximum 1500mm centres. all vegetable strip to be removed from site of slab & ground to be treated were necessary with proprietary weedkiller

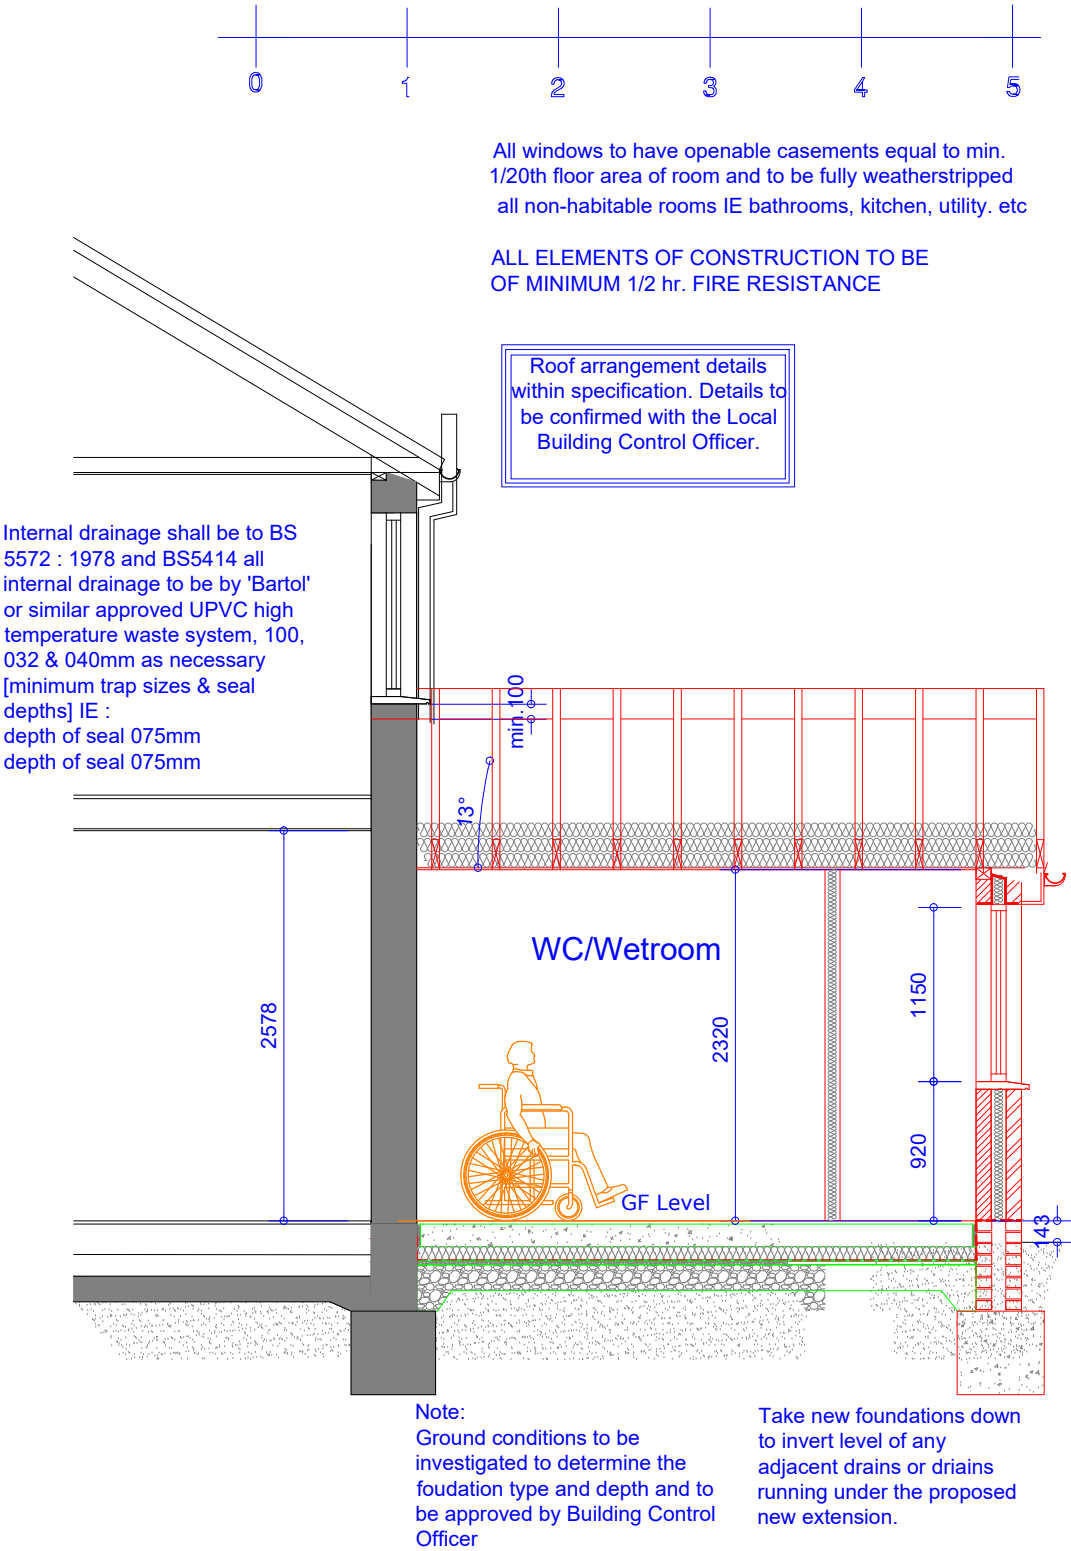

Proposed Section A-A
Scale 1:50

Rev	Date	Description
-----	------	-------------

Issued For : INFORMATION PURPOSES ONLY

Client
Mr. Richard Bawden - Sixtown Housing

Project
23 Lancaster Avenue, Whitefield. M45 6DX
Proposed single storey DDA rear extension.

Scheme - Drawing Title
Proposed Section.

04	Date	01.09.21
Drawing No.	Revision	Scale
		1:50 @A3



JK Technical Services (NW) Ltd
Tel: 0161 728 5730
Mob: 07741175755
www.jktechservs.co.uk