


ELECTRICITY service into existing buildings., care must be taken when any excavation is taking place near these positions. Confirm position of electricity cables with UK Power Networks (plans@ukpowernetworks.co.uk) before commencing on site, position of service cable to be marked on site, and also on copy of plans, once position of cable has

NOTE, Positions of proposed drainage runs and types of drainage indicated on drawings are provisional only, and may be altered to suit site conditions. Contractor to check invert & position of existing drainage systems to ensure adequate fall & to ensure BCO is satisfied with proposed drainage layout, fall and site inverts before excavation of drainage runs

WATER supply to be located & isolated prior to removal of any pipework, water supply pipe to be adequately protected from accidental / wilful damage at all times, contact United Utilities 0845 746 2200

GAS service into existing buildings., care must be taken when any excavation is taking place near these positions. Confirm position of gas supply pipe with Transco 01204 - 546900, before commencing on site, position of service pipe to be marked on site, and also on copy of plans, once position of pipe has been established. IN AN EMERGENCY CALL 0800 111999 IMMEDIATELY

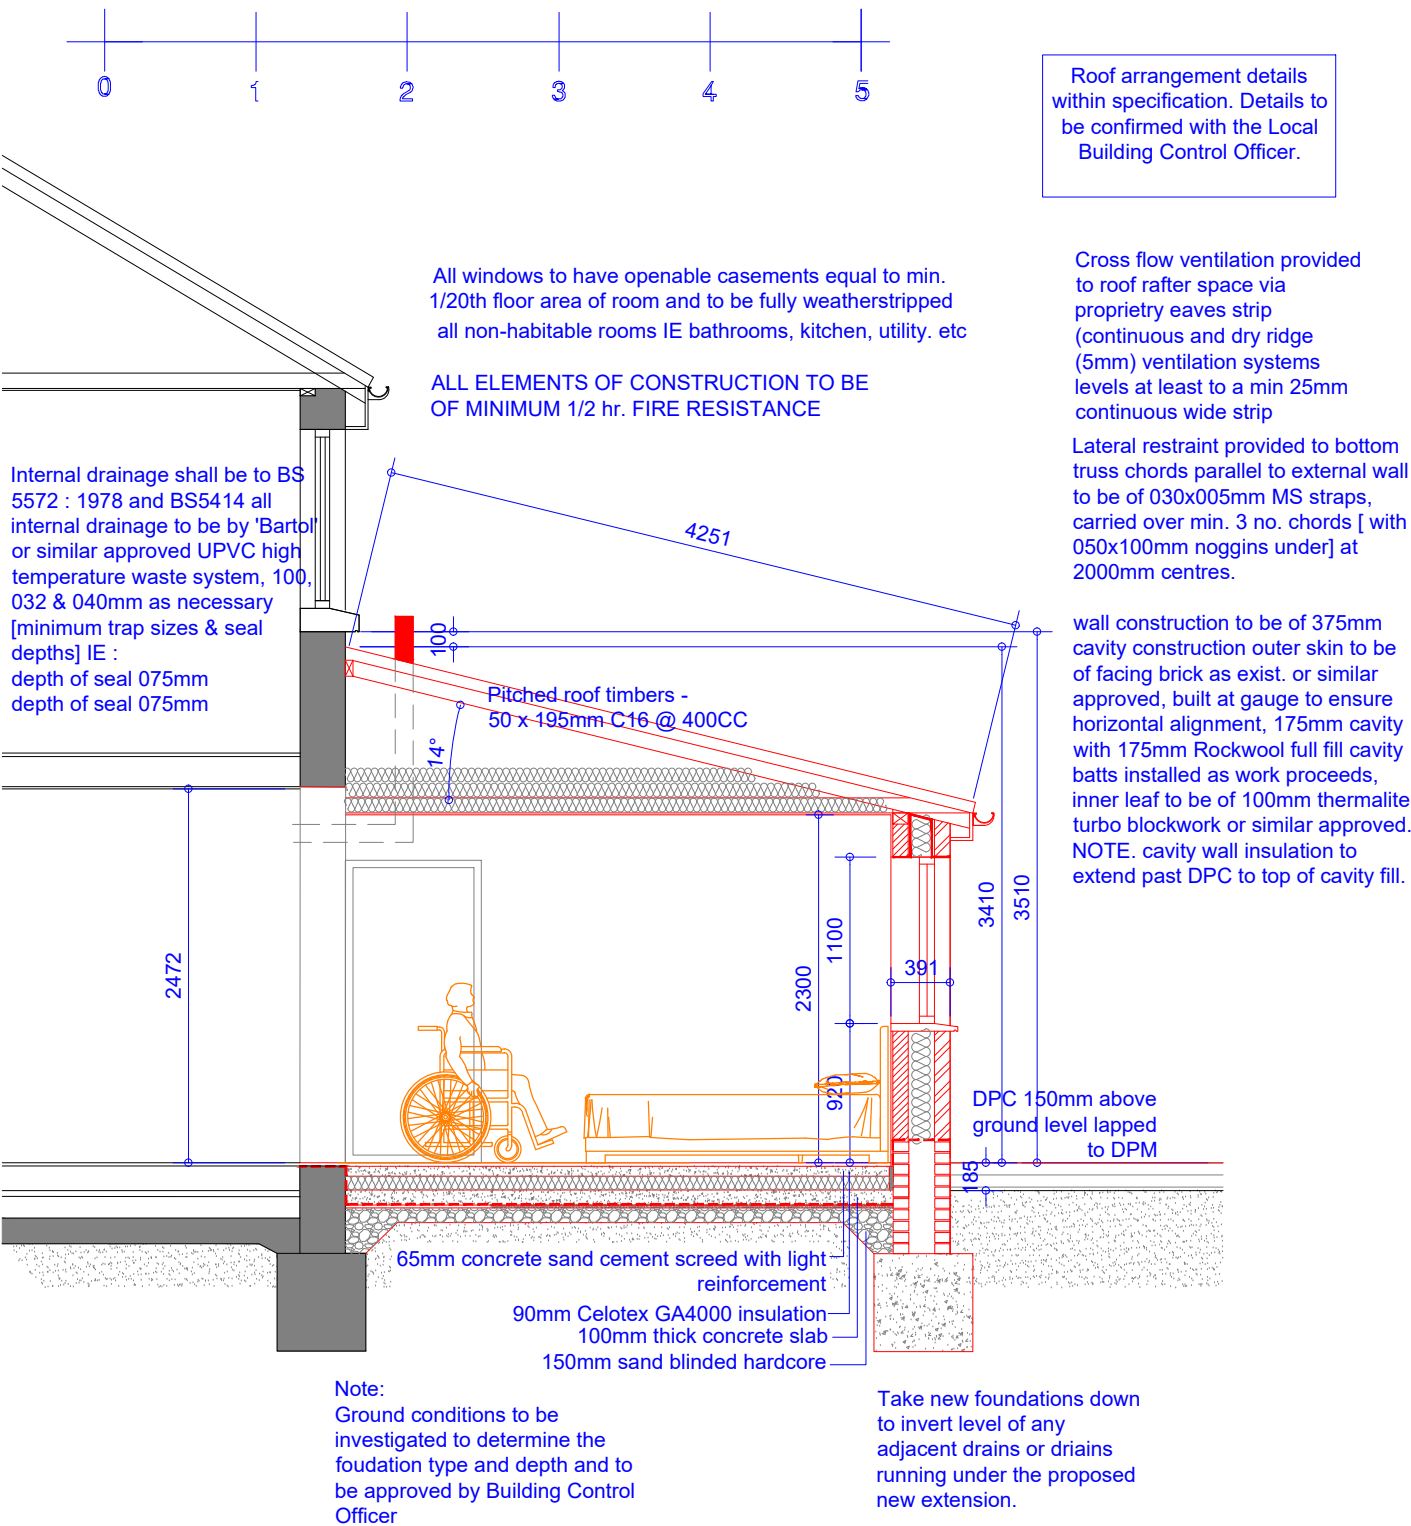

Proposed Section
Scale 1:50

Rev	Date	Description
-----	------	-------------

Issued For : INFORMATION PURPOSES ONLY

Client
Sixtown Housing

Project
61 Polefield Hall Road, Prestwich M25 2WW
Proposed single storey DDA rear extension.

Scheme - Drawing Title
Proposed Section.

04	Revision	Date	Scale
		15.06.22	1:50 @A3



JK Technical Services (NW) Ltd
Tel: 0161 728 5730
Mob: 07741175755
www.jktechservs.co.uk