


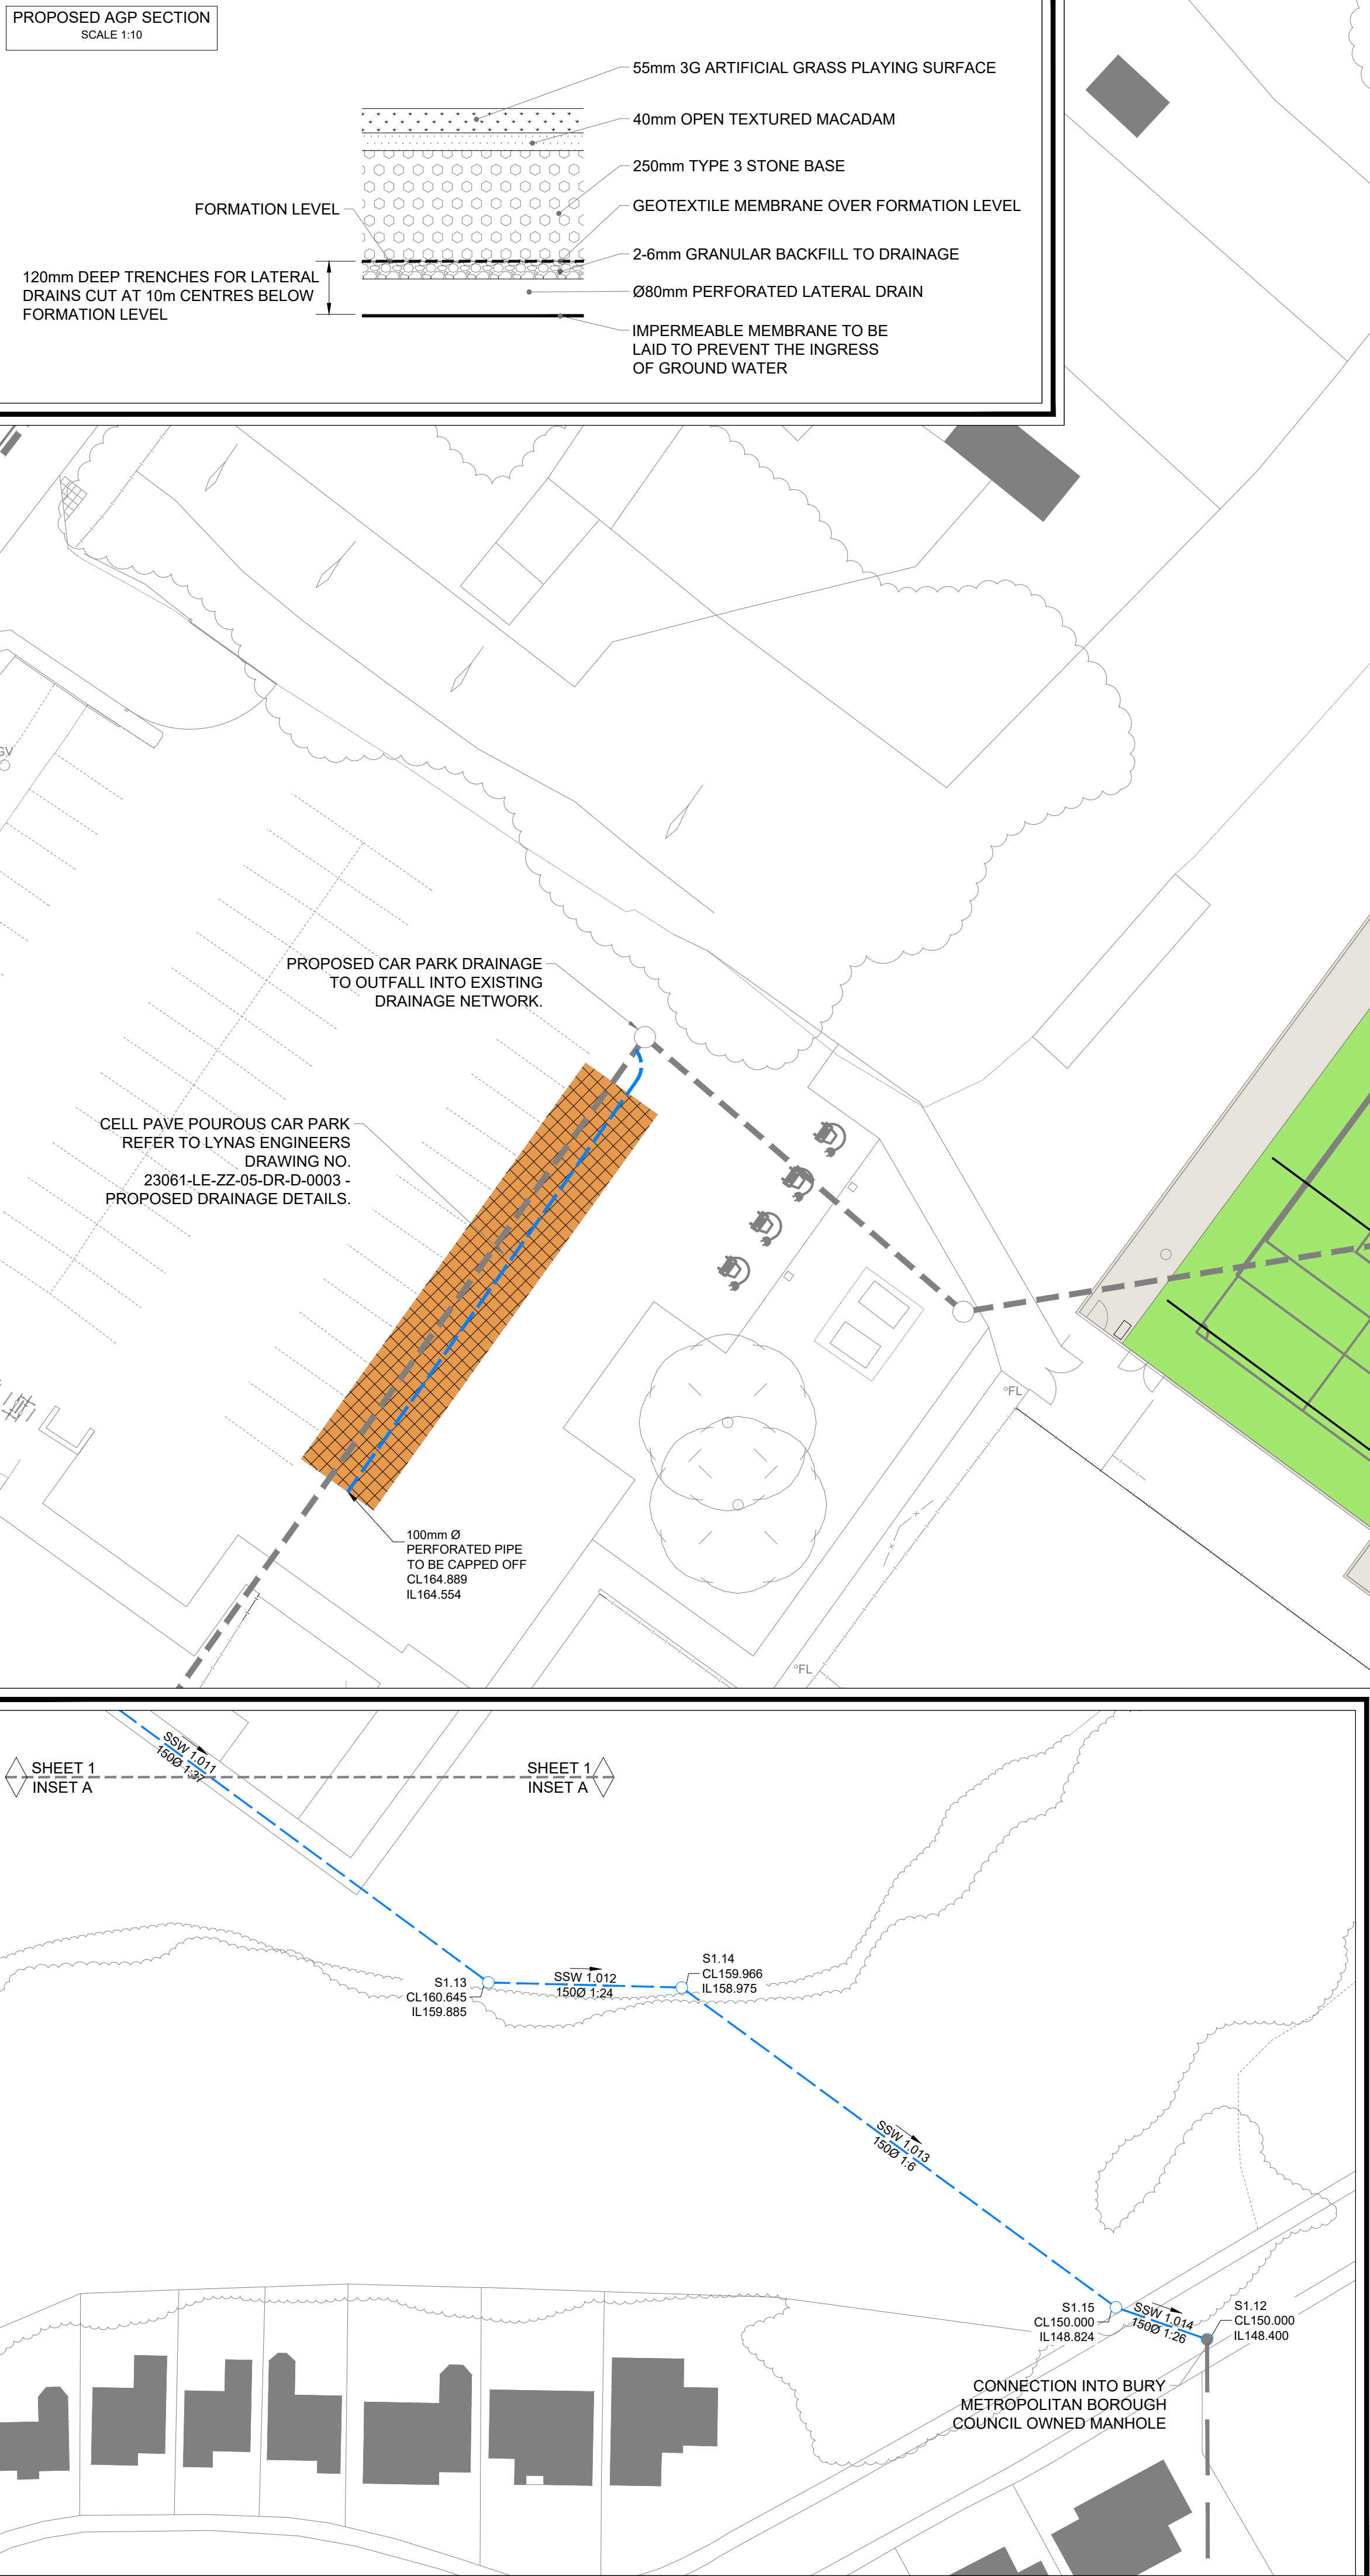

GENERAL NOTES:

- DRAWINGS ARE TO BE READ IN CONJUNCTION WITH ALL RELEVANT SPECIFICATIONS, ENGINEERS, ARCHITECTS & SERVICES DRAWINGS, INCLUDING APPROVED BUILDERS WORK DRAWINGS. CONTRACTOR TO NOTIFY ENGINEER OF DISCREPANCIES BETWEEN STRUCTURAL DRAWINGS AND SPECIFICATIONS OR OTHER DRAWINGS.
- DO NOT SCALE FROM THIS DRAWING. WORK TO DIMENSIONS OR CO-ORDINATES PROVIDED. ALL LEVELS ARE IN METRES AND ALL DIMENSIONS ARE IN MILLIMETRES, UNLESS OTHERWISE NOTED. ANY AMBIGUITIES, OMISSIONS AND ERRORS ON DRAWINGS, SHALL BE BROUGHT TO THE ENGINEERS ATTENTION IMMEDIATELY.

PROPOSED DRAINAGE KEY:

- AGP AREA
- CARRIER DRAIN (WITH JUNCTION)
- LATERAL DRAIN (WITH JUNCTION TO CARRIER DRAIN)
- MAIN DRAINAGE
- RODDING EYE
- POROUS CAR PARK

EXISTING DRAINAGE KEY:

- EXISTING DRAINAGE (LOCATION SHOWN INDICATIVELY)

DRAINAGE NOTES:

- PROPOSED AGP TO BE CONSTRUCTED WITH 250mm OF TYPE 3 CLEAN STONE BASE WITH 30% VOIDS.
- CARRIER DRAIN WILL BE A CONTINUOUS PIPE FROM PIPE S1.000-S1.010. INDIVIDUAL PIPES ARE SHOWN TO DISPLAY LATERAL DRAINAGE CONNECTIONS.
- FOR DRAINAGE DETAILS REFER TO LYNAS ENGINEERS DRAWING NO. 23061-LE-ZZ-05-DR-D-0003 - PROPOSED DRAINAGE DETAILS.
- FOR HYDROBRAKE DETAILS REFER TO LYNAS ENGINEERS DRAWING NO. 23061-LE-ZZ-05-DR-D-0004 - S1.14 HYDROBRAKE DETAILS.

S2	FOR INFORMATION	06.11.24	WF
S2	FOR INFORMATION	01.11.24	WF
S2	FOR INFORMATION	16.09.24	WF
S2	FOR INFORMATION	16.08.24	WF
S2	FOR INFORMATION	05.04.24	WF
S2	FOR INFORMATION	16.10.23	WF
S2	FOR INFORMATION	25.09.23	WF

Stat	Purpose of Issue	Date	Auth		
P07	DRAINAGE LAYOUT REVISED	MR	06.11.24	WF	WF
P06	DRAINAGE LAYOUT REVISED	MR	01.11.24	WF	WF
P05	DRAINAGE LAYOUT REVISED	MR	16.09.24	WF	WF
P04	UPDATED SECTION AS PER UU COMMENT	BJR	16.08.24	WF	WF
P03	DRAINAGE LAYOUT AMENDED	MR	05.04.24	WF	WF
P02	DRAINAGE LAYOUT AMENDED	MR	16.10.23	WF	WF
P01	FIRST ISSUE	MR	25.09.23	WF	WF

Rev	Description	By	Date	Chk'd	Auth

LYNAS ENGINEERS

Lynas Engineers
Wilton Centre
Redcar
TS10 4RF
Tel: +44 (0)1642 438273
www.lynasengineers.com

Copyright © Lynas Engineers Limited (2020)

Client

STEVE WELLS ASSOCIATES
making sport happen

Project

TOP PARK, BURY

Title

PROPOSED DRAINAGE LAYOUT

Sheet Size	Original Scale	Designed/Drawn	Checked	Authorised
A1	AS SHOWN	MR	WF	WF
Status	Drawing Number	Date	Date	Date
S2	23061-LE-ZZ-05-DR-D-0001	25.09.23	25.09.23	25.09.23
				Rev
				P07