


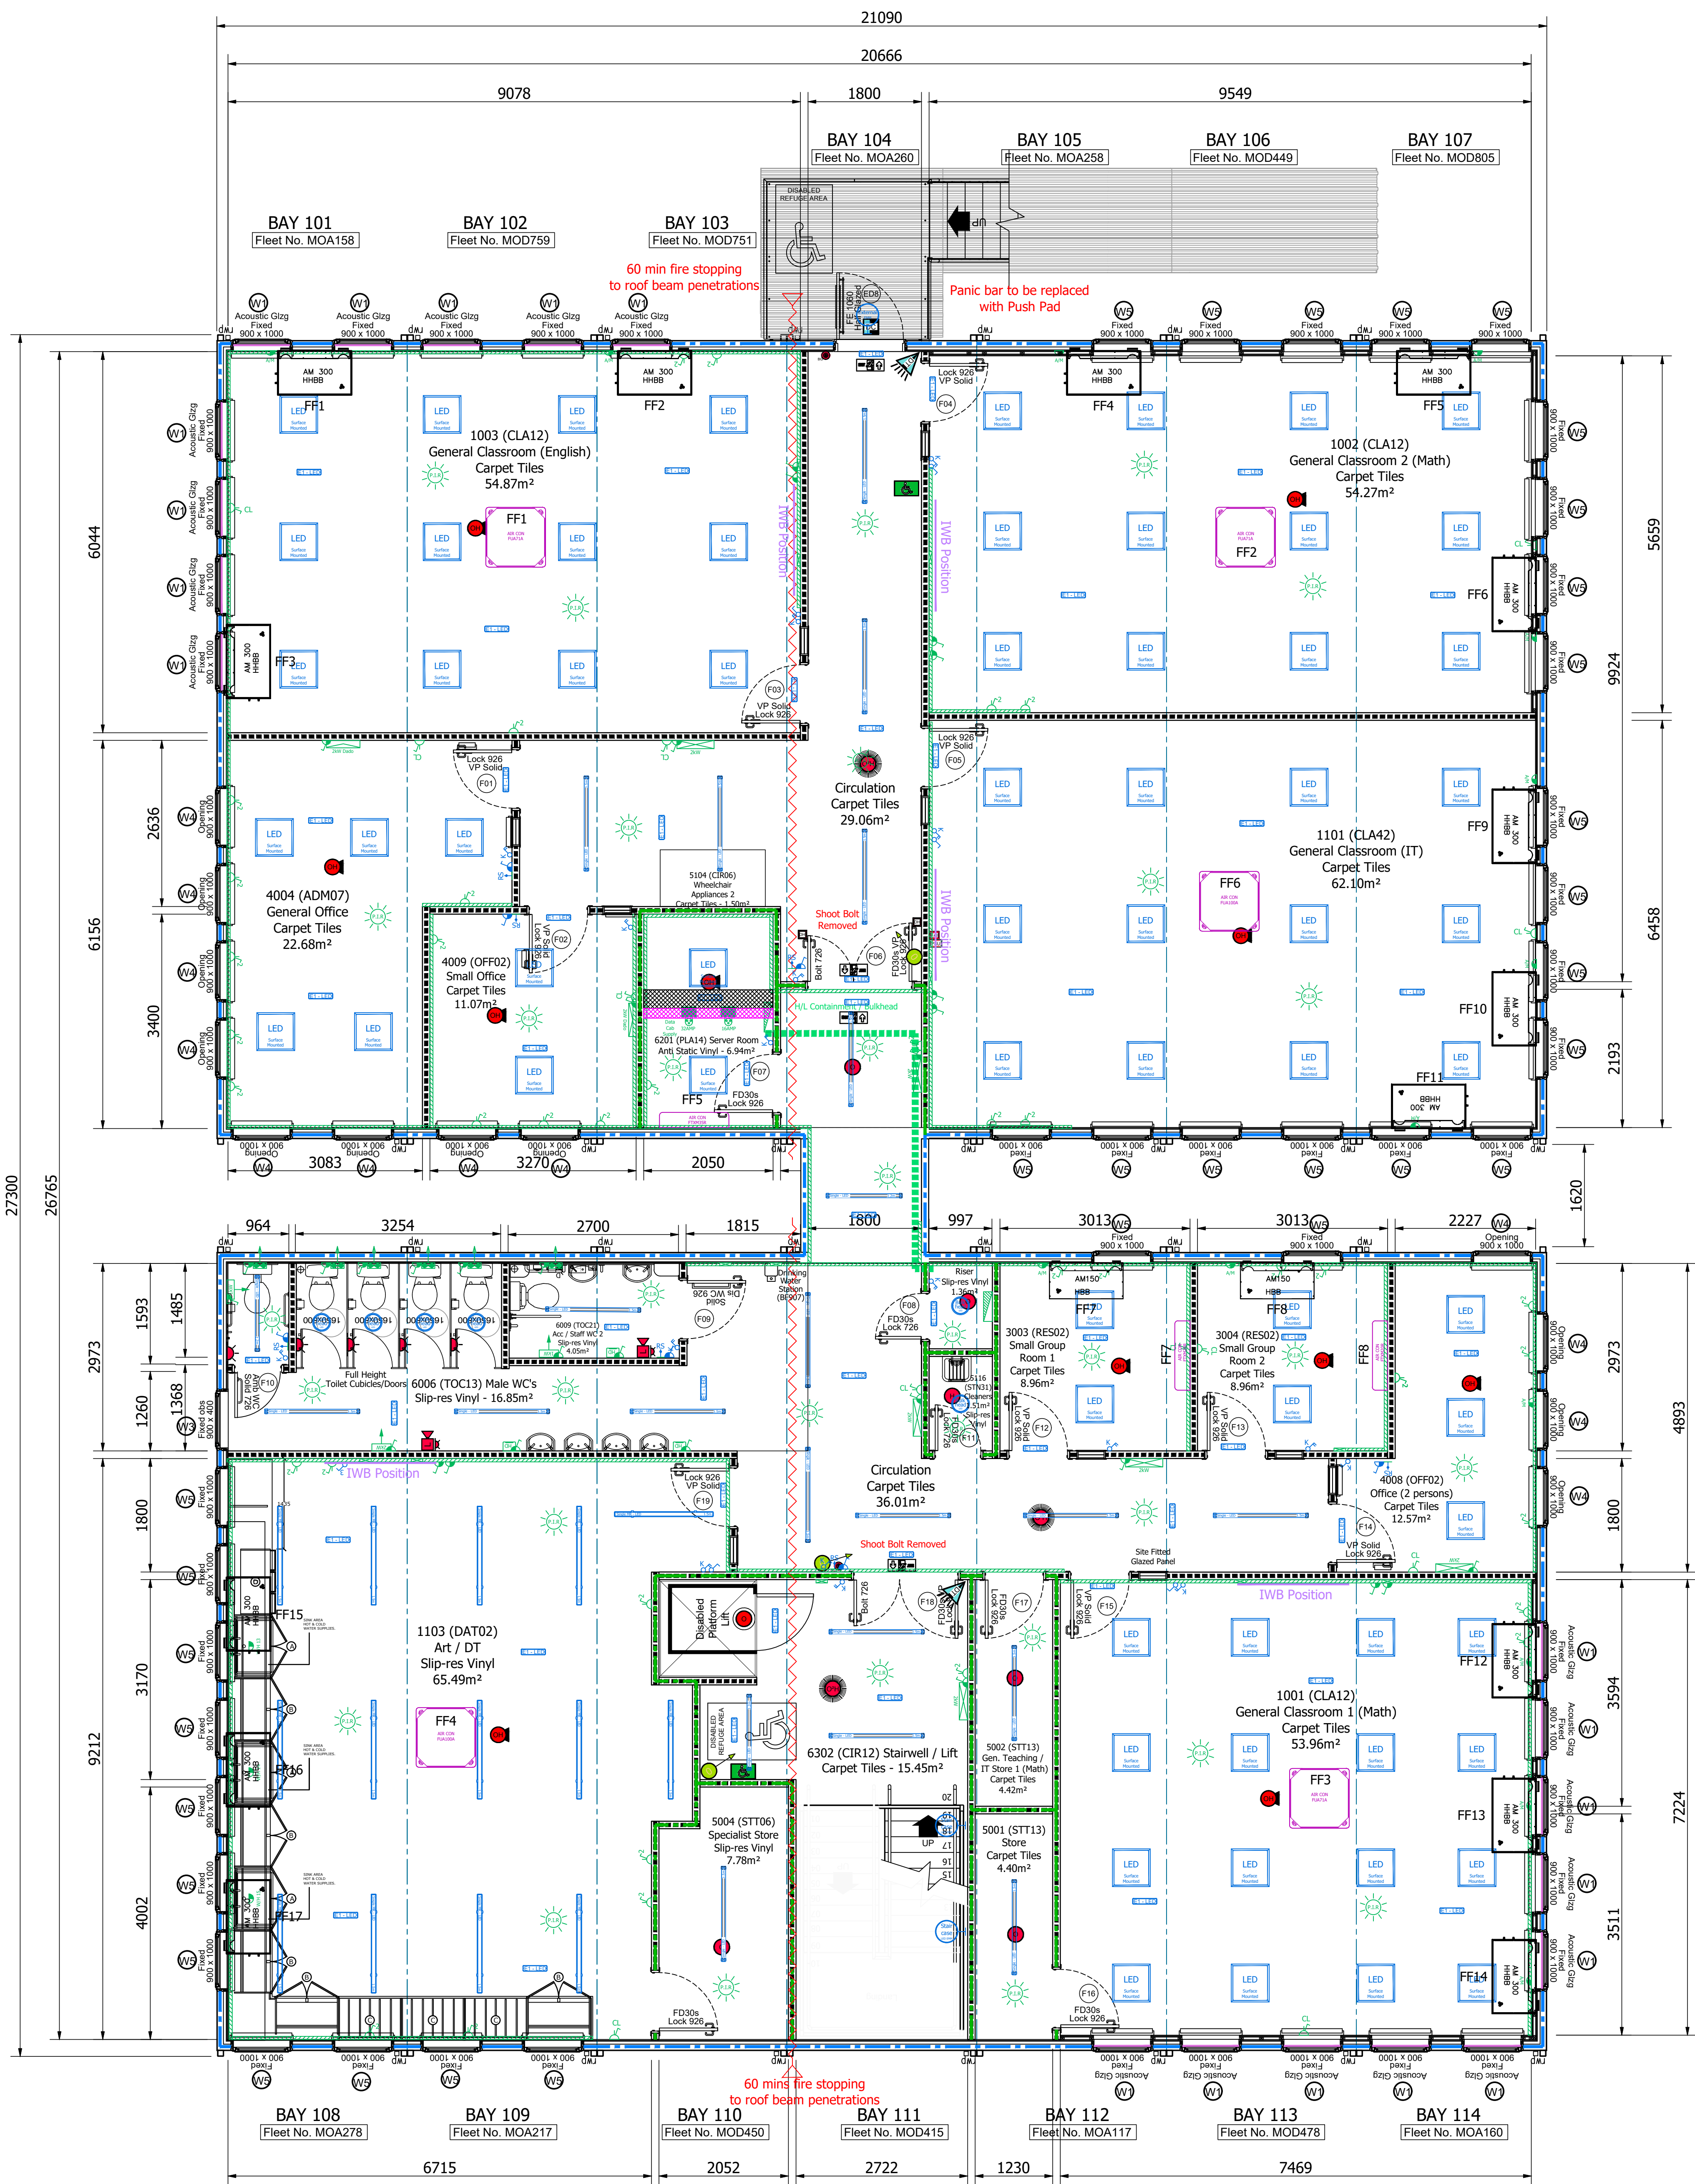

Note:
Fire alarm system indicative only.
CCTV & Control Access system indicative only.

Single Switched Socket Outlet	Type 'X' 51dB 120mm
Double Switched Socket Outlet	Type 'X' 56dB 145mm
Fused Spur	
Floor Box	
Panel Board	
Distribution Board	
2.2m Single LED Batten 17w	
1.2m Single LED Batten 28w	
3.5m Single LED Batten 34w	
Non Maintained EHM Light 3w	
Thorlux 4w rectangular bulkhead	
Thorlux Bar wide wall light	
Staircase Light 18w EHM	
Bulkhead Light 18w	
3 Compartment Trunking	
High Level Trunking 150mm x 150mm	
One Gang One Way Light Switch	
Key Switch	
PIR Detector	
External Switch	
Extract Fan	
Ceiling Mounted Extract Fan	
Internal Disabled Alarm	
External Disabled Alarm	
Disabled Alarm Reset	
Disabled Alarm Pull Switch	
Ramen Stat	
20W Connector Heater	
18W Downflow Heater	
20W Downflow Heater	
Hand Dryer	
Emergency Stop	

ACCESS CONTROL LEGEND	
ACCESS AUDIO INTERCOM OUTSTATION	0
ACCESS AUDIO INTERCOM RECEIVER	0
ACCESS AUDIO INTERCOM BATTERY	0
ACCESS CONTROL UNIT	1
ACCESS EM BKR GLASS	1
ACCESS FIRE ALARM INTERFACE	0
ACCESS KEYPAD PROX	0
ACCESS MAGLOCK	2
ACCESS MAGLOCK EXTERNAL	0
ACCESS PROXIMITY READER	1
ACCESS PUSH TO EXIT	0
ACCESS STRIKE LOCK	0
ACCESS VIDEO INTERCOM OUTSTATION	1
ACCESS VIDEO INTERCOM RECEIVER	1
BATTERY FAH	1
MANUAL OVERRIDE SWITCH	0
PAULOCK EXTERNAL	0
PAULOCK HANDLE	0
PROXIMITY READER EXT VIB	0

CCTV LEGEND	
CAMERA - ANTI LUGATURE	0
CAMERA ANPR	0
CAMERA VARIOFOCAL	0
CAMERA - L80	0
CAMERA - 360	0
CCTV 2.8MM TURRET CAMERA	6
CCTV 24 MONITOR	0
CCTV 4MM BULLET CAMERA	5
DIGITAL VIDEO RECORDER	0
NETWORK SWITCH 24PSE	0
NETWORK SWITCH 8PSE	0
NETWORK VIDEO RECORDER	0
DISABLED REFUGEE / WC ALARM LEGEND	
DISABLED REFUGEE POINT	2
DISABLED REFUGEE RECEIVER	0
DISABLED REFUGEE-EXT-FH	0
DISABLED WC ALARM	0
FIREMAN'S PHONE	0

PARTITION KEY

2x15mm Vinyl Megadeco + 90mm Steel Stud + Enhanced Insul

Type 'X' 56dB 145mm

(1x12.5 Plain PBoard + 1x15mm Vinyl Megadeco each side + 90mm Steel Stud + Enhanced Insul)

ESCAPE SIGNAGE KEY

1 = PROGRESS FORWARD FROM HERE

2 = PROGRESS TO THE LEFT OF HERE

3 = PROGRESS TO THE RIGHT OF HERE

4 = PROGRESS DOWN TO THE RIGHT OF HERE

5 = PROGRESS DOWN TO THE LEFT OF HERE

6 = IN THE EVENT OF A FIRE NOTICE TO BE POSTPONED NEXT TO ALL FIRE ALARM BREAK GLASS UNITS (SEE BELOW)

ESCAPE SIGNAGE LOCATION

STATUTORY FIRE NOTICE (210x300mm)

FIRE ACTION

If you discover a fire:
1. Raise the alarm and evacuate the premises.
2. If you have time, try to extinguish the fire using the appropriate fire extinguisher.
3. If you cannot extinguish the fire, evacuate the premises and wait for the fire service to arrive.
4. Do not use the lift or stairs.
5. Do not return to the building until you are told to do so.

FOR ALL FIRE ALARMS, SOUNDERS, BREAK GLASS UNITS ETC REFER TO ENGINEERS FIRE ALARM DRAWINGS.

FIRE ESCAPE SIGNAGE TO CONFORM TO BS 5449 PART 1. MAXIMUM VIEWING DISTANCE BETWEEN SIGNS TO BE 2m. SIGNS POSITIONED ON THE WALLS TO BE LOCATED BETWEEN 1.7 & 2.0m ABOVE FINISHED FLOOR LEVEL. SIGNS SUSPENDED FROM CEILING AND SIGNS ABOVE 2.5m HIGH ARE NOT TO BE OBSERVED AND INCONSPICUOUS. IF THIS IS THE CASE THERE ARE TO BE ADDITIONAL SIGNS PROVIDED TO ENSURE FULL AWARENESS OF ESCAPE ROUTES.

FURNITURE KEY:

A - DOUBLE SINK BASE CUPBOARD WITH 1 FIXED SHELF, NO CENTRE POST AND LOW LEVEL BACK, 1000mm WIDTH, DEPTH & HEIGHT TO SUIT WORKTOP. 432mm INTERNAL DEPTH

A1 & 2 - DOUBLE SINK BASE CUPBOARD WITH 1 ADJUSTABLE SHELF, 1000mm WIDTH, DEPTH & HEIGHT TO SUIT WORKTOP. 432mm INTERNAL DEPTH

B - DOUBLE SINK BASE CUPBOARD WITH 1 ADJUSTABLE SHELF, 1000mm WIDTH, DEPTH & HEIGHT TO SUIT WORKTOP. 432mm INTERNAL DEPTH

C - VERTICAL STORAGE UNIT, WITH 6 EQUAL SIZED BAYS. 1000mm WIDTH, DEPTH & HEIGHT TO SUIT WORKTOP

D - TRIPLE TRAY UNIT, INCLUDES 18NR SHALLOW GRATNELL TRAYS. 1042mm WIDTH, DEPTH & HEIGHT TO SUIT WORKTOP

E - SINGLE BASE CUPBOARD WITH 1 ADJUSTABLE SHELF, 500mm WIDTH, DEPTH & HEIGHT TO SUIT WORKTOP. 432mm INTERNAL DEPTH

F - SINGLE SINK BASE CUPBOARD WITH 1 ADJUSTABLE SHELF, 500mm WIDTH, DEPTH & HEIGHT TO SUIT WORKTOP. 432mm INTERNAL DEPTH

G - 4 DRAWER BASE UNIT, TOP DRAWER LOCKABLE. 500mm WIDTH, DEPTH & HEIGHT TO SUIT WORKTOP

H - SERVICE BOLLARD, 600MM WIDTH, 600mm DEPTH, 850mm HEIGHT. ALL FITTINGS TO BE WORKTOP MOUNTED. INCLUDES 4 TWIN GAS OUTLETS & 4 DOUBLE, 2 SINGLE PEDESTAL BOXES

- BENCH MOUNTED BACK BOX FOR DATA
- FIXED SWANNECK LAB TAP WITH REMOVABLE NOZZLE AND BACK FLOW PREVENTION SYSTEM
- BENCH MOUNTED ELECTRICAL BOX. FACE PLATE BY OTHERS
- BENCH MOUNTED DOUBLE GAS TAP


Room Occupancy	
Room ID	Occupancy
1103 - Art/DT Classroom	30+1
1101 - General Classroom (IT)	30+1
1001 - General Classroom 1 (maths)	30+1
1002 - General Classroom 2 (maths)	30+1
1003 - General Classroom 3 (English)	30+1
4004 - General Office	5
4009 - Small Office	2
4008 - 2 Persons Office	2
3003 - Small Group Room 1	2+1
3004 - Small Group Room 2	2+1

FIRE STRATEGY KEY

1/2 Hour Fire Rated Partitions & Doors

1 Hour Fire Rated Partitions (Excludes Glazing & Doors)

1 Hour Fire Rating (In To Out) External Perimeter Walls (Excludes Windows & Doors)

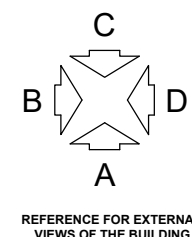

First Issue

Rev	Description	By	Date	Appr
1	Revision	BJP	28.07.23	28.07.23

General Notes

This drawing and any information or descriptive matter set herein is the confidential property of Algeco and must not be disclosed, copied or used for manufacturing, marketing or any other purpose without the prior consent in writing of Algeco.

All dimensions are in millimetres.

algeco

www.algeco.co.uk

Algeco - Modular Buildings, Heavy Duty, Prefabricated, HSA HAF for B1131 50/70, for B1131 50/70

Client: Morgan Sindell Construction & Infrastructure Ltd

Project: Temporary School Accommodation Star Academy Series 2000 - Project No. L230147

Drawn By: EL Drawn Date: 28.07.23 Drawn By: BJP Drawn Date: 28.07.23

Scale: 1:50 Sheet Size: A0 Sheet Number: 1 of 1

Drawing Title: 29 No. Bays 12.0 x 3.0m 2.4m Ceiling Height Plan Layout - First Floor

Drawing Number: FS1013-ALG-02-01-D-0-0102 P01