


Survey by Chris Partington Land Surveyors
and reproduced with their permission.

EVCPI Electric Vehicle Charge Point

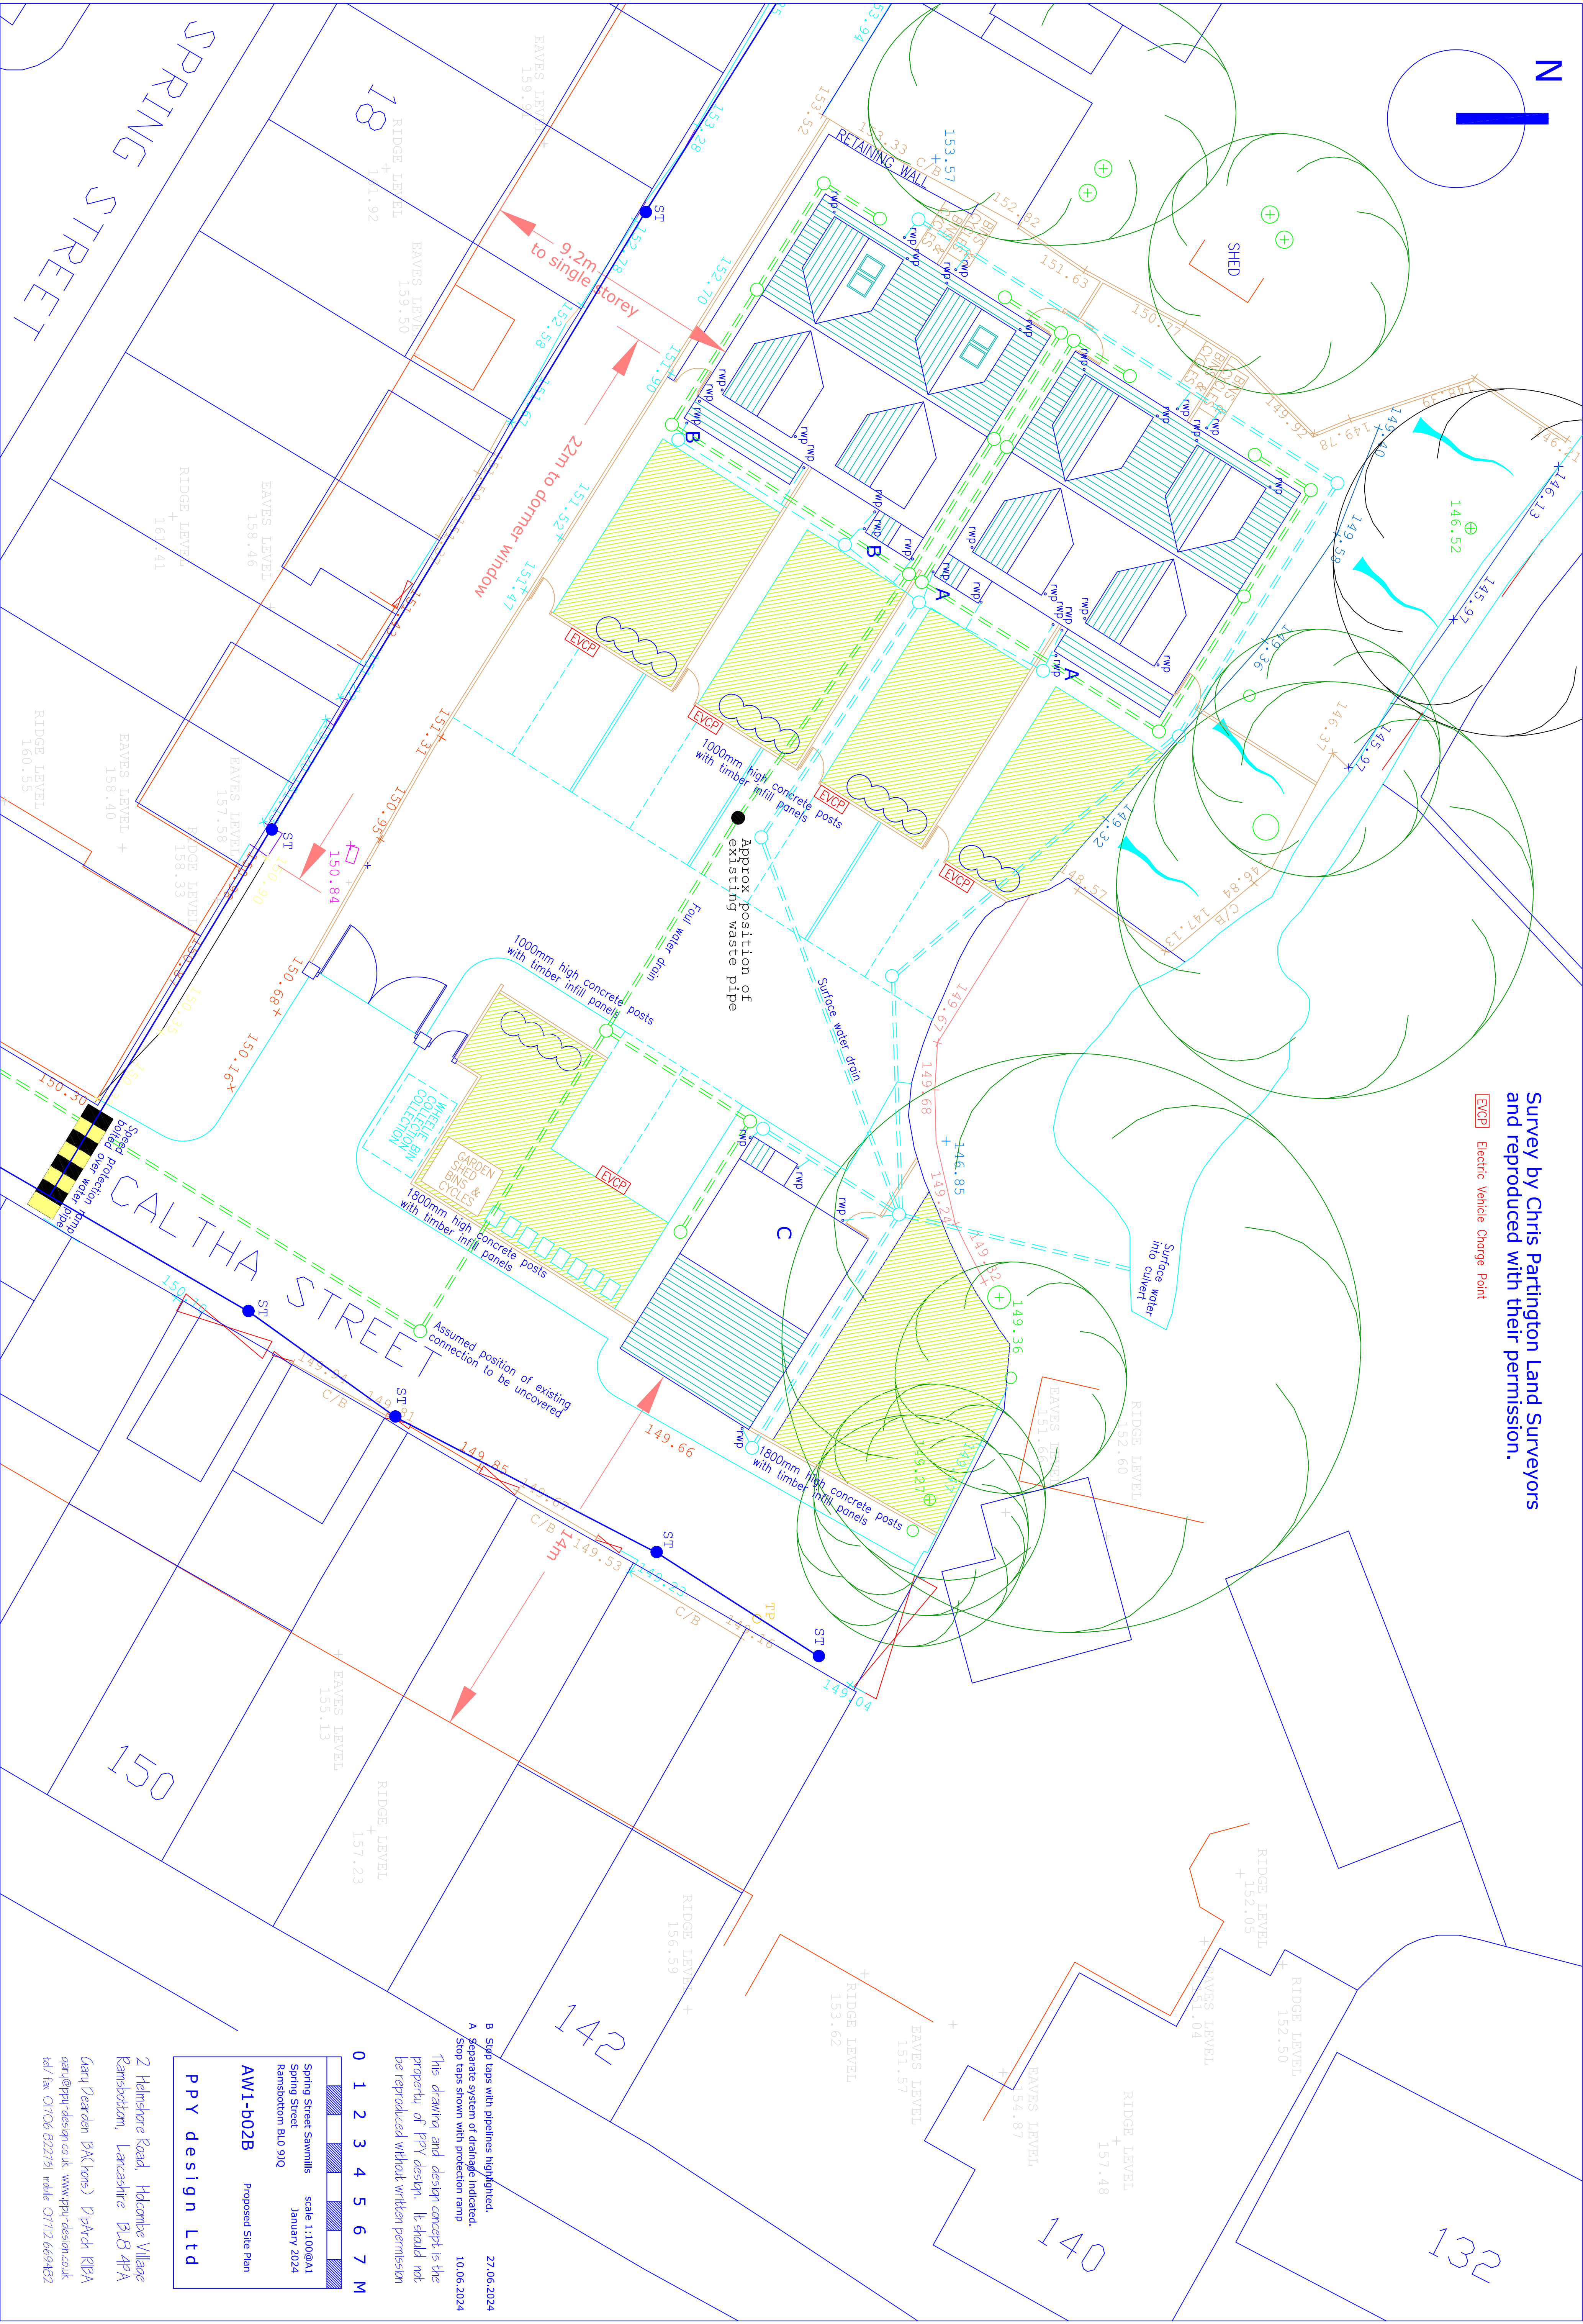

27.06.2024
B. Stop taps with pipelines highlighted.
A. Separate system of drainage indicated.
Stop taps shown with protection ramp. 10.06.2024
This drawing and design concept is the property of PPY design. It should not be reproduced without written permission

0 1 2 3 4 5 6 7 M
Spring Street Sawmills scale 1:100@A1
January 2024
Ramsbottom BL0 9JQ
AW1-b02B Proposed Site Plan
PPY design Ltd

2 Helmshore Road, Helmshore Village
Ramsbottom, Lancashire BL8 4PA
Gary Dearden B&K Home DYP&CH K13A
gdm@ppy-design.co.uk www.ppy-design.co.uk
tel / fax 01706 822773 mobile 07172 669482