
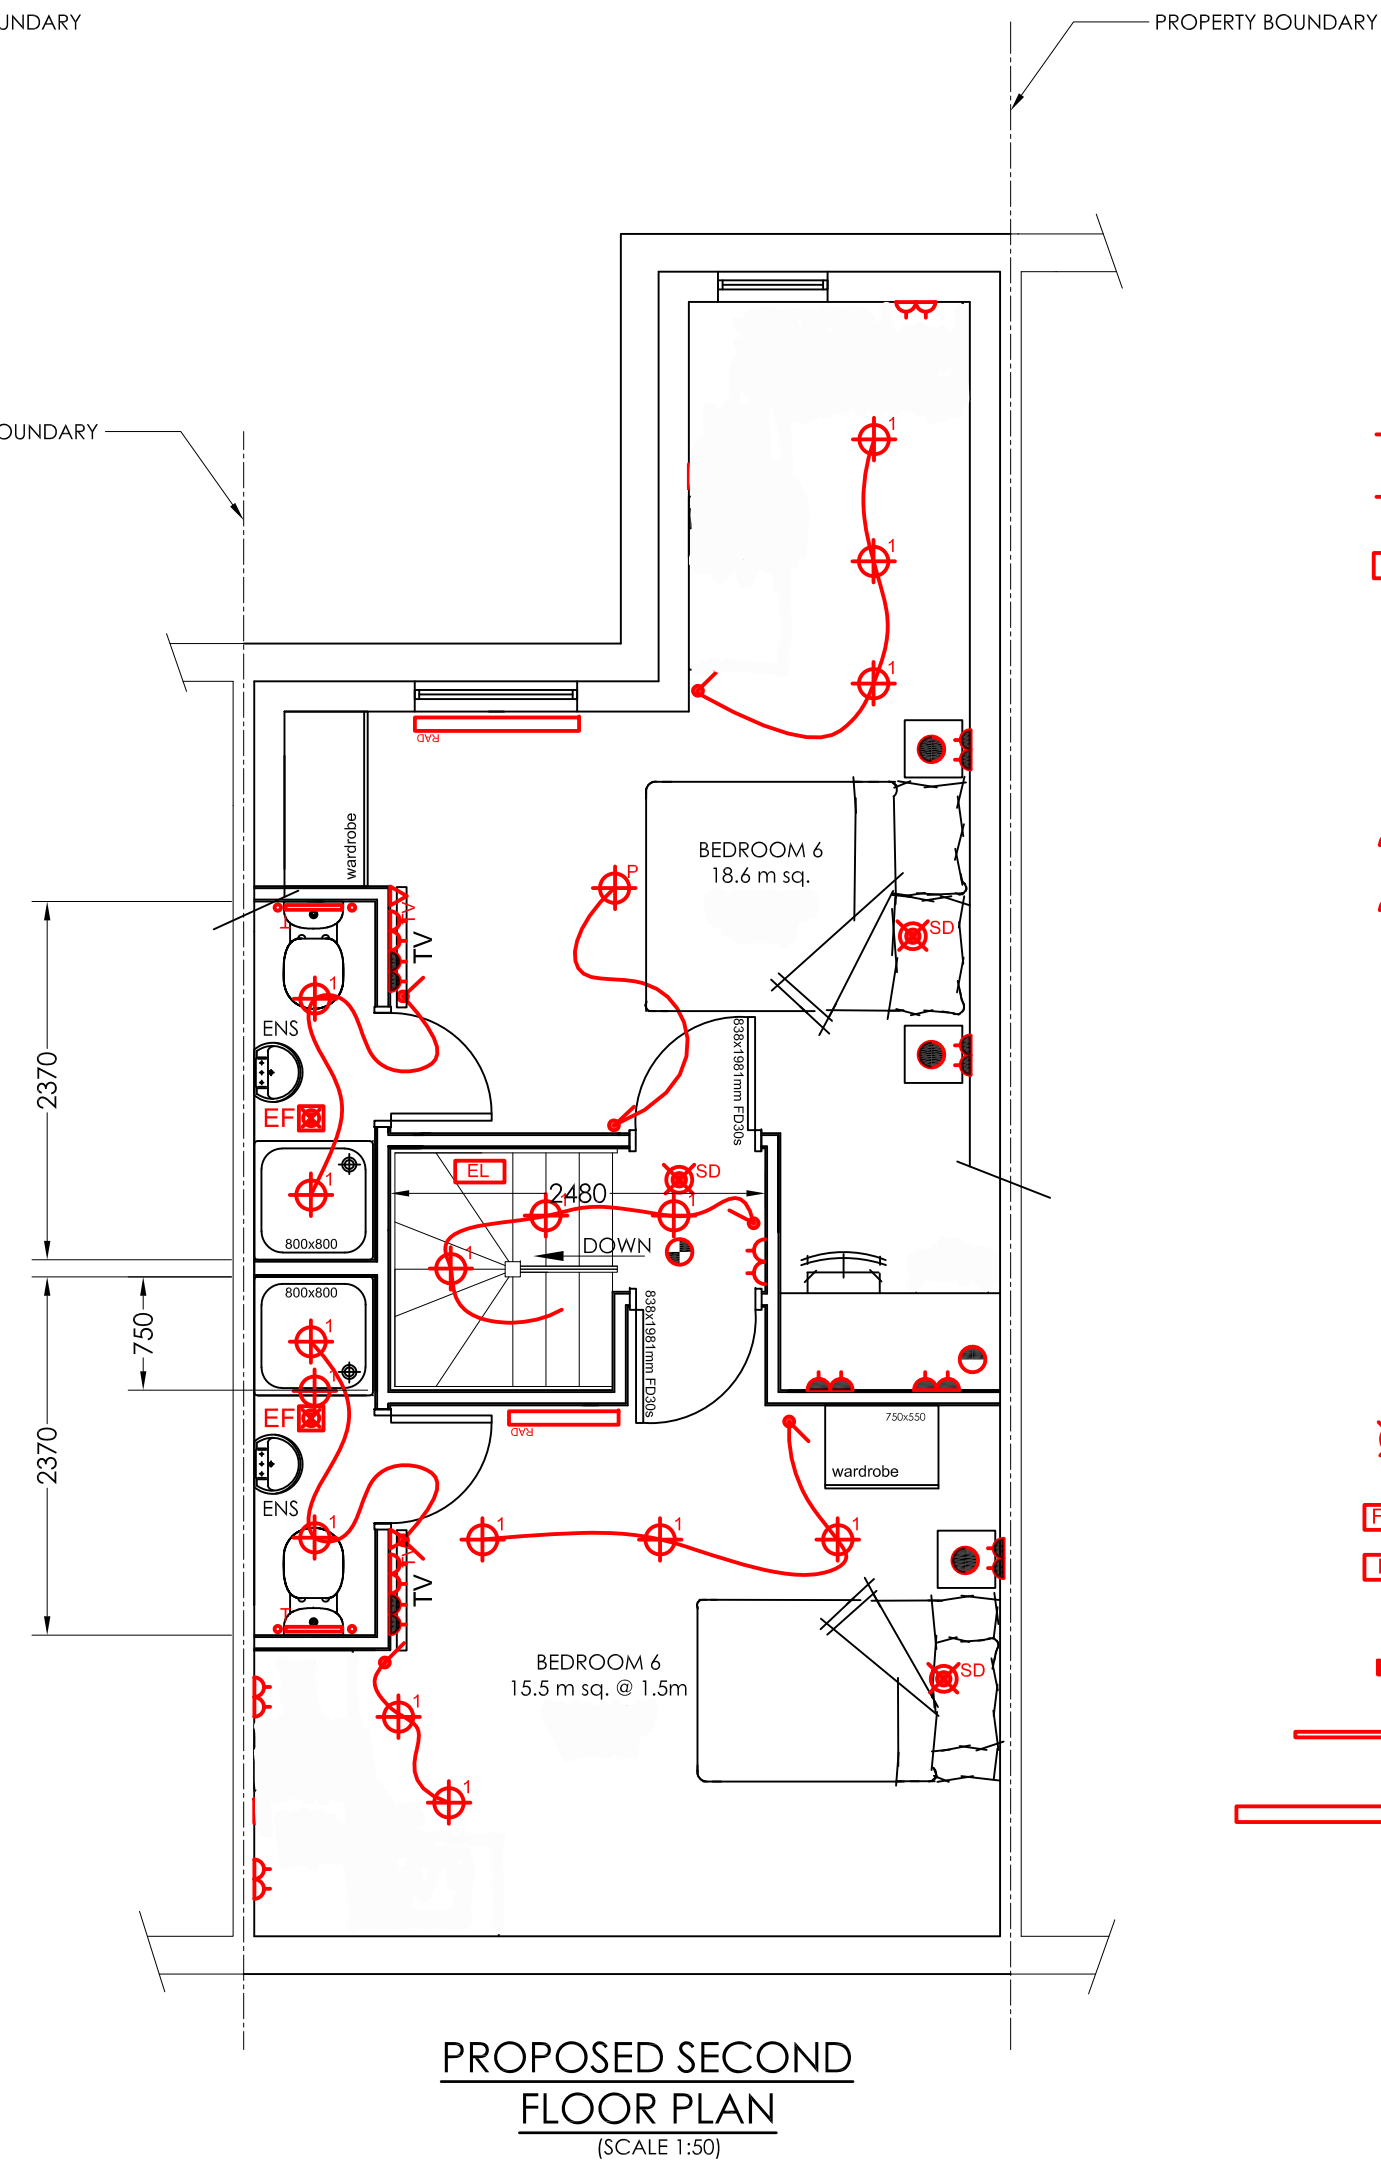
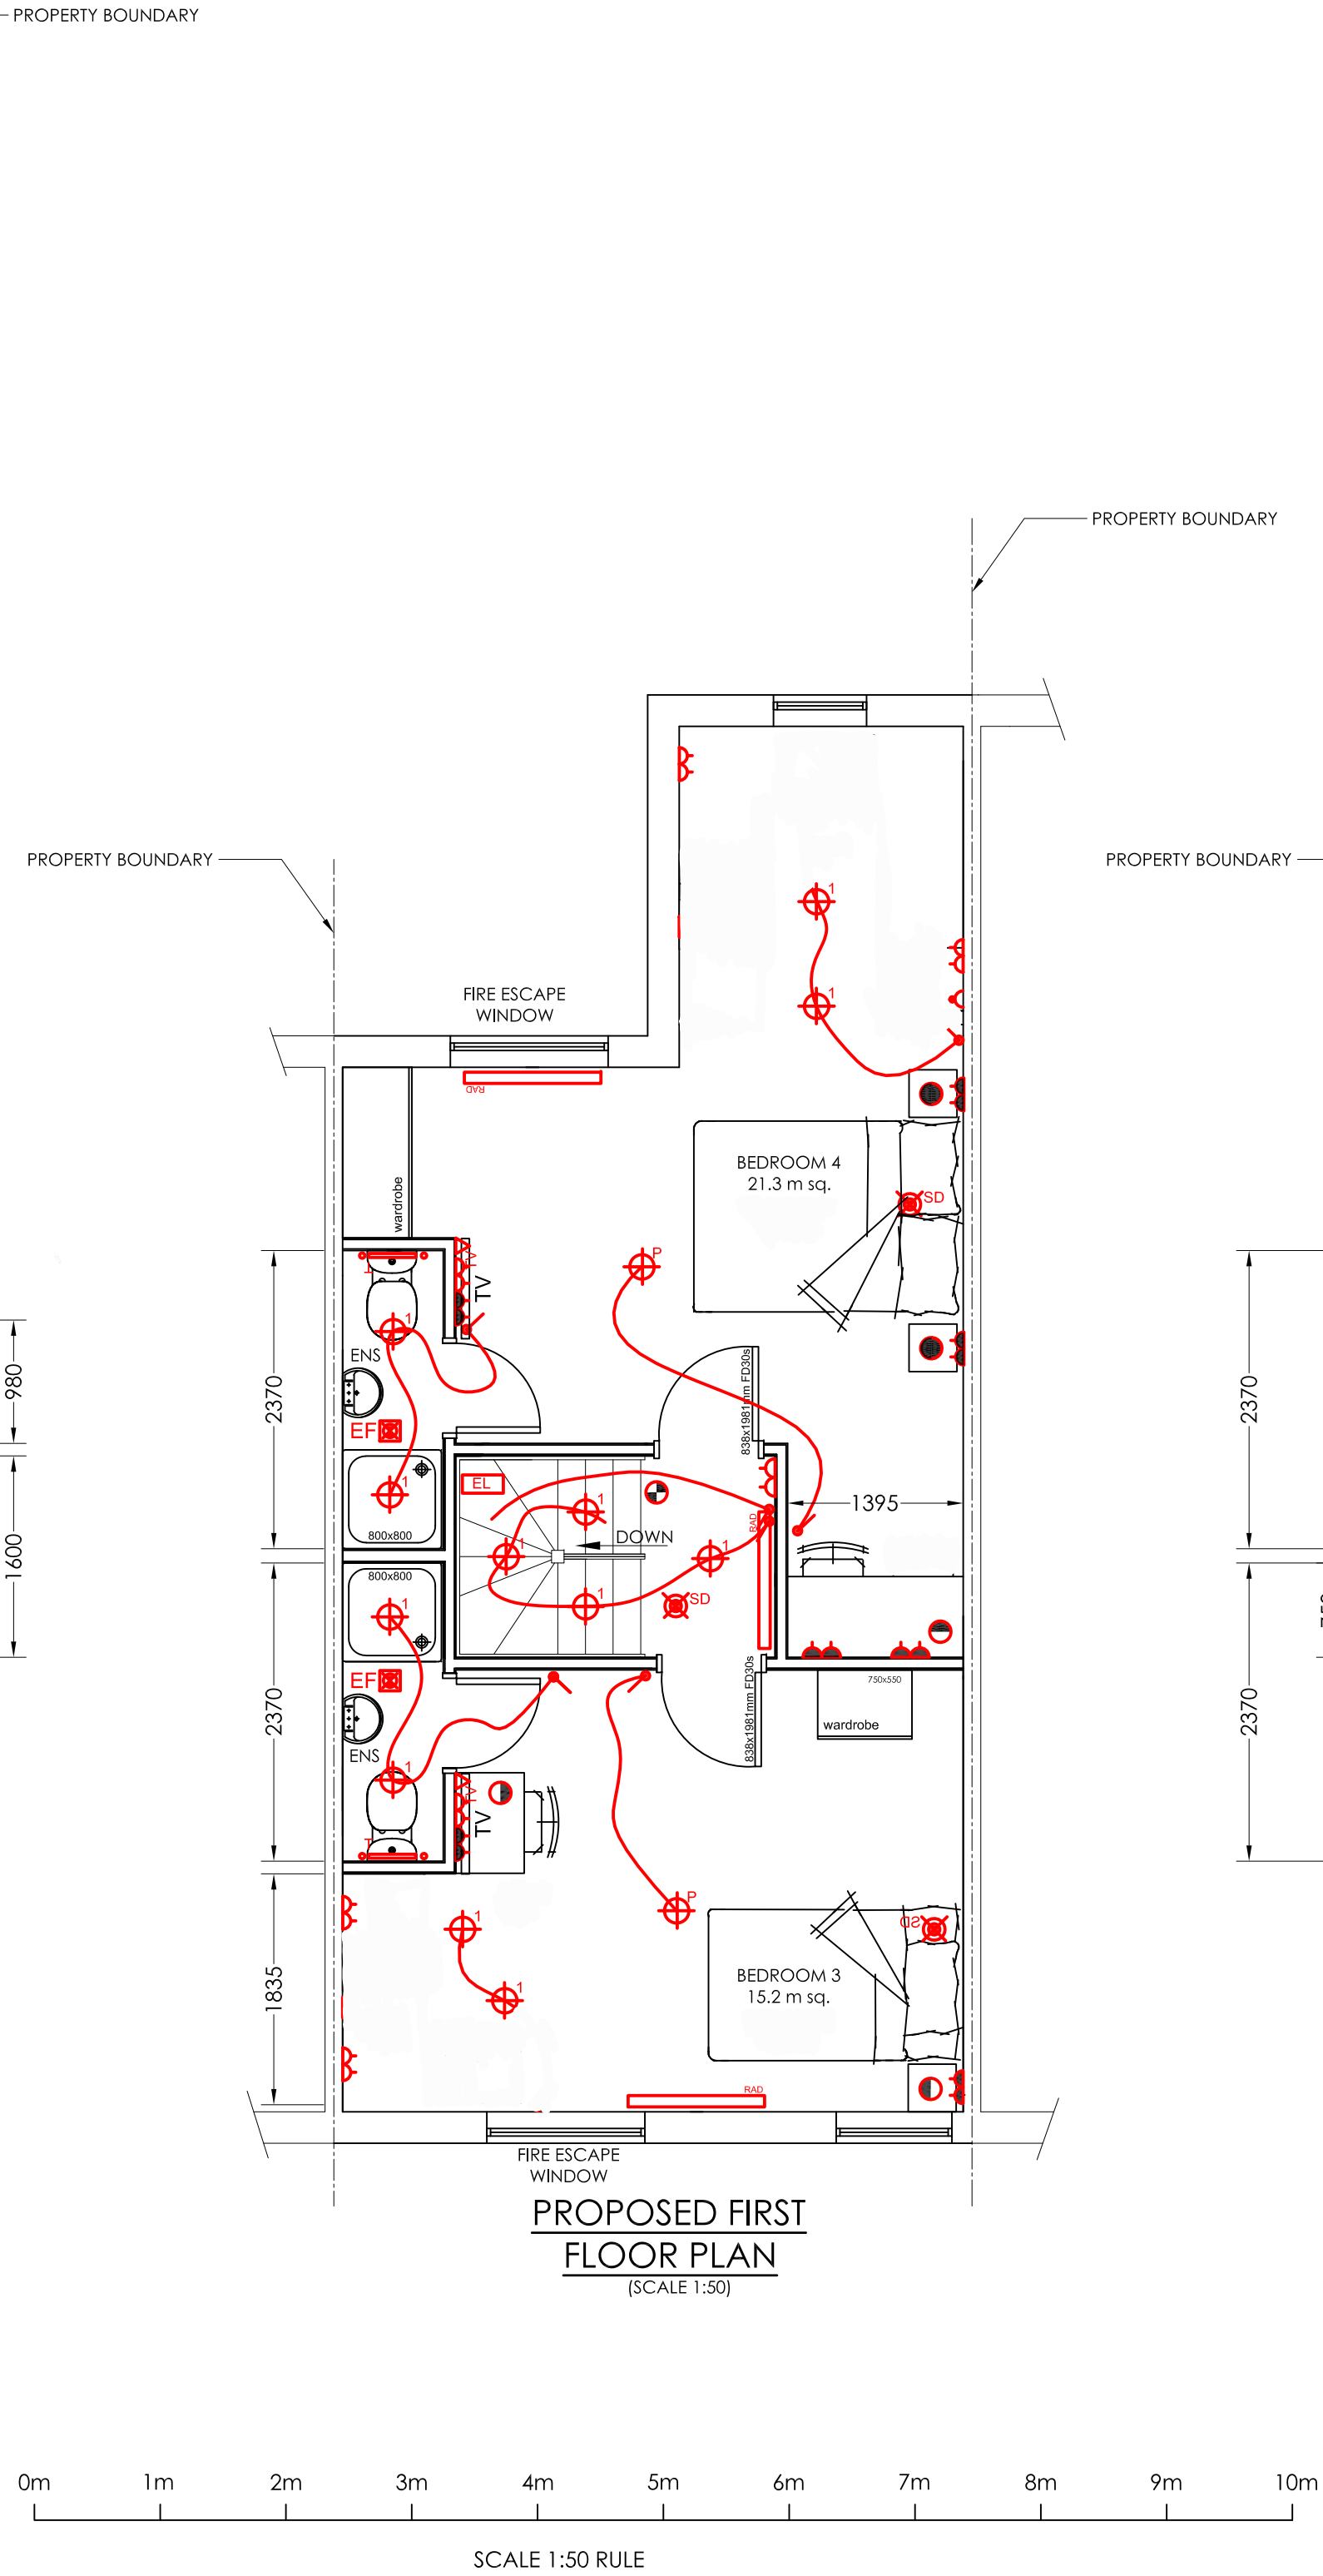


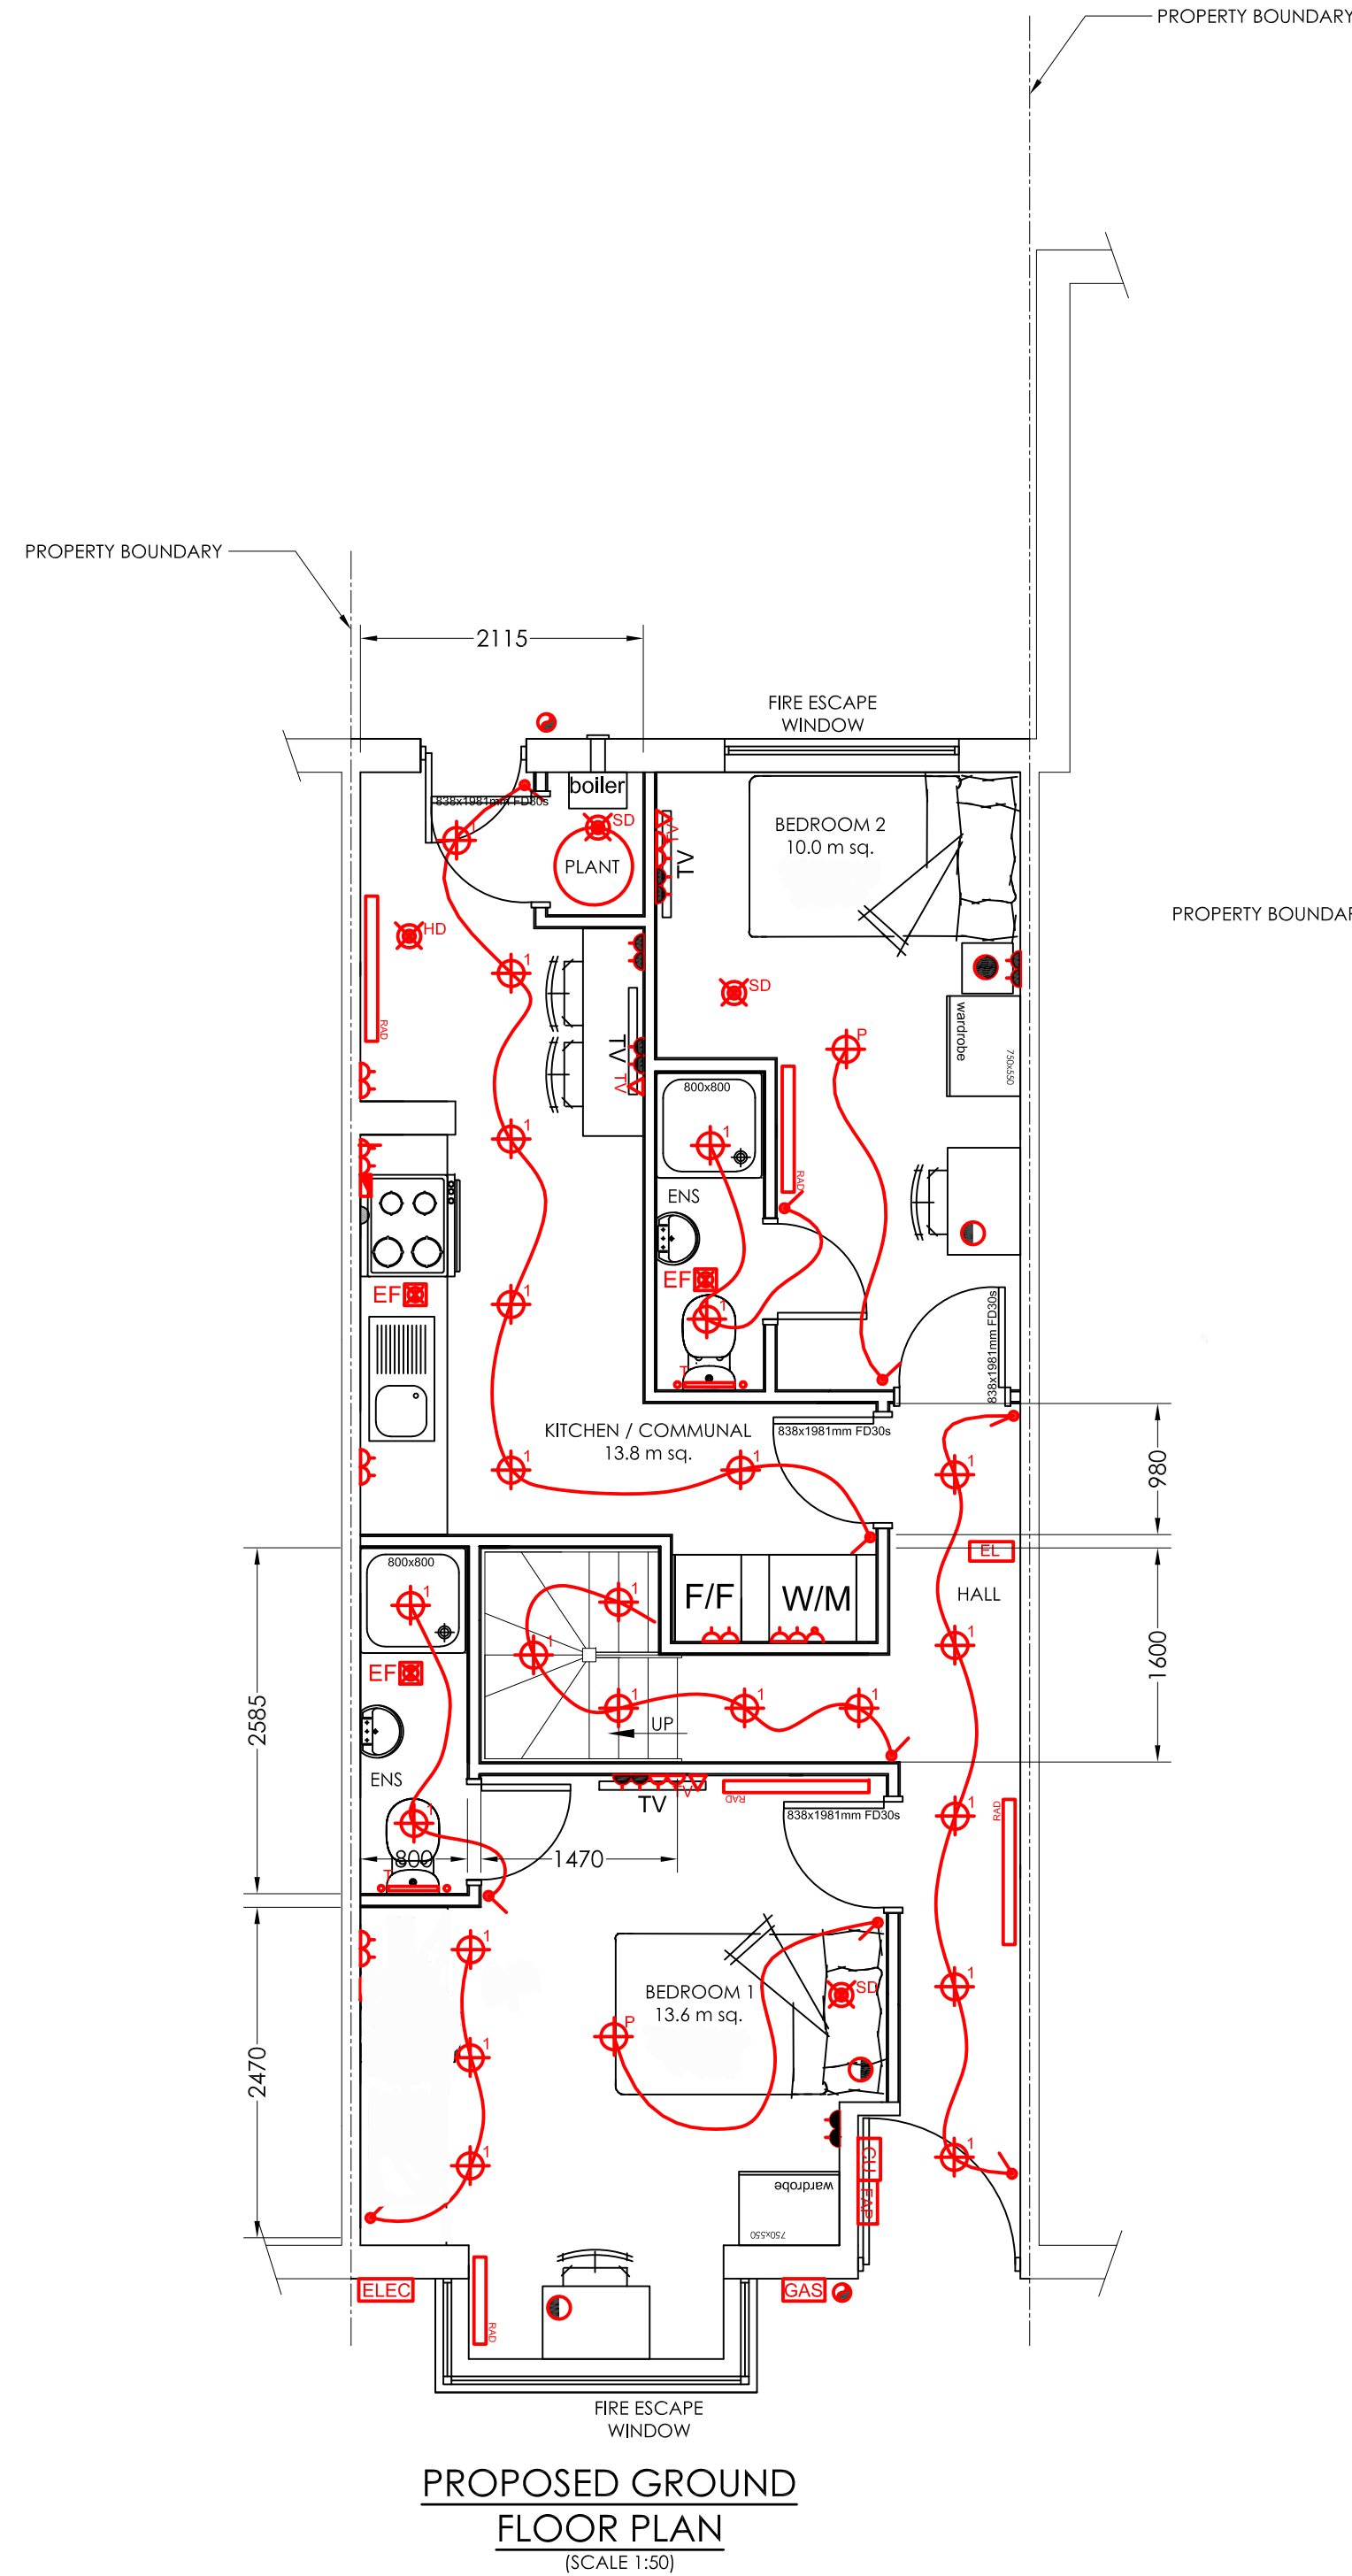

- ELECTRICAL LEGEND**
- LED DOWNLIGHT, COLOUR WARM WHITE
 - INSTALL LED PENDANT LIGHT TO CLIENT'S SPECIFICATION
 - CONSUMER UNIT
 - TV AERIAL (WHITE) WITH WHITE DOUBLE SOCKET
 - TV BOOSTER SOCKET
 - SINGLE SOCKET - FINISH BRUSH CHROME
 - DOUBLE SOCKET - FINISH BRUSH CHROME
 - DOUBLE SOCKET - FINISH BRUSH CHROME (WITH USB)
 - Unifi
 - UP / DOWN LIGHT
 - 40A COOKER/HOB SWITCH
 - FUSED SPUR - MK WHITE
 - BOILER SWITCH - MK WHITE
 - THERMOSTAT
 - ONE GANG SWITCH - FINISH SATIN CHROME
 - TWO GANG SWITCH - FINISH SATIN CHROME
 - SD SMOKE DETECTOR (MAINS OPERATED LS SYSTEM)
 - FIRE ALARM PANEL
 - EMERGENCY LIGHTING
 - COOKER CONNECTION UNIT - MK WHITE
 - 40A COOKER/HOB SWITCH - FLUSH PLATE SATIN STAINLESS STEEL
 - TOWEL RADIATOR, COLOUR WHITE, SIZE TO SUIT, WITH INDIVIDUAL THERMOSTATIC CONTROLS
 - MYSON 600MM HIGH 3 COLUMN RADIATOR - SIZE TO SUIT, WITH INDIVIDUAL THERMOSTATIC VALVES

- WALL DESK LIGHT WITH WALL SWITCH
- PENDANT CEILING LIGHT WITH WALL SWITCH
- UNDER STAIRS CUPBOARD PROVIDE:-
- TV BOOSTER SOCKET
- DOUBLE SOCKET - FINISH WHITE
- Unifi

B	18/02/2025	FLOOR LAYOUTS REVISED.
A	08/12/2024	SCHEME REVISED.
REV.	DATE	DESCRIPTION
ISSUED FOR APPROVAL		
Email - nick@nbarchitectural.co.uk Mobile - 07866628389 Website - www.nbarchitectural.co.uk		
SCHEME - CONVERSION TO 6 BED 6 PERSON HMO.		PROPERTY ADDRESS - 459 ROCHDALE OLD RD, BURY, BL9 7TB.
TITLE - PROPOSED HMO FLOOR PLANS.		A1 SCALE 1:50
DWG No - ROR-No459-002		DATE NOVEMBER 2024
		REV. B