
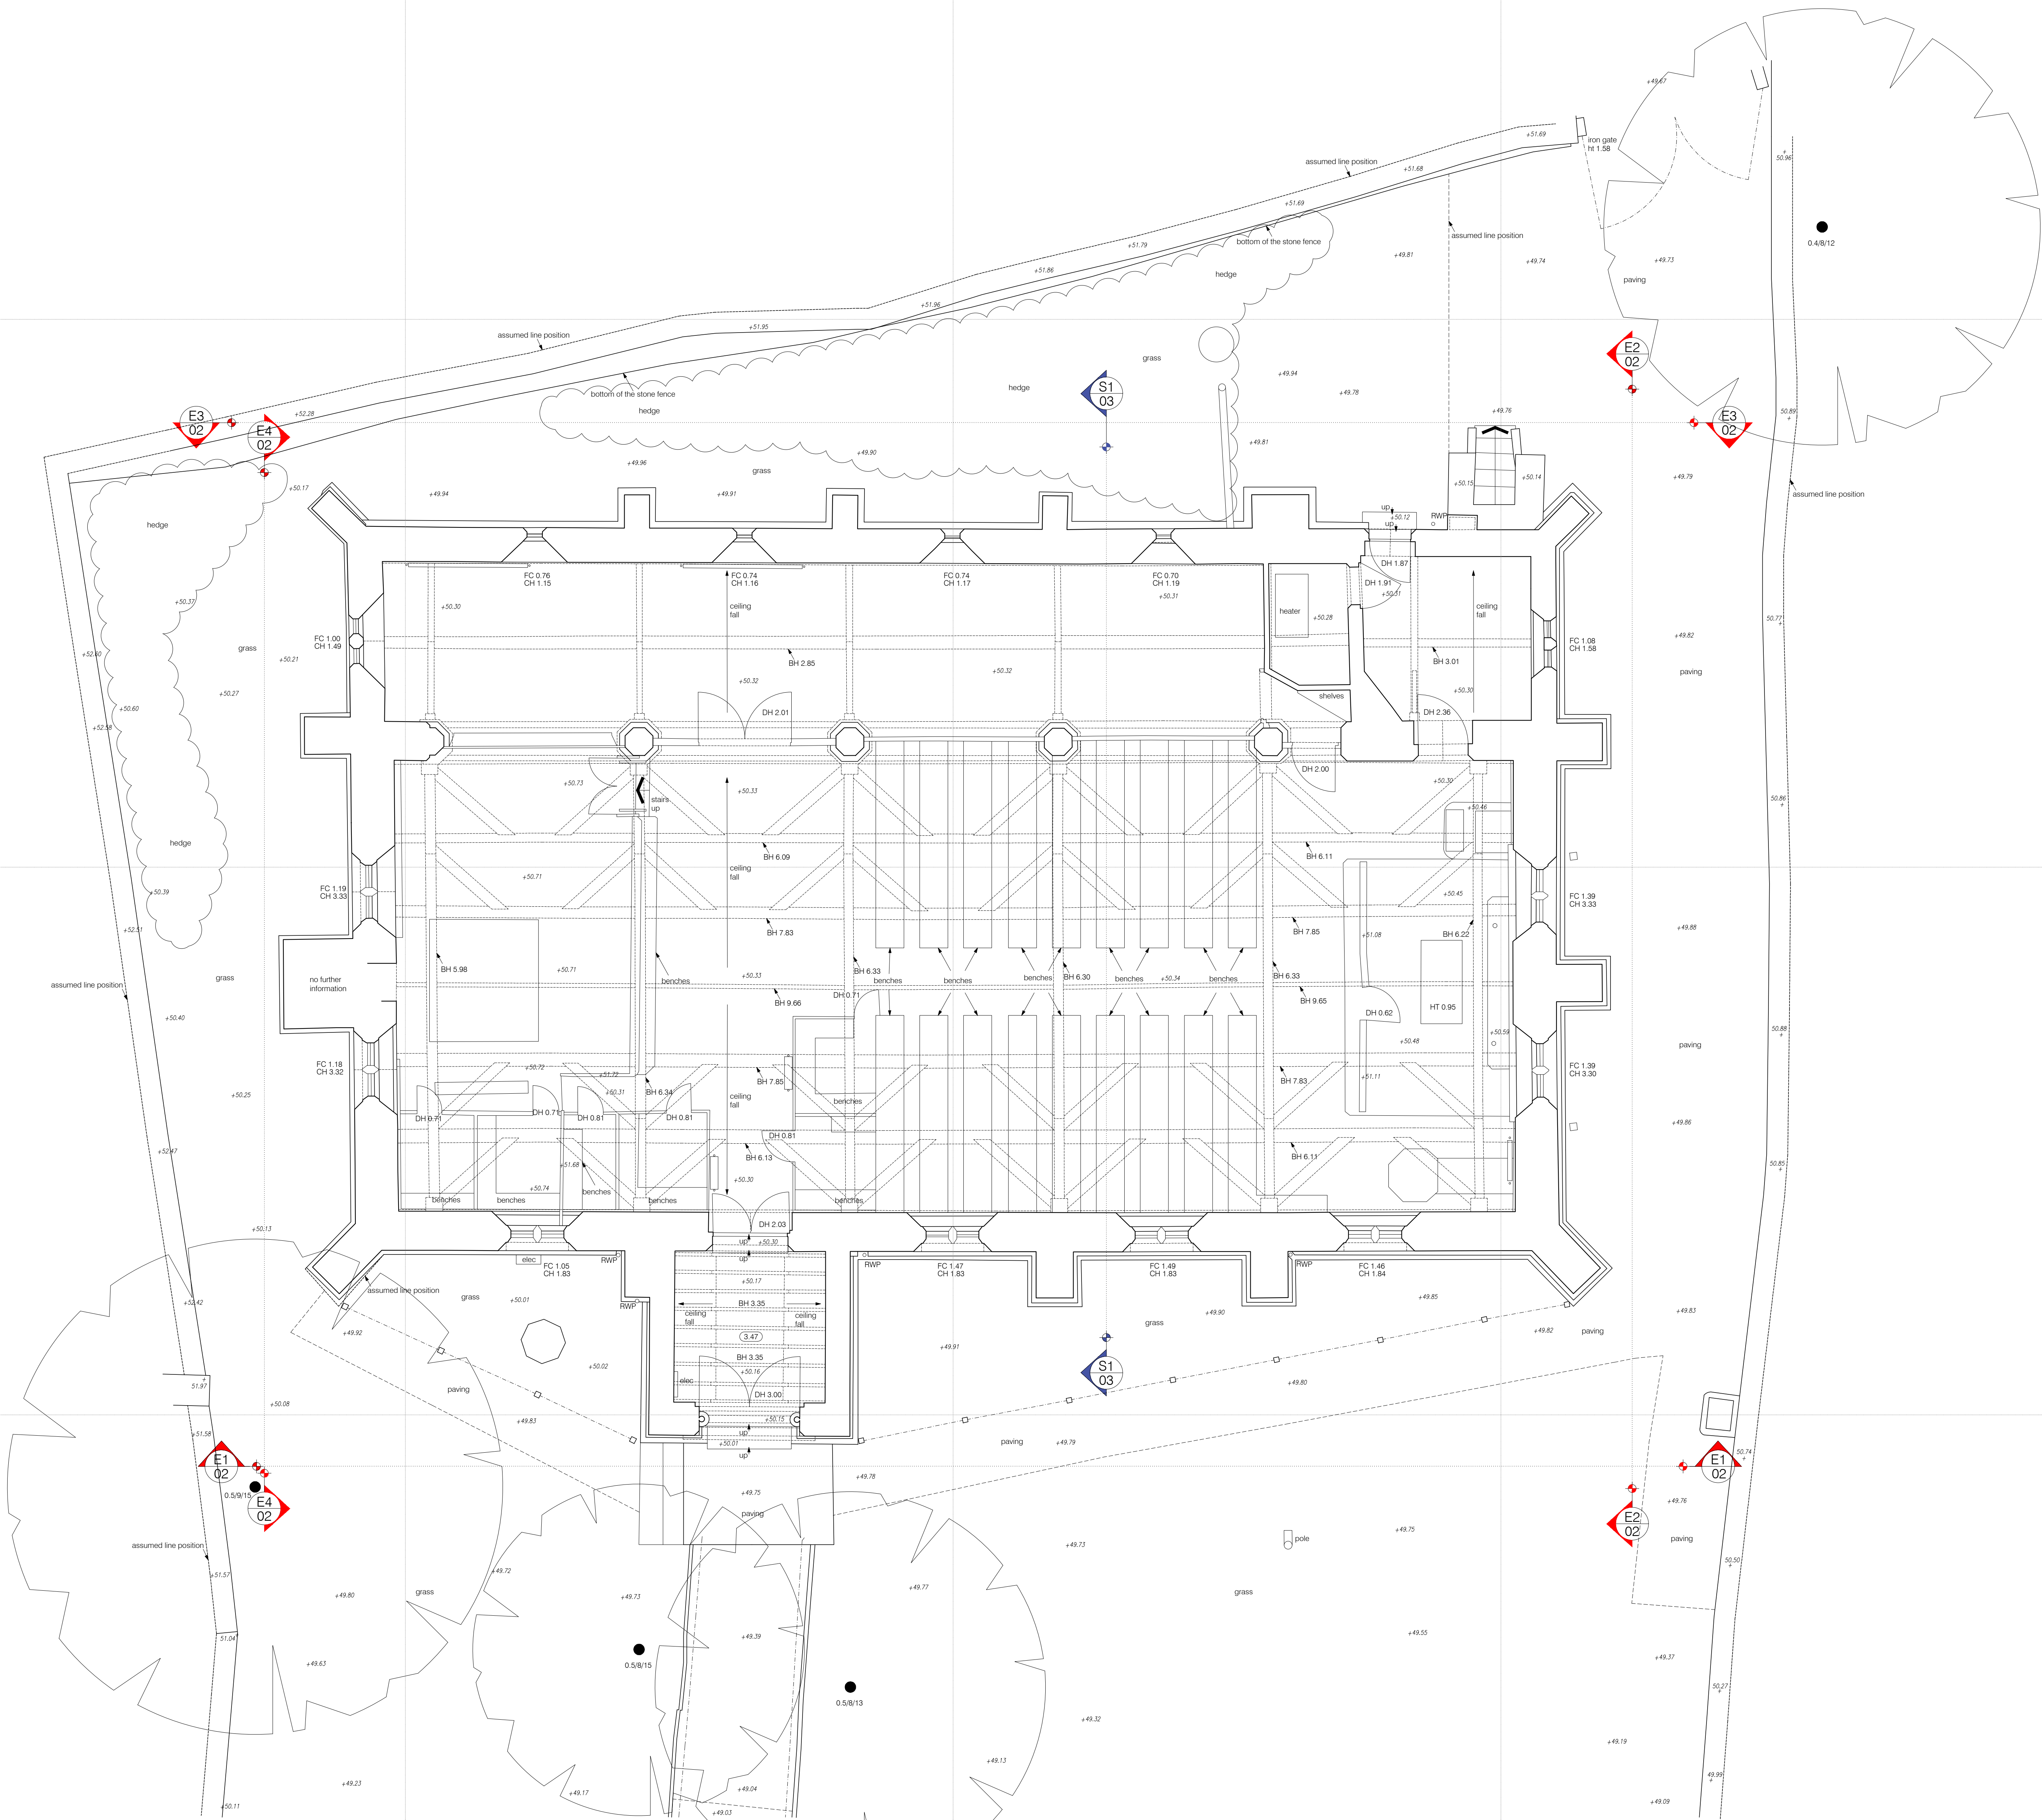


NOTES
1. Information of the site indicated
2. Changed format of sheet to A0

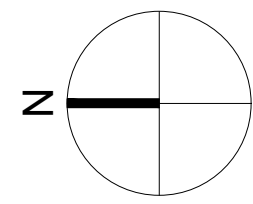

ABBREVIATIONS			
A/C	Air Conditioner	HT	Height
AB	Air Brick	IC	Inspection Cover
BK	Block	IL	Invert Level
BO	Boiler	IR	Iron Railings
BS	Bus Stop	JB	Junction Box
BT	British Telecom cover	KO	Kerb Offset
FC	Floor to Cill height	LP	Lamp Post
CL	Cover Level	LW	Light Well
CO	Column	MH	Manhole
CONC	Concrete	MT	Meter
CPL	Coping Level	OH	Overhead
CPS	Concrete Paving Slabs	PT	Post
CTV	Cable Television Cover	RET	Retaining
DK	Drop Kerb	RS	Road Sign
DH	Door Height	RWP	Rain Water Pipe
EP	Electricity Pole	SVP	Set Ventr Pipe
FR	Flower Bed	TCS	Telephone Call Box
FC	Fine Ceiling	TBM	Temp. Bench Mark
FL	Fire Escape	TL	Traffic Light
FR	Fire Hydrant	TL	Task
FRR	Fire Hose Reel	UTL	Unable To Lift
FL	Floor Level	VP	Vent
GU	Gate Post	WM	Water Meter
GV	Gas Valve	WP	Waste Pipe
CH	Cill to Head height	WV	Water Valve

OO-COORDINATE SYSTEM	
☒	Arbitrary - related to building line
☐	Arbitrary - approx. related to North
☐	Ordnance Survey National Grid

LEVELS	
☒	Arbitrary - related to a temporary bench mark
☐	Ordnance Survey Bench Mark
☐	Ordnance Survey National Grid Network

Rev	Date	By	Details
01	11/10	AH	Note 1

FLOOR PLAN SYMBOLS	
+10.00	Spot Level
(3.00)	Ceiling Height
(2.80)	Floor To False Ceiling Height
BH 2.80	Floor To Beam Height
FC 0.80	Floor To Cill Height/Cill To Head Height
CH 1.80	Ceiling Level
(20.00)	False Ceiling Level

www.redlasserscanning.co.uk
enquiry@redlasserscanning.co.uk
London Head Office
23 Sussex Street
SW1V 4RR
0207 477 2175

Project		St John in the Wilderness Whalley Rd Shuttleworth	
Description		Ground Floor	
Survey Date	29/09/2021	Drawing Date	01/10/2021
Sheet	@A0	Scale	1:50
Drawn	AH	Checked	CT
Project No.	1342	Drawing No.	01
Preliminary		Revision	01