


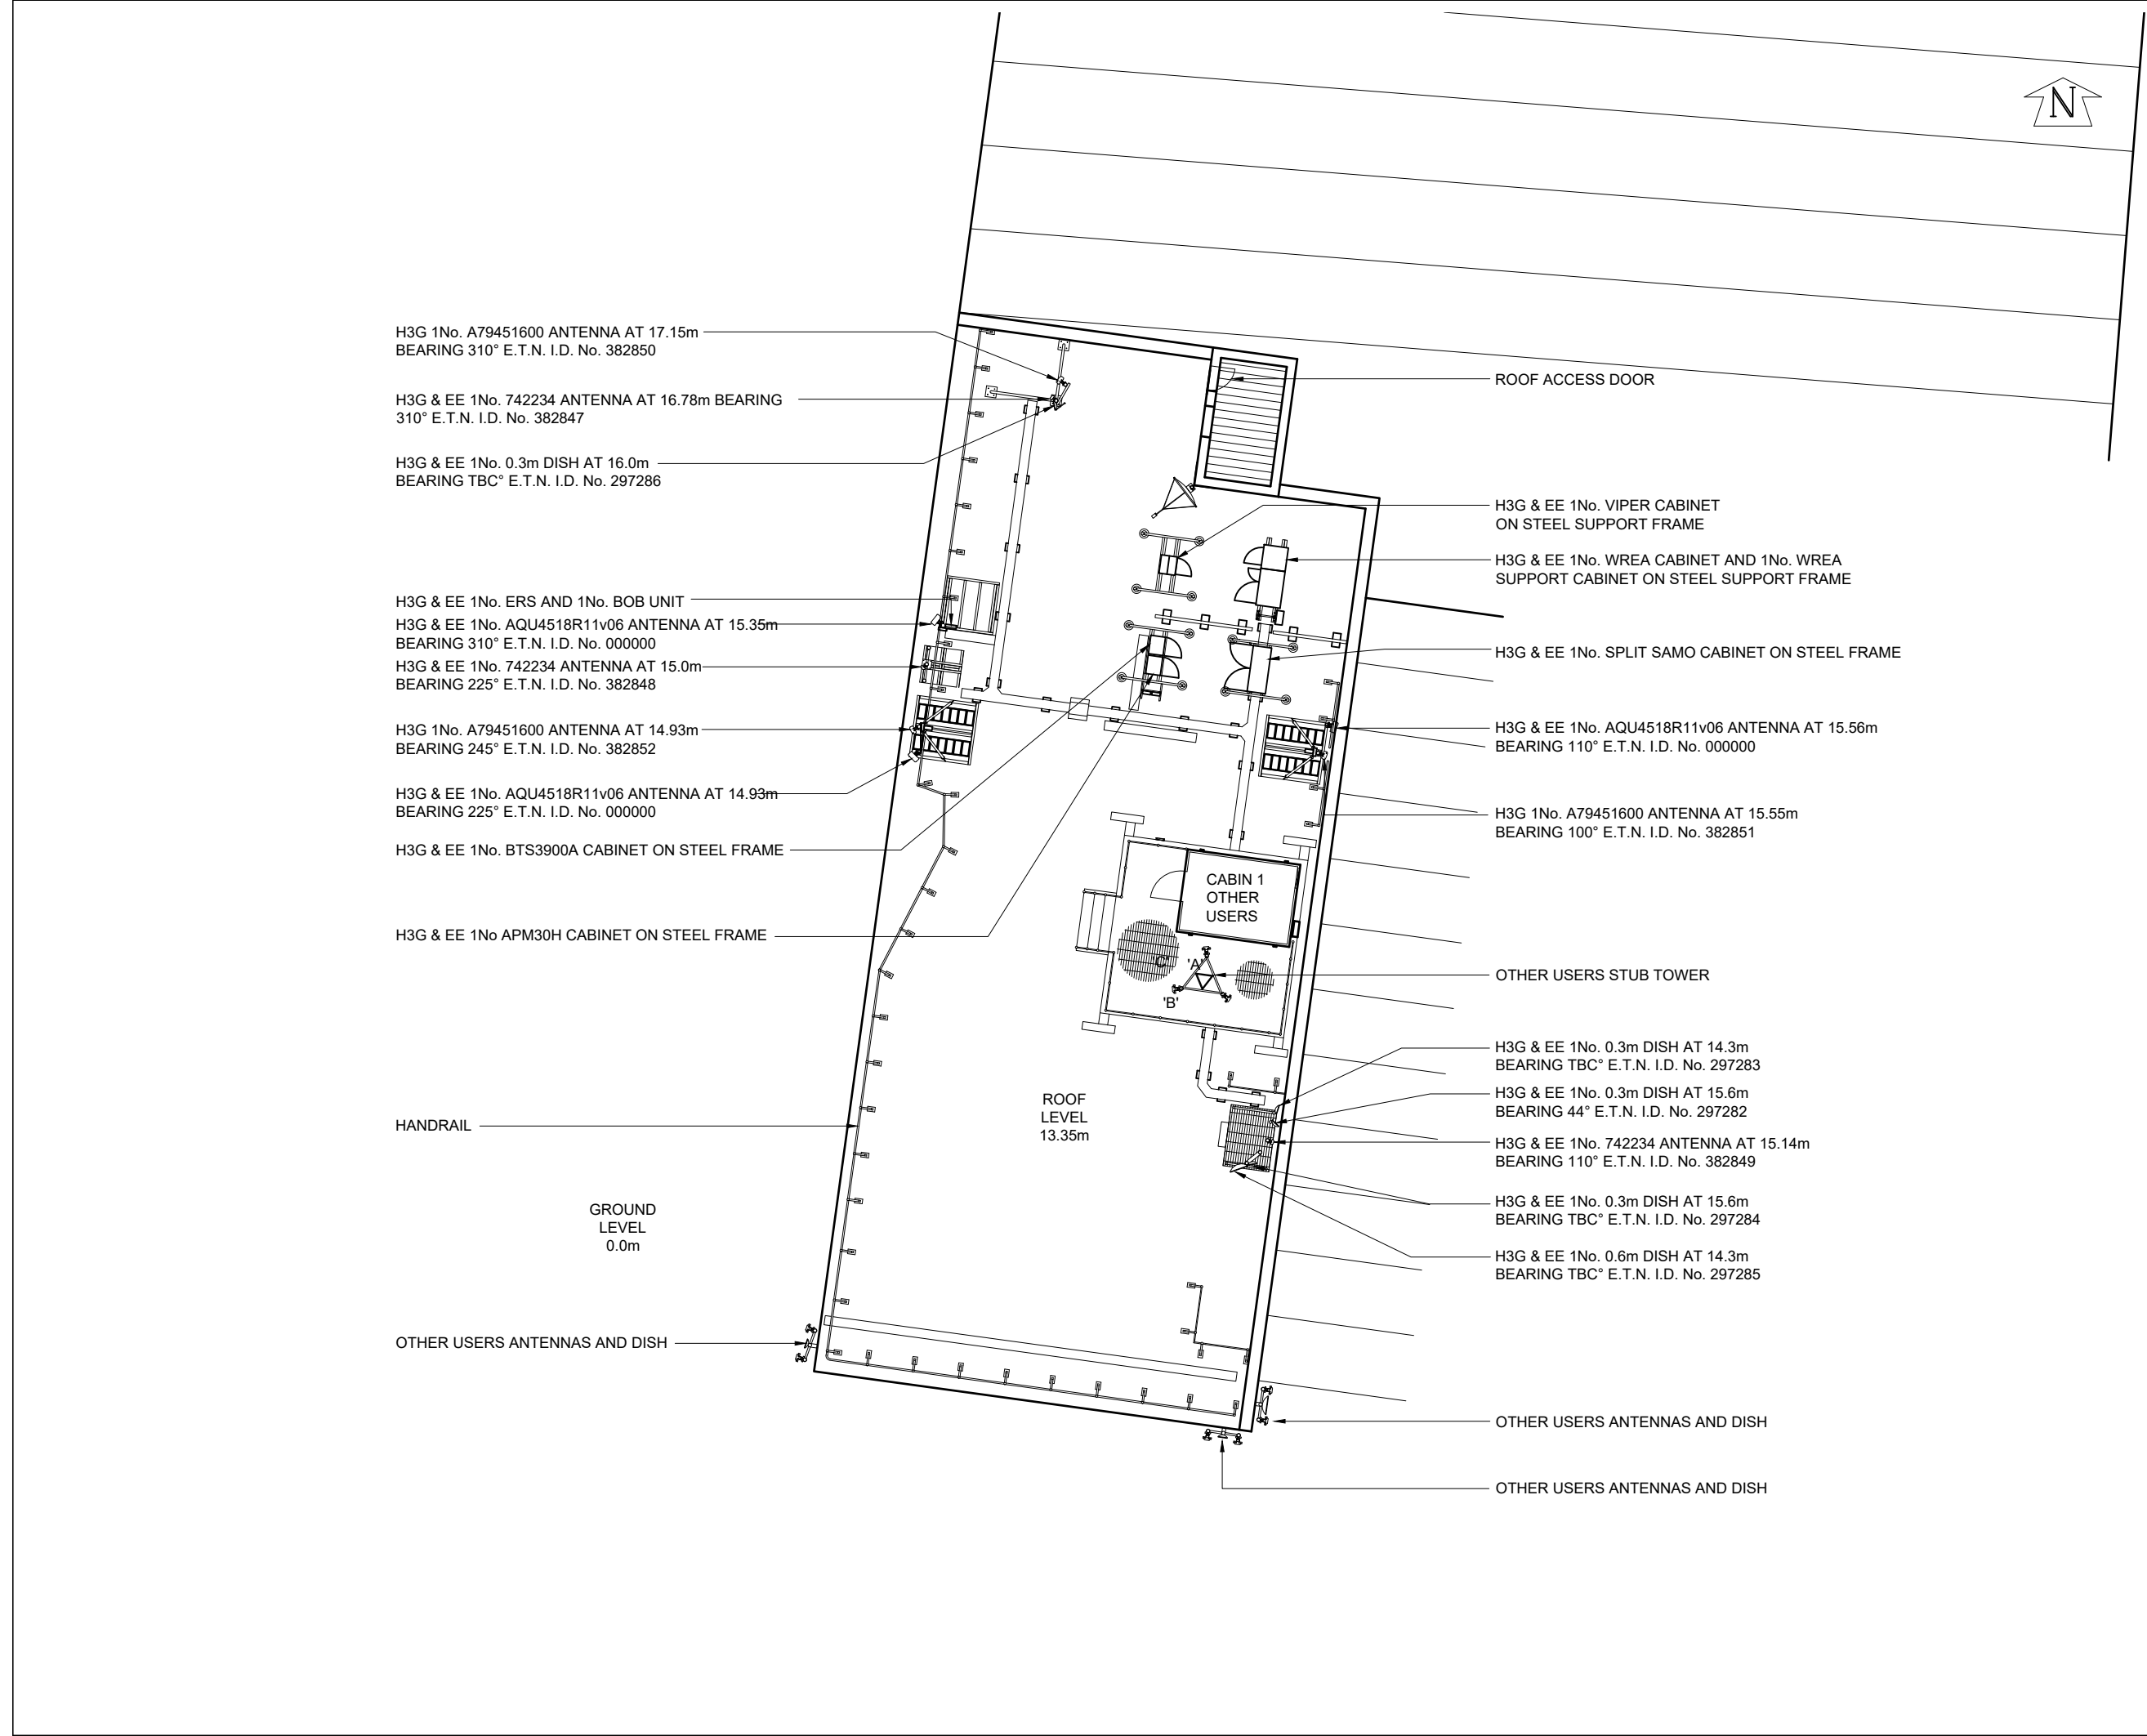

©2020 Cellnex

All rights reserved. No part of this publication may be reproduced, stored in a retrieval system or transmitted in any form or by any means (Electronic, Mechanical, Photocopying, Recording or otherwise), without the prior written consent of the Company.

NOTES

UNDERGROUND SERVICES

UNDERGROUND SERVICES ARE INDICATIVE ONLY. POSITIONS SHOULD BE CONFIRMED ON SITE PRIOR TO ANY DEVELOPMENT

DRAINAGE

DUCTS

FEEDERS

FENCE PLAN

GAS

LIGHTNING PROTECTION - EARTHING

POWER

SERVICES UNKNOWN

TELECOMS

WATER

ACCESS ARRANGEMENTS

KEYS:-

ARQIVA GATE KEY

B KEY

C KEY

LEGGE KEY

SURVEY REQUIRED TO CONFIRM ACCESS KEYS FOR REMAINING ROOMS AND SITE ENTRANCE

	PROJ No			
	PROJ No			
	PROJ No			
3	PROJ No 238891 PLANNING	29/11/21	WHP	WHP
2	PROJ No 9BMOBL MASTER UPDATE	20/05/20	MCD	KG
1	PROJ No 9BMOBL MD CREATE	02/04/20	KG	MF
ISS	REVISION	DATE	DRN	APP

cellnex

driving telecom connectivity

CELLNEX UK

R+, 4TH FLOOR, 2 BLA GRAVE STREET, READING, RG1 1AZ

Tel. 020 4526 8553

SITE No 87891

BURY YORK STREET B

LAKELAND FURNISHING (YORK ST

YORK STREET

BURY

GREATER MANCHESTER

BL9 7AR

NGR SD 81144 10828

OS GRID 381144 410828

TITLE

SITE PLAN

SCALE 1:200

DRAWN KG

30/03/20

APPROVED WHP

29/11/21

DRG No.

Sheet 1 of 1


Rev

87891-00-000-MD003

3

A3

NOTES

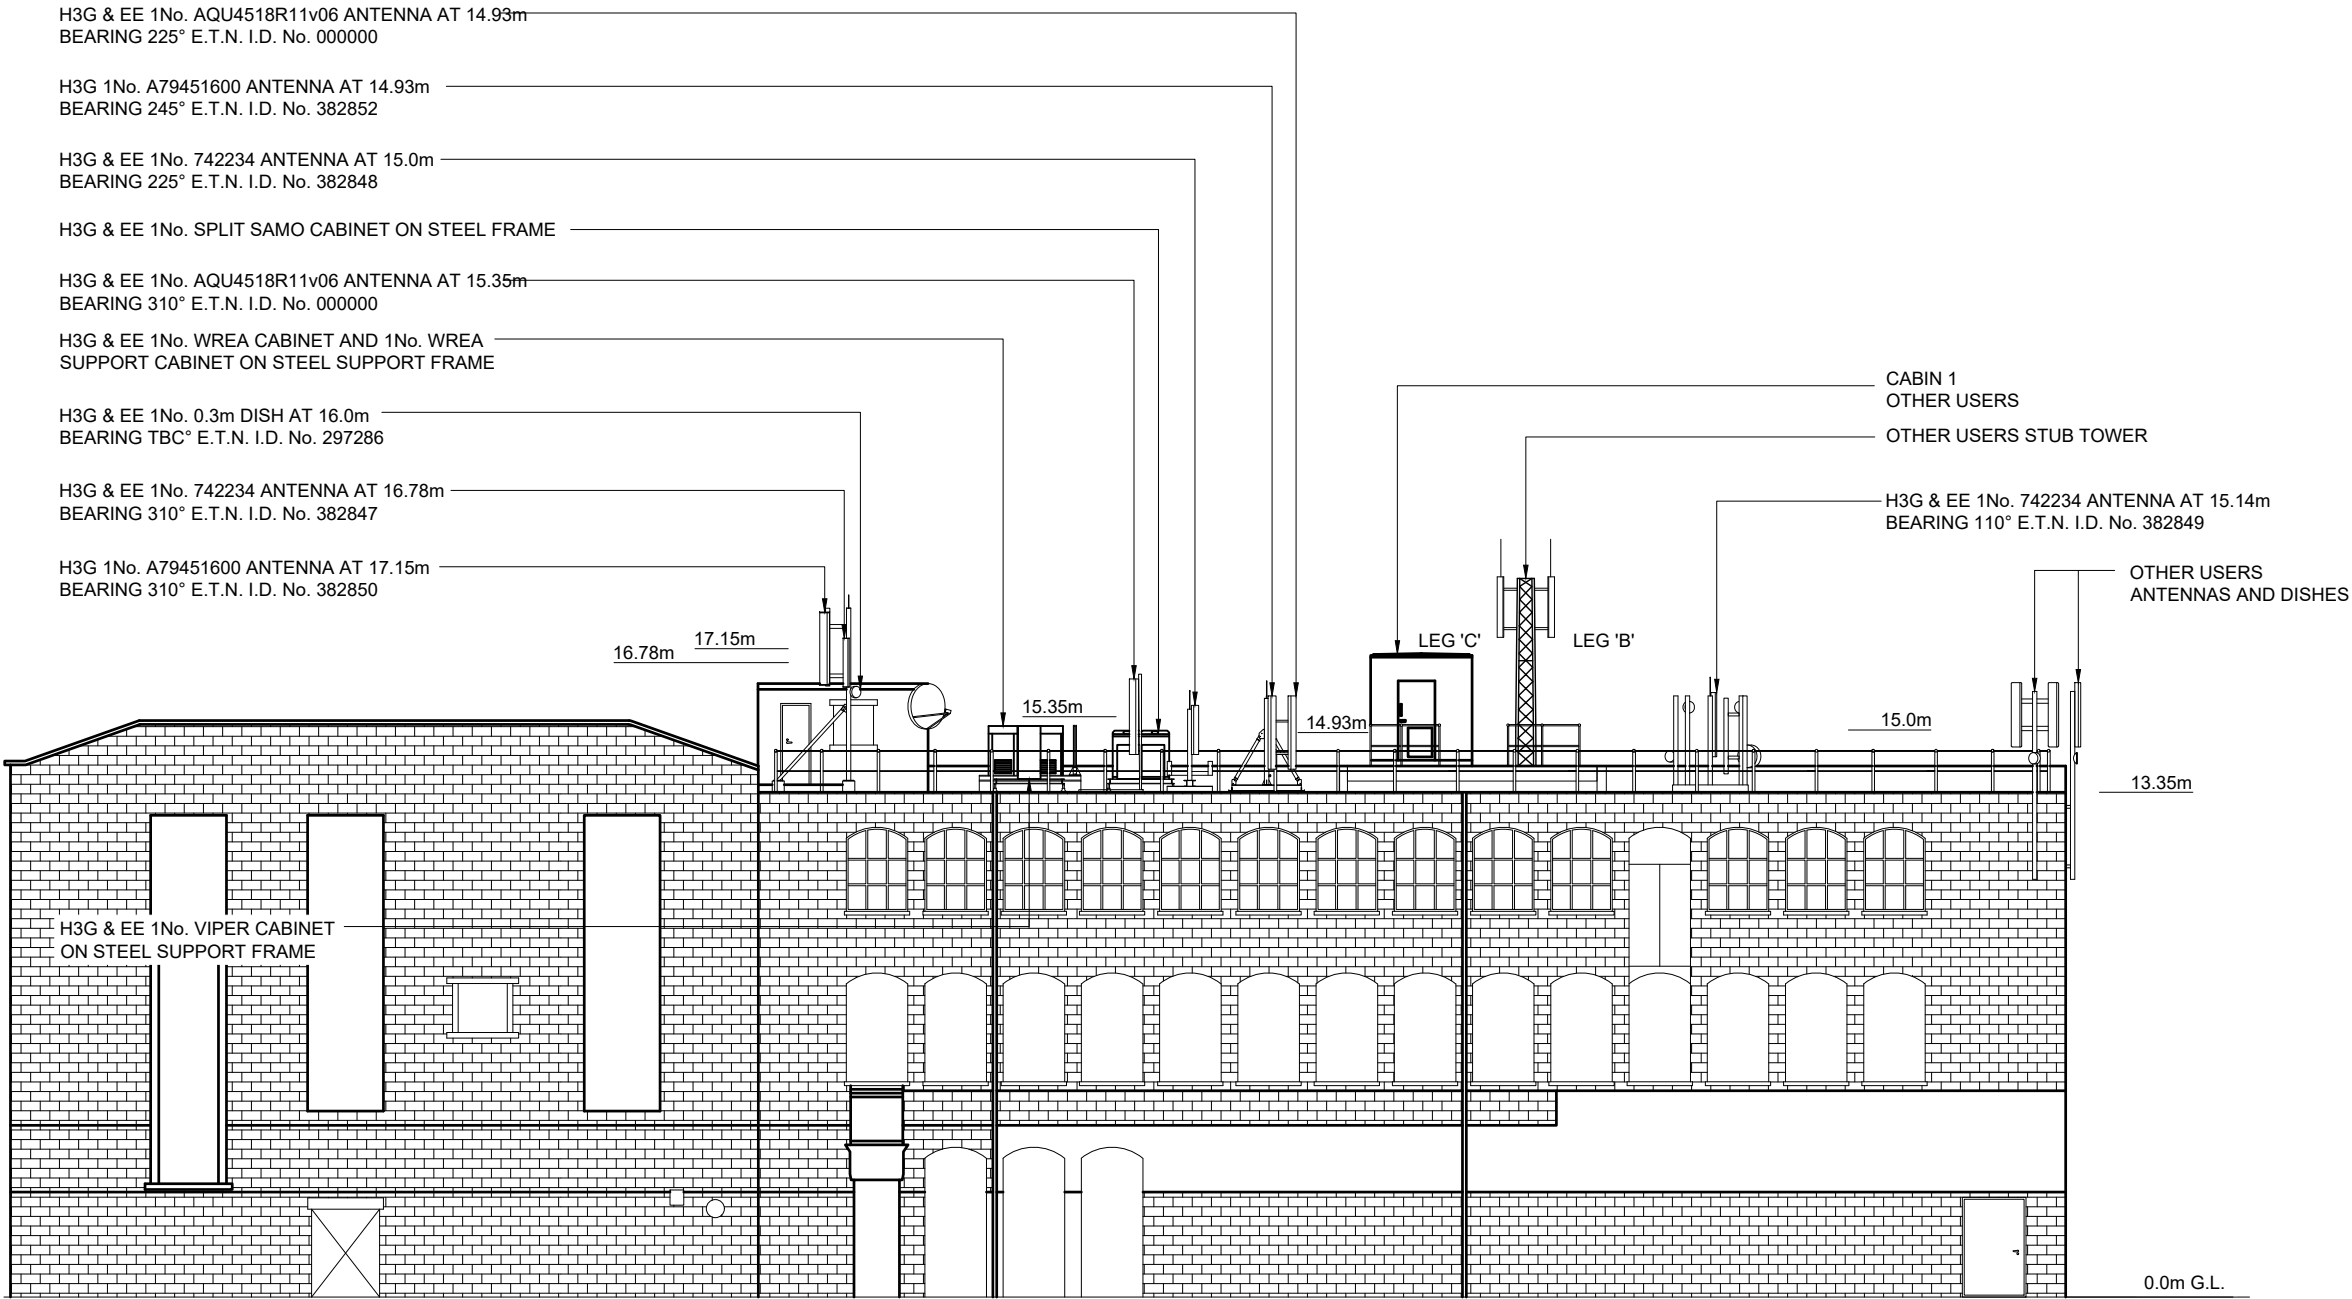

	PROJ No			
	PROJ No			
3	PROJ No 238891 PLANNING	29/11/21	WHP	WHP
2	PROJ No 9BMOBL MASTER UPDATE	20/05/20	MCD	KG
1	PROJ No 9BMOBL MD CREATE	02/04/20	KG	MF
ISS	REVISION	DATE	DRN	APP

cellnex
driving telecom connectivity

CELLNEX UK
R+, 4TH FLOOR, 2 BLA GRAVE STREET, READING, RG1 1AZ
Tel. 020 4526 8553

SITE No **87891**
BURY YORK STREET B
LAKELAND FURNISHING (YORK ST
YORK STREET
BURY
GREATER MANCHESTER
BL9 7AR

NGR SD 81144 10828

OS GRID 381144 410828

TITLE
ELEVATION

WEST

SCALE 1:200

DRAWN KG 30/03/20

APPROVED WHP 29/11/21

DRG No. Sheet 1 of 1 Rev
87891-00-002-MD003 3