

Do not scale from this drawing. All dimensions to be checked on site prior to manufacture and construction. This drawing is the property of Harrison Ince Holdings Limited and should not be reproduced without permission.
All discrepancies to be brought to the attention of the architect immediately.
This drawing is to be read in conjunction with the specification / bill of quantities and related drawings.

REVISIONS


- FIRST ISSUE
A PLANNING ISSUE

19.11.25 SF
05.12.25 GW

LIGHTING KEY		
NAME	KEY	IMAGE
WL1 WALL LIGHT REF: DOUBLE ARM WALL LIGHT WITH TWO LARGE PRISMATIC CONES SUPPLIER: E2 CONTRACT LIGHTING FINISH: SATIN BRASS		
WL2 PICTURE LIGHT REF: VINTAGE DETAIL PICTURE LIGHT SUPPLIER: E2 CONTRACT LIGHTING FINISH: SATIN BRASS		
WL3 WALL LIGHT REF: GLASS ROD UP & DOWN WALL LIGHT IP44 SUPPLIER: E2 CONTRACT LIGHTING FINISH: GOLD		
L1 DECORATIVE TABLE LAMP WITH HOLOPHANE DOME SHADE REF: HARDWIRED TABLE LAMP WITH HOLOPHANE DOME SHADE SUPPLIER: E2 CONTRACT LIGHTING FINISH: POLISHED BRASS		
P1 PENDANT TYPE 1 REF: CEILING LAMP BAGATELLE SUPPLIER: EICHOLTZ FINISH: ANTIQUE BRASS		
P2 PENDANT TYPE 2 REF: EXISTING CHANDELIERS TO BE CLEANED AND RETAINED IN THEIR CURRENT LOCATION		
P3 PENDANT TYPE 3 REF: HOLOPHANE DOME LIGHT SUPPLIER: E2 CONTRACT LIGHTING FINISH: ANTIQUE BRASS		
P5 PENDANT TYPE 5 REF: WHITE MILK GLASS HANGING LAMP SUPPLIER: E2 CONTRACT LIGHTING FINISH: ANTIQUE BRASS		
P6 PENDANT TYPE 6 REF: EXISTING SMALL CHANDELIERS TO BE TAKEN DOWN, CLEANED AND REINSTALLED IN NEW POSITION		
DL1 DOWNLIGHT TYPE 1 REF: JDW DSOP		
SKY TILE REF: JDW DSOP		
DL1 DIRECTIONAL LIGHT ADJUSTABLE WHITE SPOTLIGHT CL-51089 SUPPLIER: E2 CONTRACT LIGHTING		
NOTES: ALL FITTING FINISHES TO BE POLISHED BRASS, ANTIQUE BRASS, SATIN BRASS OR GOLD EP - TO REMAIN AS EXISTING ELECTRICAL POINTS NP - NEW POINTS AND FITTINGS TO BE INSTALLED FITTINGS INDICATED IN RED TO BE NEW FITTINGS (INSTALLED WITH NEW OR EXISTING POINTS)		

FOR PLANNING

@1:50 scale

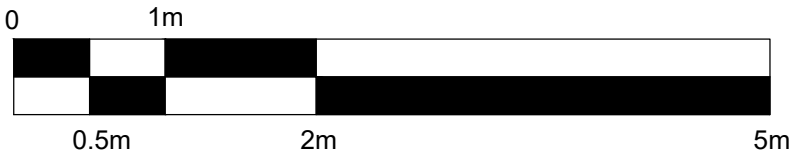

HARRISON INCE

ARCHITECTS INTERIOR DESIGNERS

JD WETHERSPOON PLC

THE ART PICTURE HOUSE,
36 HAYMARKET STREET, BURY BL9 0AY

PROPOSED GROUND FLOOR
LIGHTING PLAN

DATE

AUGUST 2025

SCALE

1:50 @ A1

JOB NO.

PN 6264

DWG. NO.

AF01 B

DRAWN

CAD/LEB/GW

CHECKED

SUN HOUSE
2-4 LITTLE PETER STREET
KNOTT MILL
MANCHESTER
M15 4PS
TEL: 0161 236 3850
EMAIL: enquiries@harrison-ince.co.uk

PROPOSED GROUND FLOOR PLAN - LIGHTING PLAN

Scale 1:50