

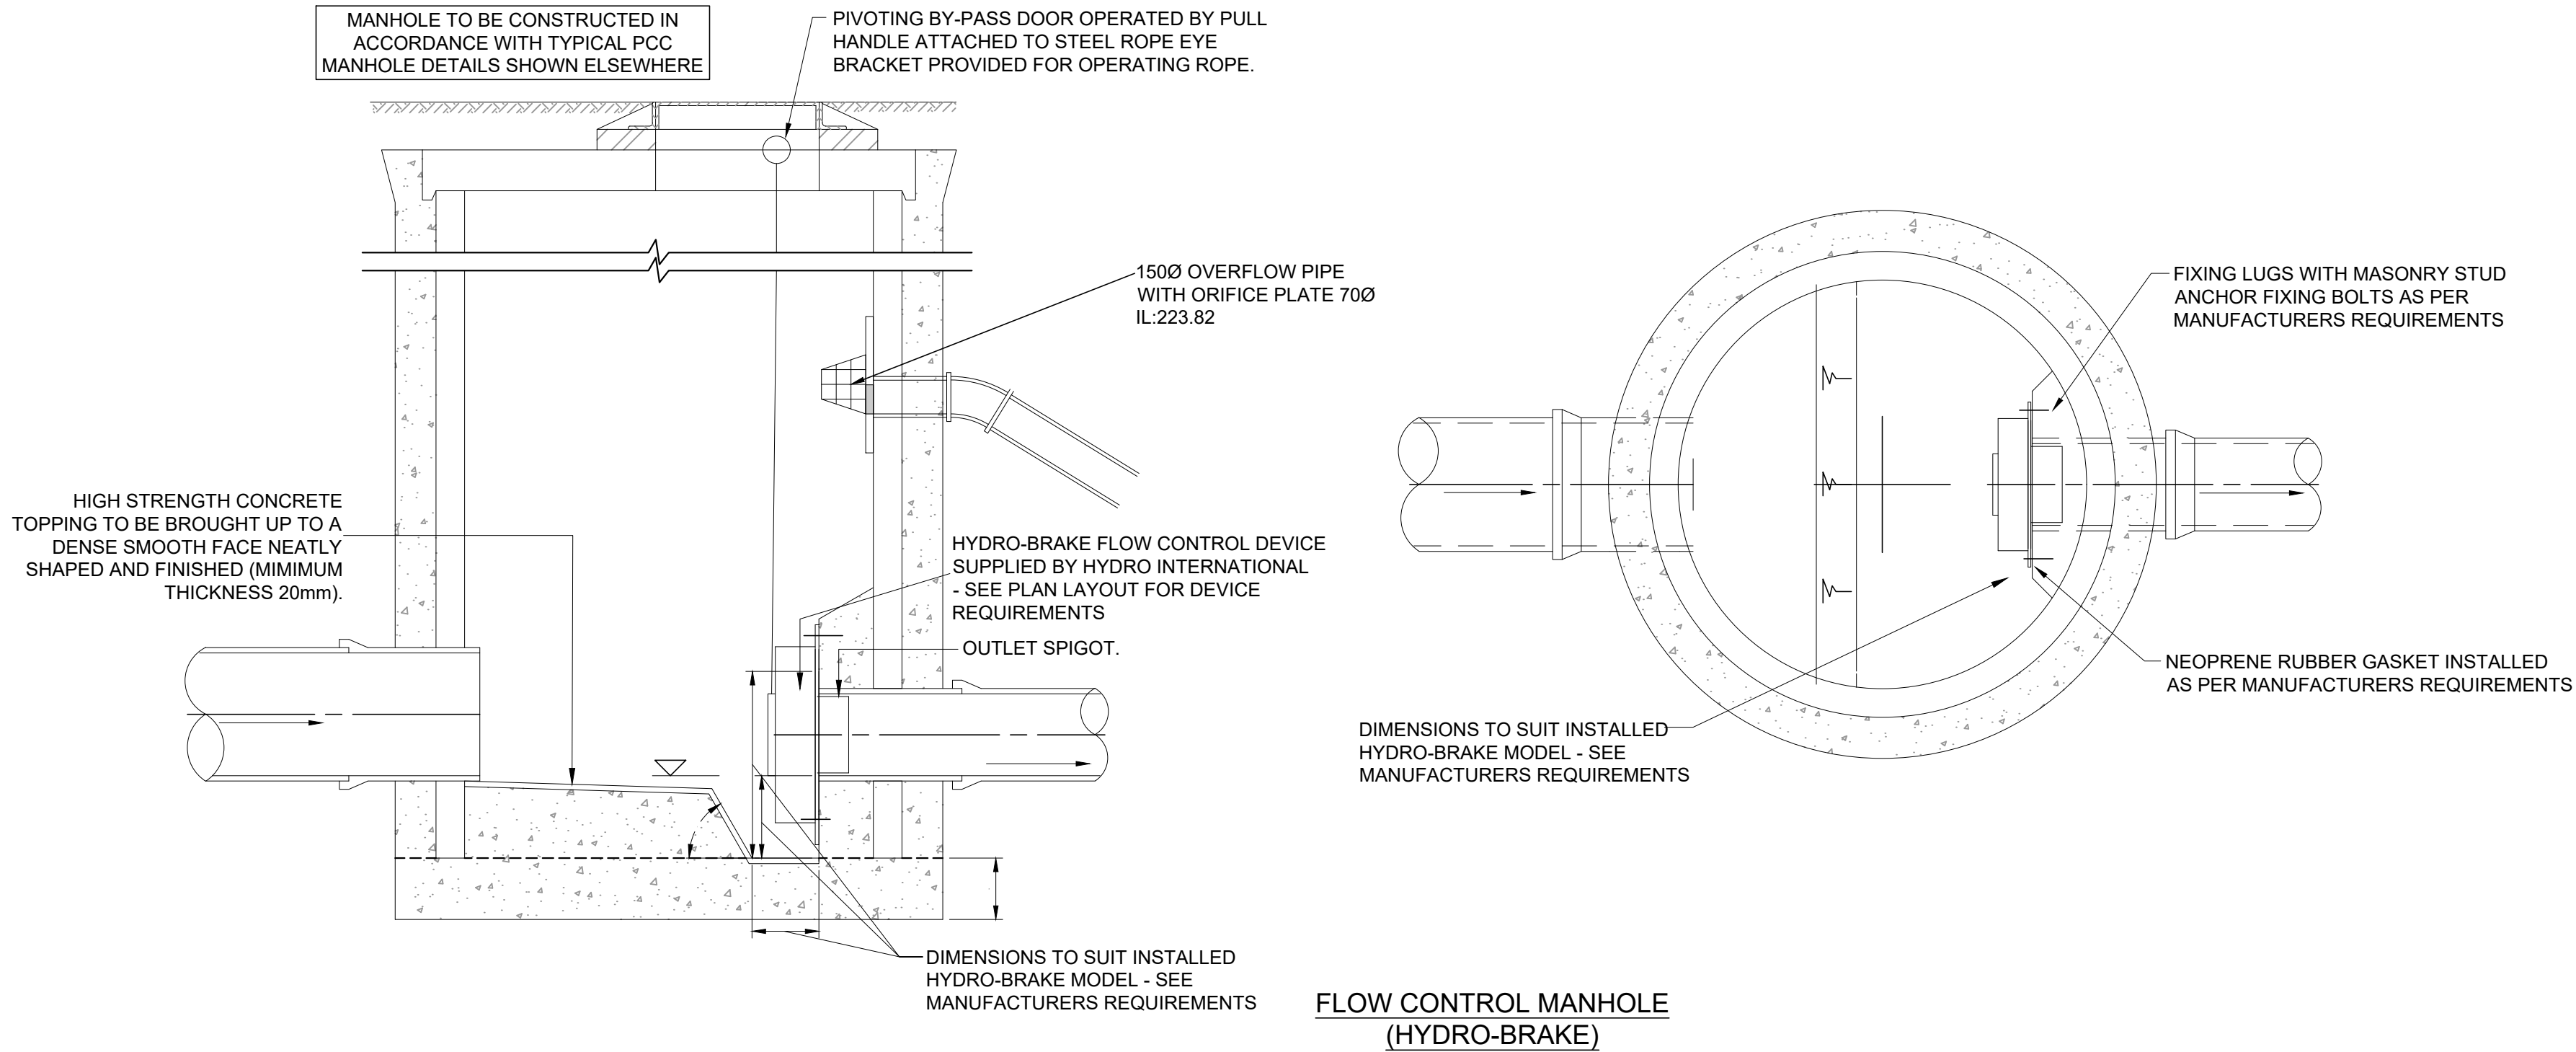


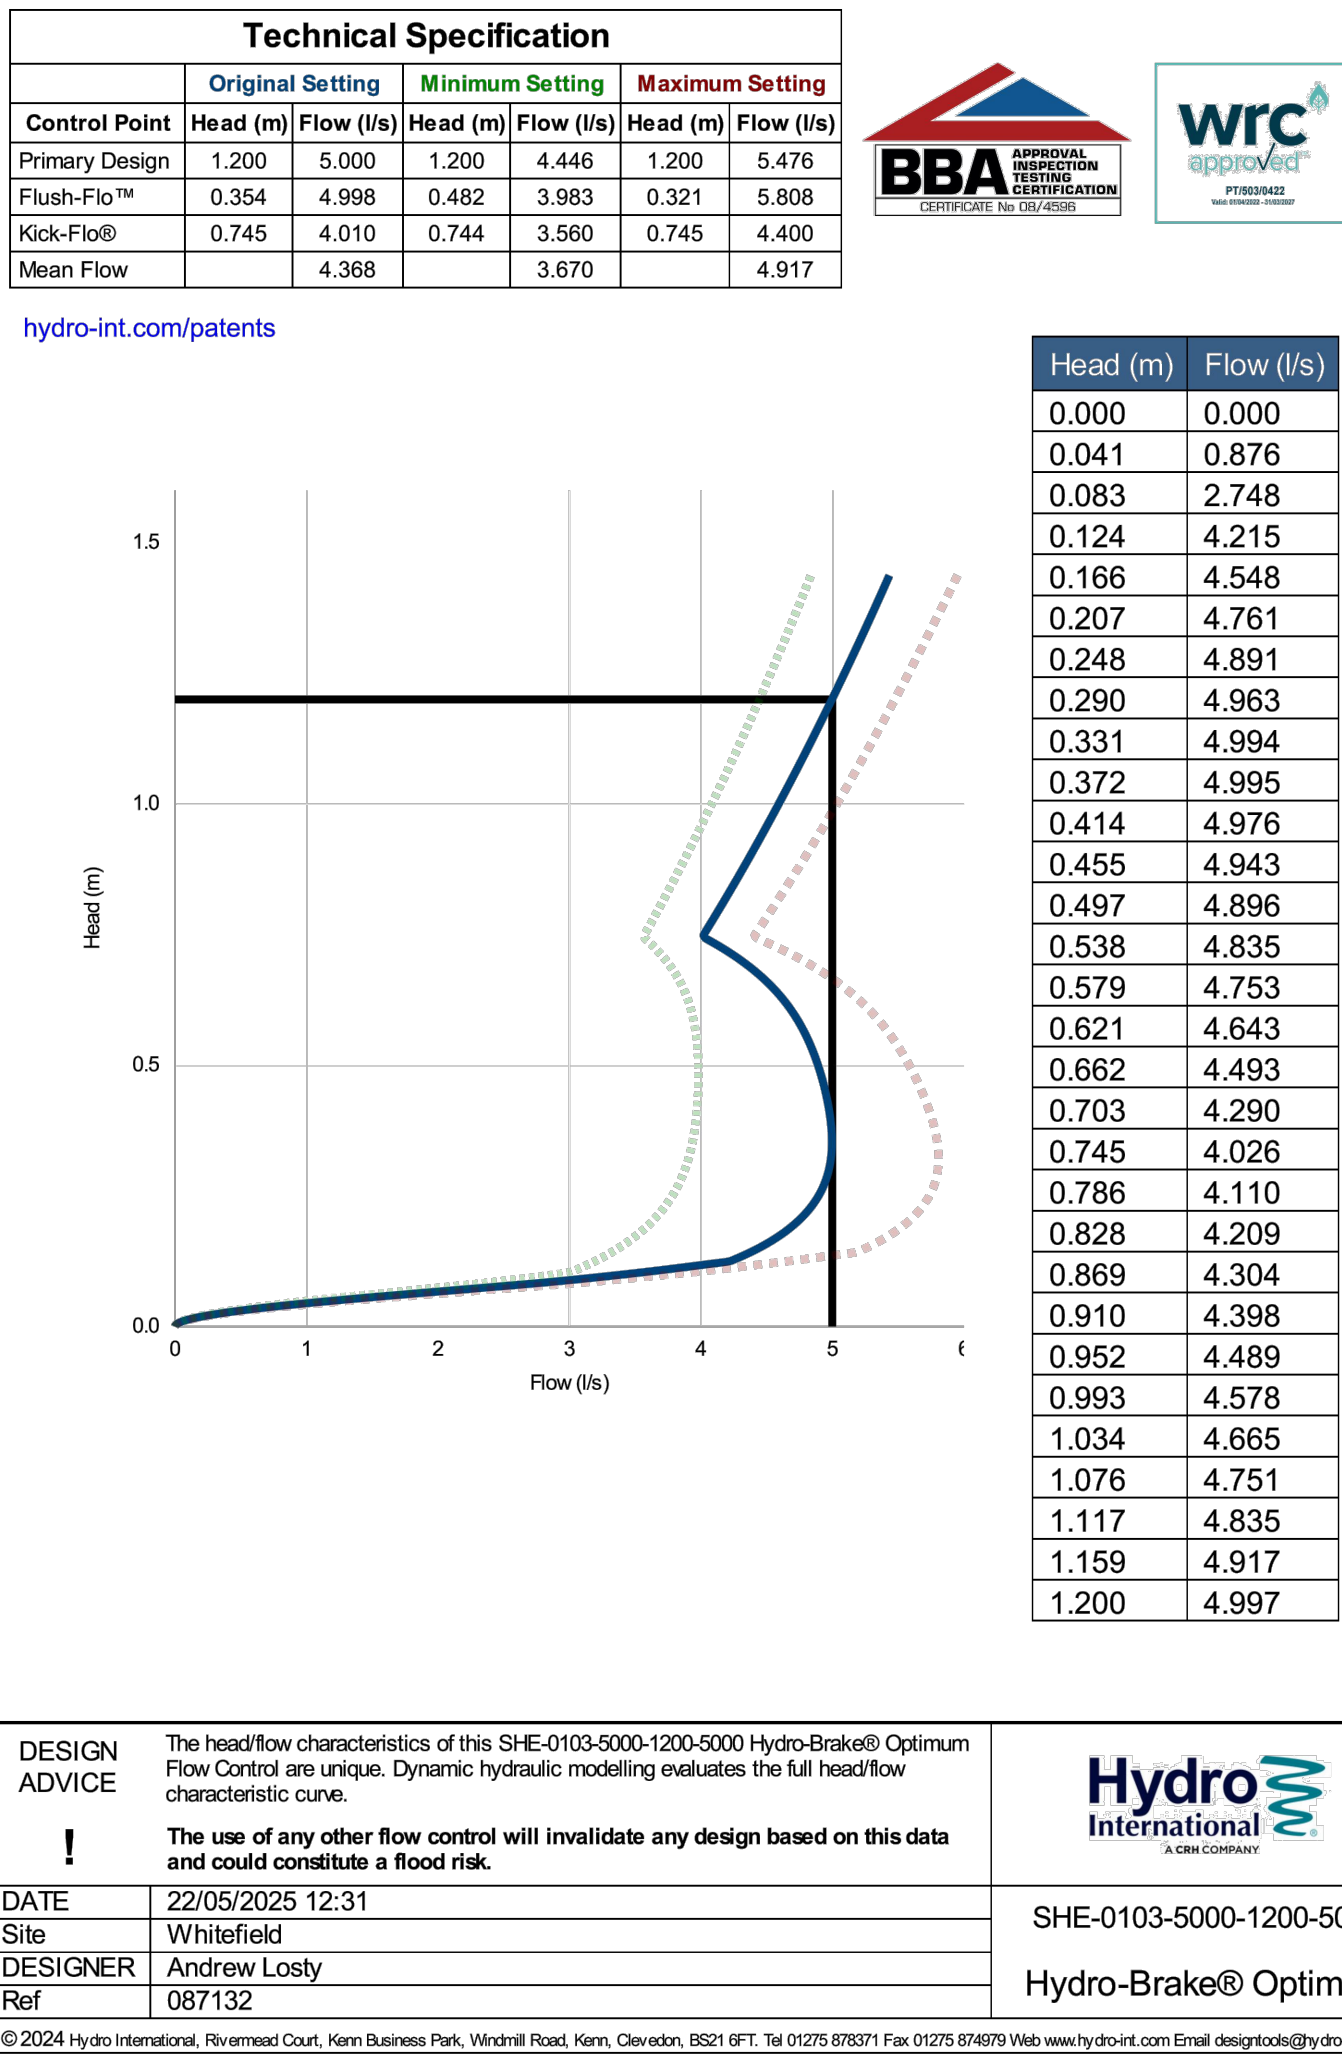


GENERAL NOTES:

- THIS DRAWING IS TO BE READ IN CONJUNCTION WITH ALL RELEVANT ARCHITECTS AND ENGINEERS DRAWINGS AND SPECIFICATIONS.
- DO NOT SCALE THIS DRAWING. ANY AMBIGUITIES, OMISSIONS AND ERRORS ON DRAWINGS SHALL BE BROUGHT TO THE ENGINEERS ATTENTION IMMEDIATELY. ALL DIMENSIONS MUST BE CHECKED / VERIFIED ON SITE.
- ALL DIMENSIONS ARE IN MILLIMETRES UNLESS NOTED OTHERWISE.
- REFER TO DRAINAGE LAYOUT 087132-CUR-XX-00-DR-C-92500 PROPOSED DRAINAGE LAYOUT FOR THE LOCATIONS OF FLOW CONTROL MANHOLES.
- FLOW CONTROL TO BE INSTALLED IN STRICT ACCORDANCE WITH THE MANUFACTURERS REQUIREMENTS, INSTRUCTIONS AND RECOMMENDATIONS.
- WHERE ALTERNATIVE FLOW CONTROL DEVICE IS PREFERRED, IT WILL BE SUBJECT TO REDESIGN TO CONFIRM WHETHER THERE IS ANY IMPACT ON THE UPSTREAM CAPACITY
- SURFACE WATER DRAINAGE CONNECTION SUBJECT TO S106 AGREEMENT WITH SEVERN TRENT WATER

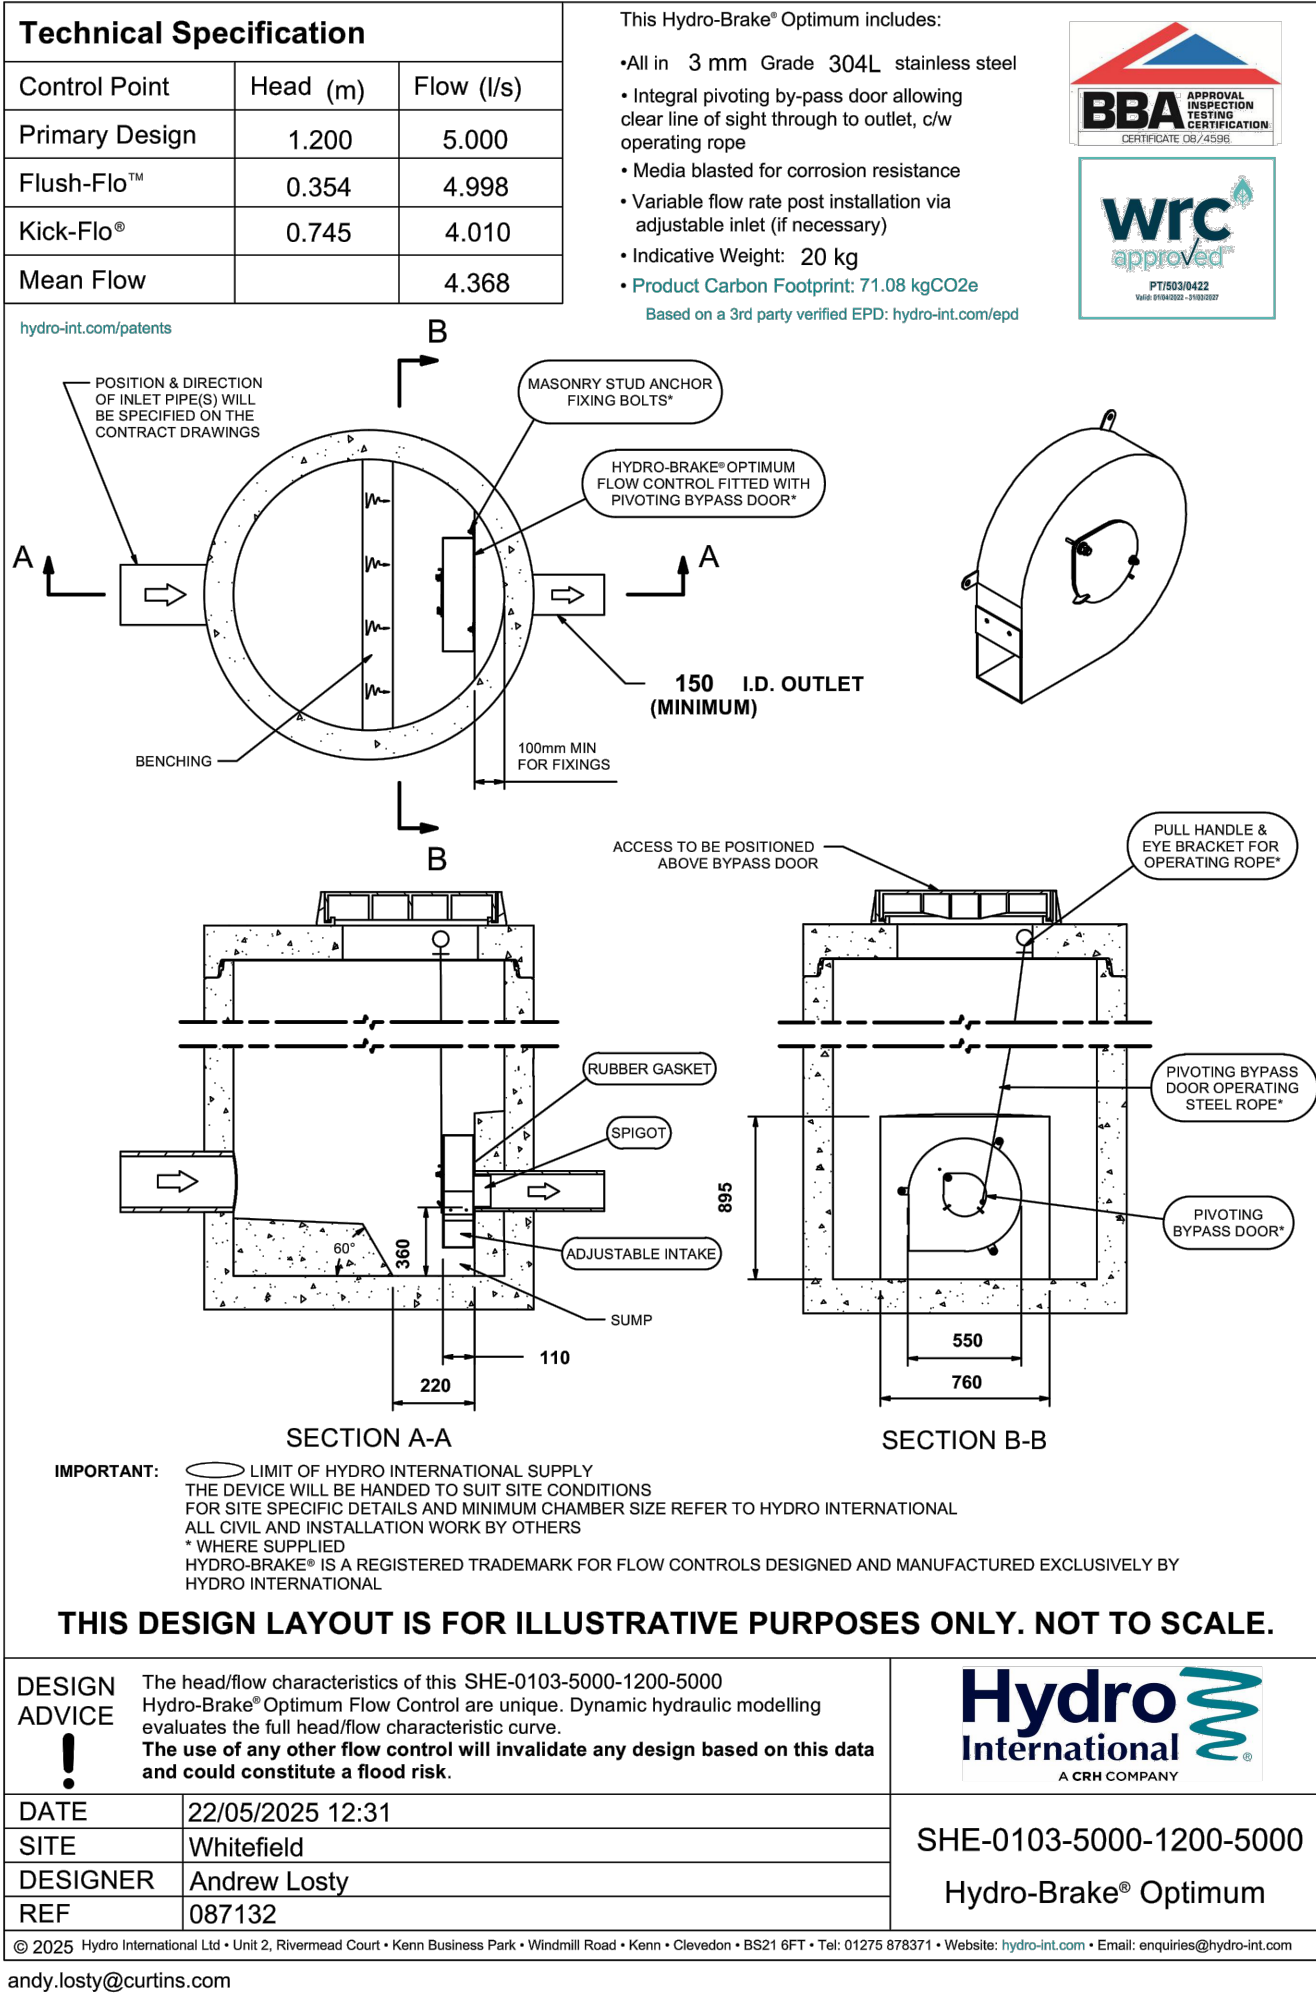

FLOW CONTROL MANUFACTURER DETAILS

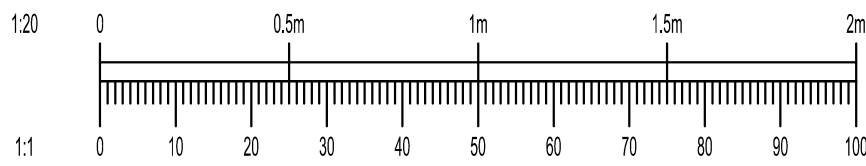

STAGE 3 ISSUE

05/06/25

ATL

MW

P01 ISSUED FOR COMMENT

01/05/25

KS

MW

Rev:

Description:

Date:

By:

Chkd:

Curtins

Merchant Exchange, 17-19 Whitworth Street West, Manchester, M1 5WG

0161 236 2394

manchester@curtins.com

www.curtins.com

Civils & Structures • Transport Planning • Environmental • Infrastructure • Geotechnical • Conservation & Heritage • Principal Designer

Birmingham • Bristol • Cambridge • Cardiff • Douglas • Dublin • Edinburgh • Glasgow • Kendal • Leeds • Liverpool • London • Manchester • Nottingham

Status:

STAGE 3

S3

Project:

WHITEFIELD MEDICAL CENTRE

Orig Title:

DRAINAGE DETAILS SHEET 3

Drawn By

KS

Designed By

MW

Checked By

MW

Date

01/05/2025

Scales @ A1

1:20

Project No • Originator • Function • Spatial • Form • Discipline • Number

Revision

087132 - CUR-XX-XX-DR-C- 92522

P02