

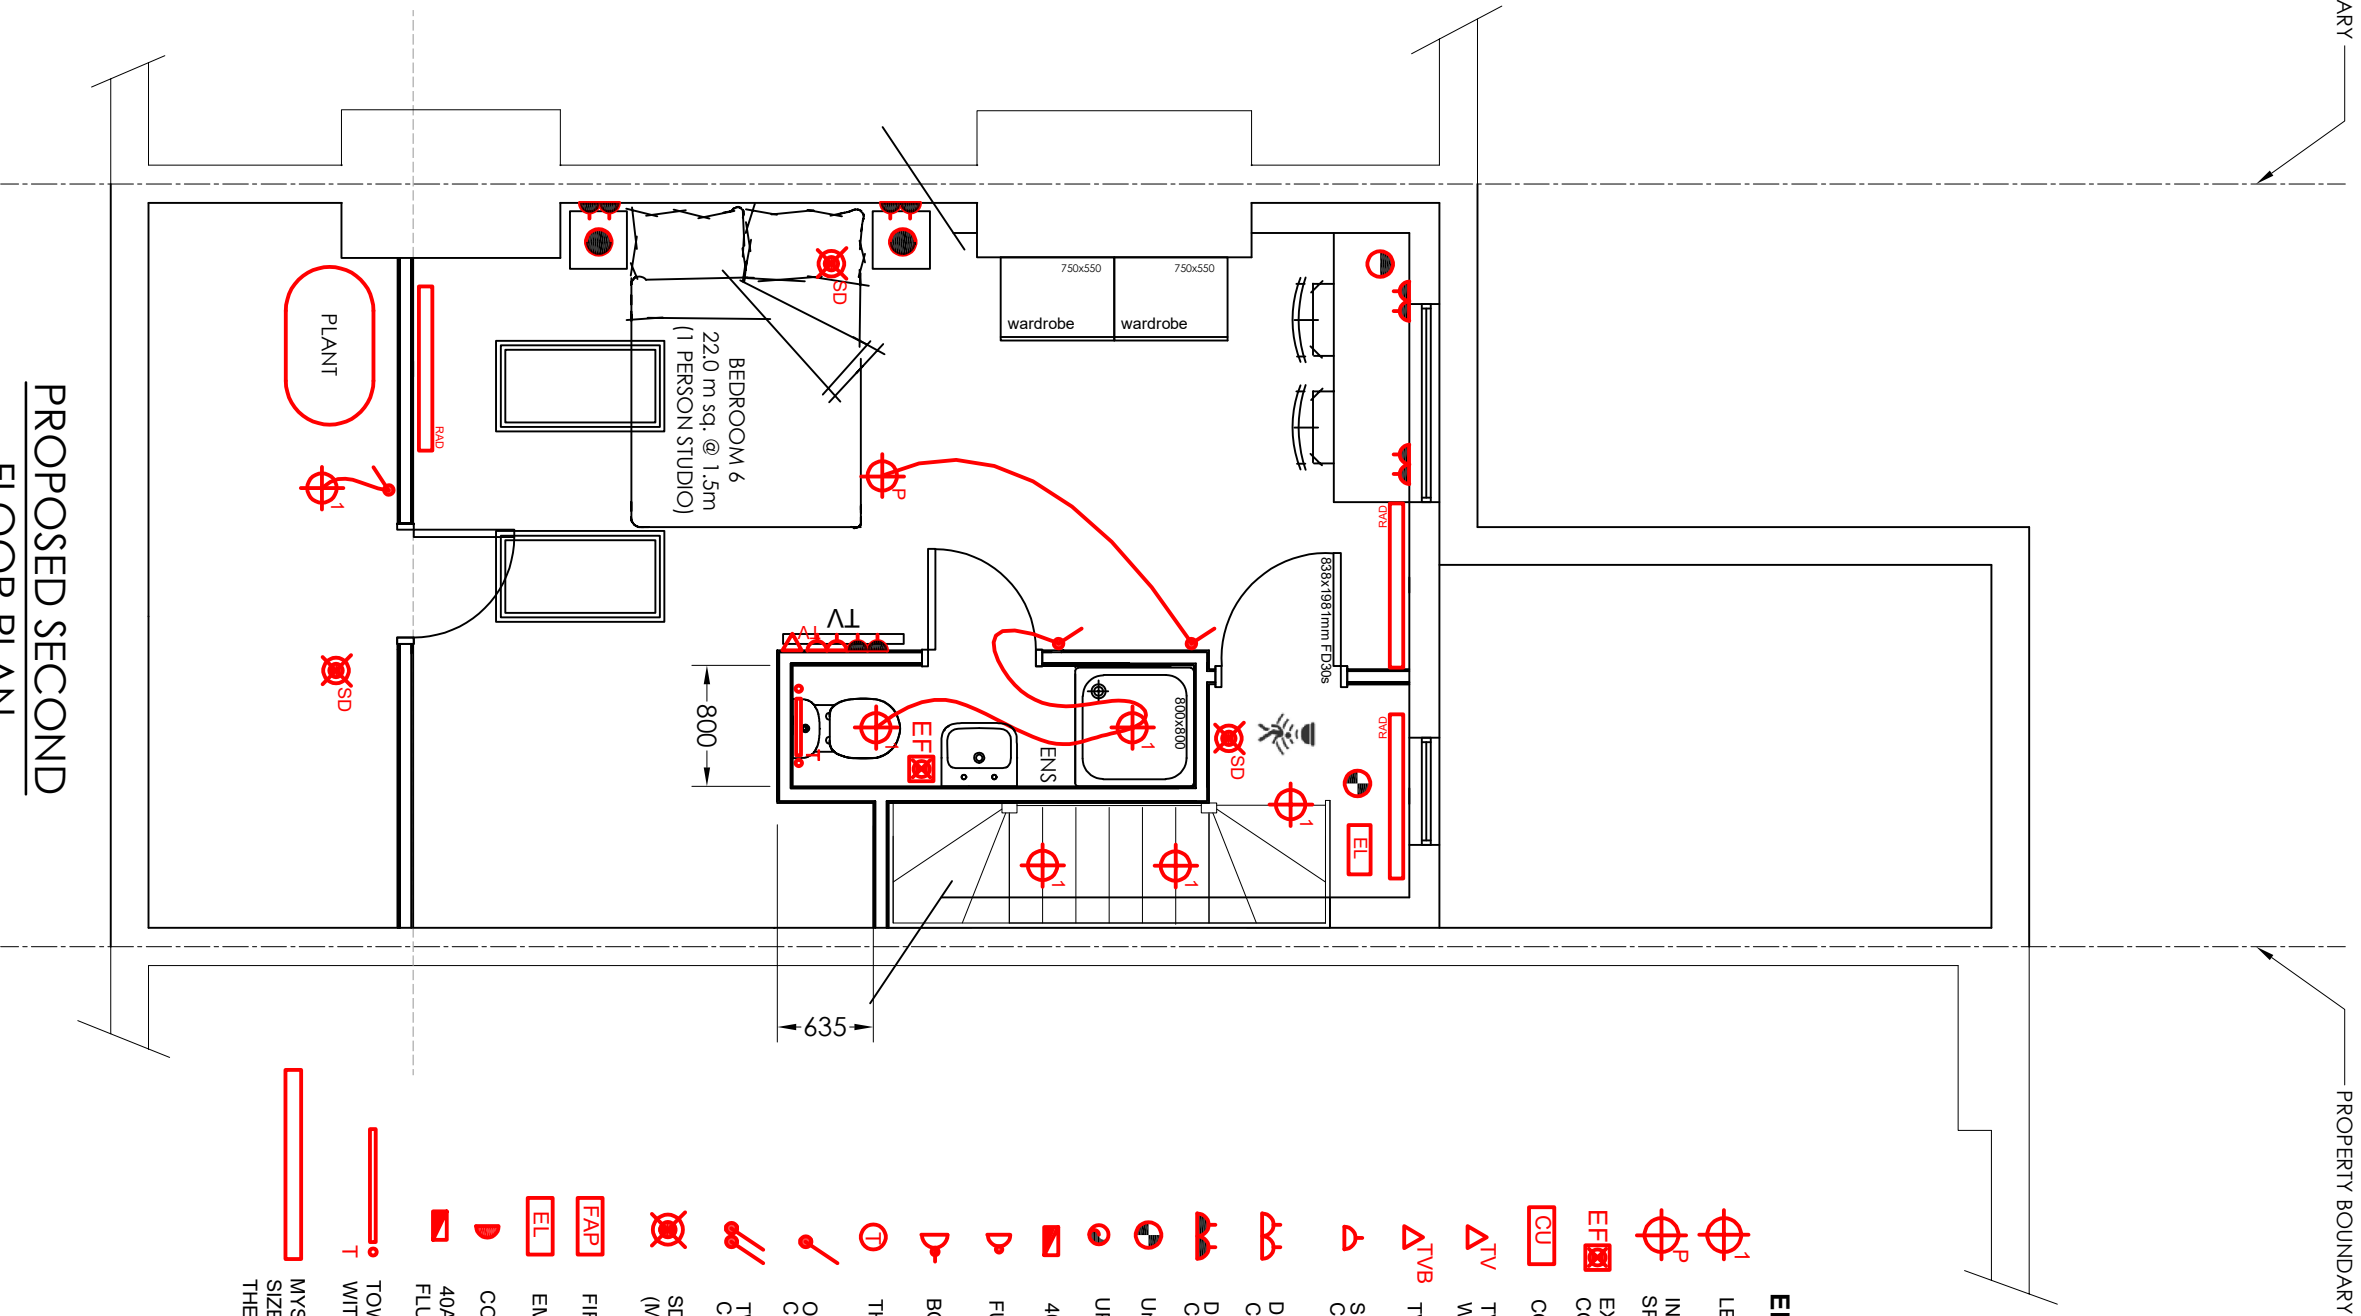
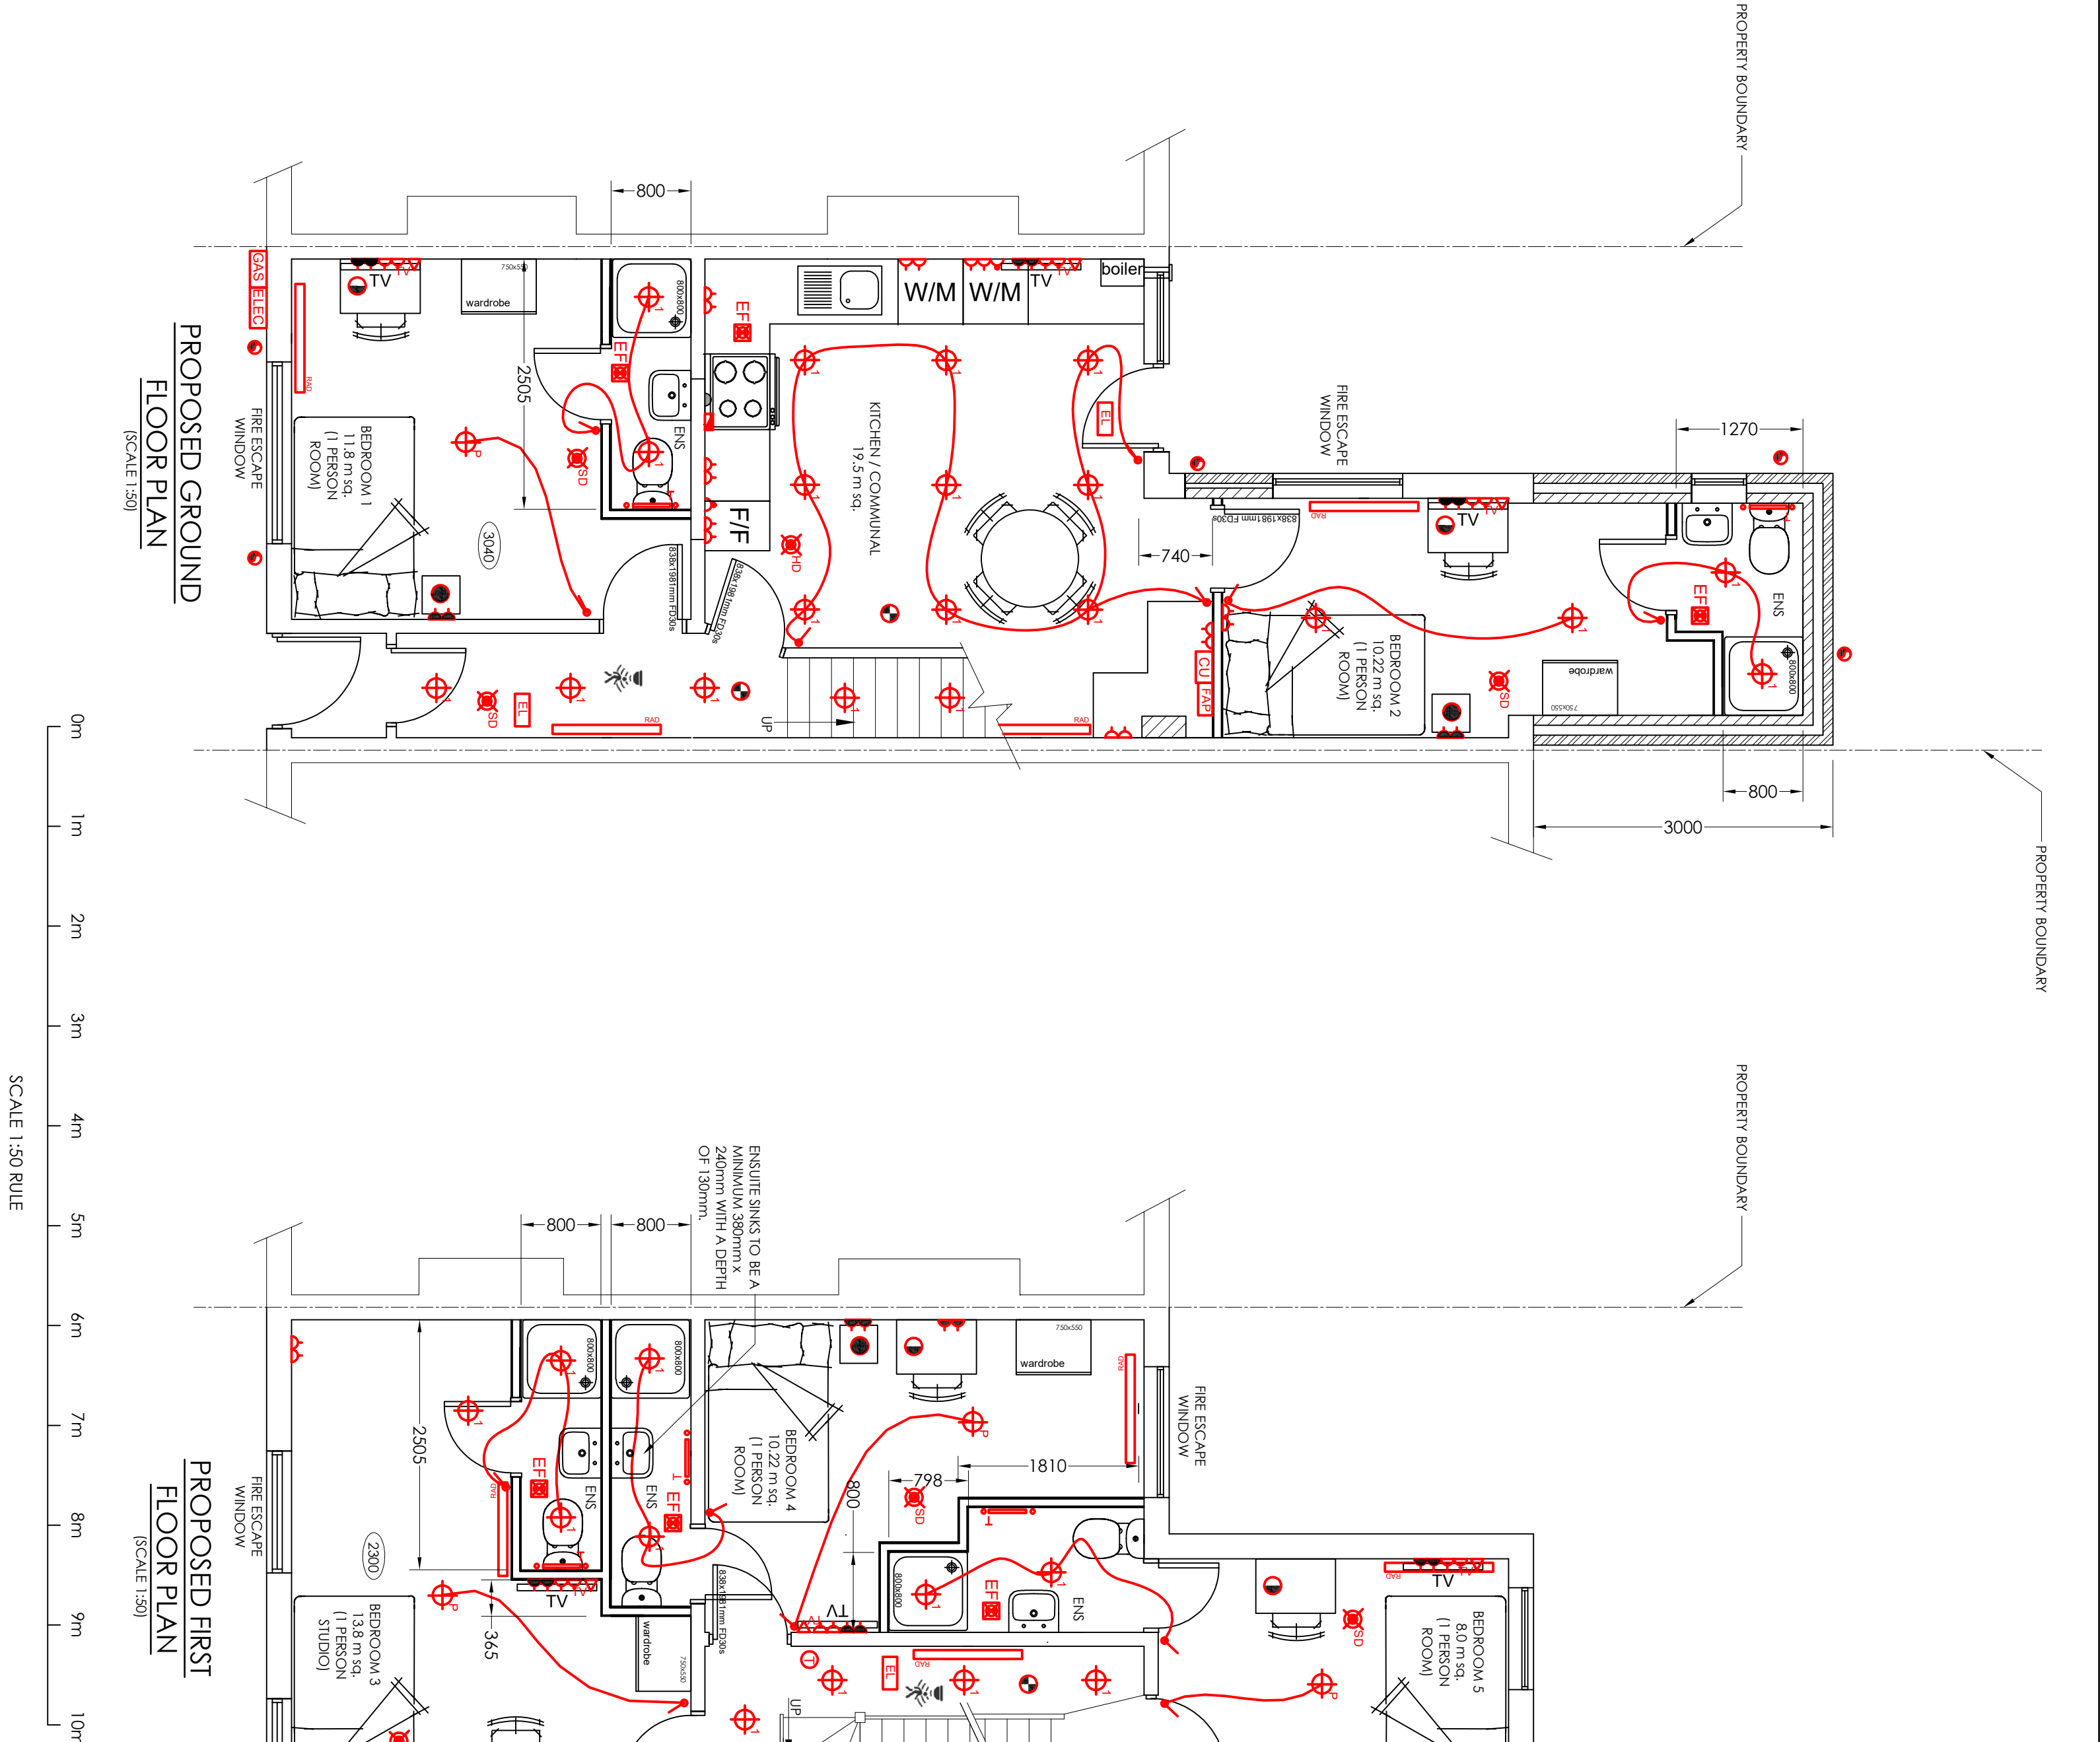


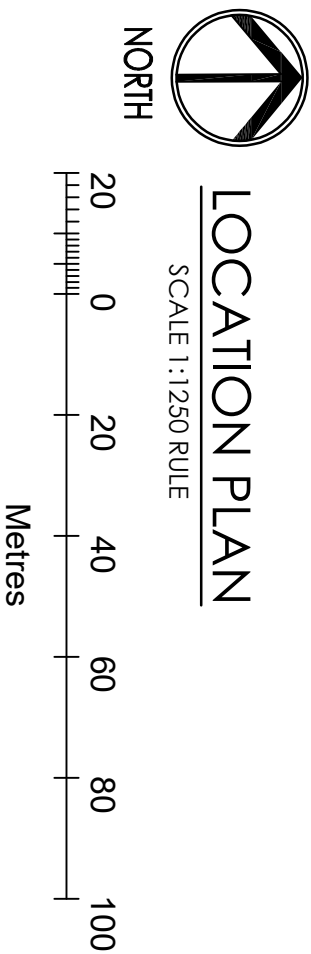

- ELECTRICAL LEGEND**
- LED DOWNLIGHT - COLOUR WARM WHITE
 - INSTALL LED PENDANT LIGHT TO CLIENTS SPECIFICATION
 - EXTRACT FAN (COOKER HOOD TO COMMUNAL KITCHEN AND STUDIOS)
 - CONSUMER UNIT
 - TV / MEDIA UNIT (WITH WHITE DOUBLE SOCKET)
 - TV BOOSTER SOCKET
 - SINGLE SOCKET - FINISH BRUSH CHROME
 - DOUBLE SOCKET - FINISH BRUSH CHROME
 - DOUBLE SOCKET - FINISH BRUSH CHROME (WITH LESS)
 - UP / DOWN LIGHT
 - 40A COOKER/NOB SWITCH
 - FUSED SPUR - 16K WHITE
 - BOILER SWITCH - 16K WHITE
 - THERMOSTAT
 - ONE GANG SWITCH - FINISH SATIN CHROME
 - TWO GANG SWITCH - FINISH SATIN CHROME
 - SD SMOKE DETECTOR (MANS OPERATED 1.3 SYSTEM)
 - FIRE ALARM PANEL
 - EMERGENCY LIGHTING
 - COOKER CONNECTION UNIT - 16K WHITE
 - 40A COOKER/NOB SWITCH - FLUSH PLATE SATIN STAINLESS STEEL
 - TOWER RADIATOR COLOUR WHITE SIZE TO SUIT, WITH INDIVIDUAL THERMOSTATIC CONTROLS SIZE TO SUIT, WITH INDIVIDUAL THERMOSTATIC VALVES
 - WALL DESK LIGHT WITH WALL SWITCH
 - PENDANT CEILING LIGHT WITH WALL SWITCH
 - PIR SENSOR
 - SINKS TO ENSUITE MINIMUM 380 x 240 T

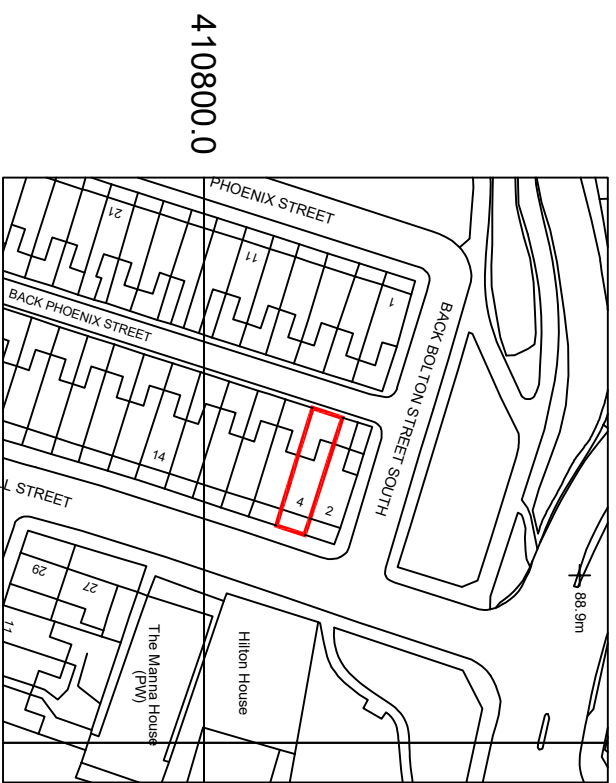

REV.	DATE	DESCRIPTION
ISSUED FOR APPROVAL		
Email - rich@architectural.co.uk		
Mobile - 0786628389		
Website - www.ndarchitectural.co.uk		
NB Architectural Design		
SCHEME - CONVERSION TO 6 BED, 6 PERSON HMO.		
PROPERTY ADDRESS - BURY, LANCASHIRE, BL9 0HE.		AI SCALE
TITLE - HMO FLOOR PLANS AND LOCATION PLAN.		DATE
DWG No - IS-NOM-IDC-001		REV.