




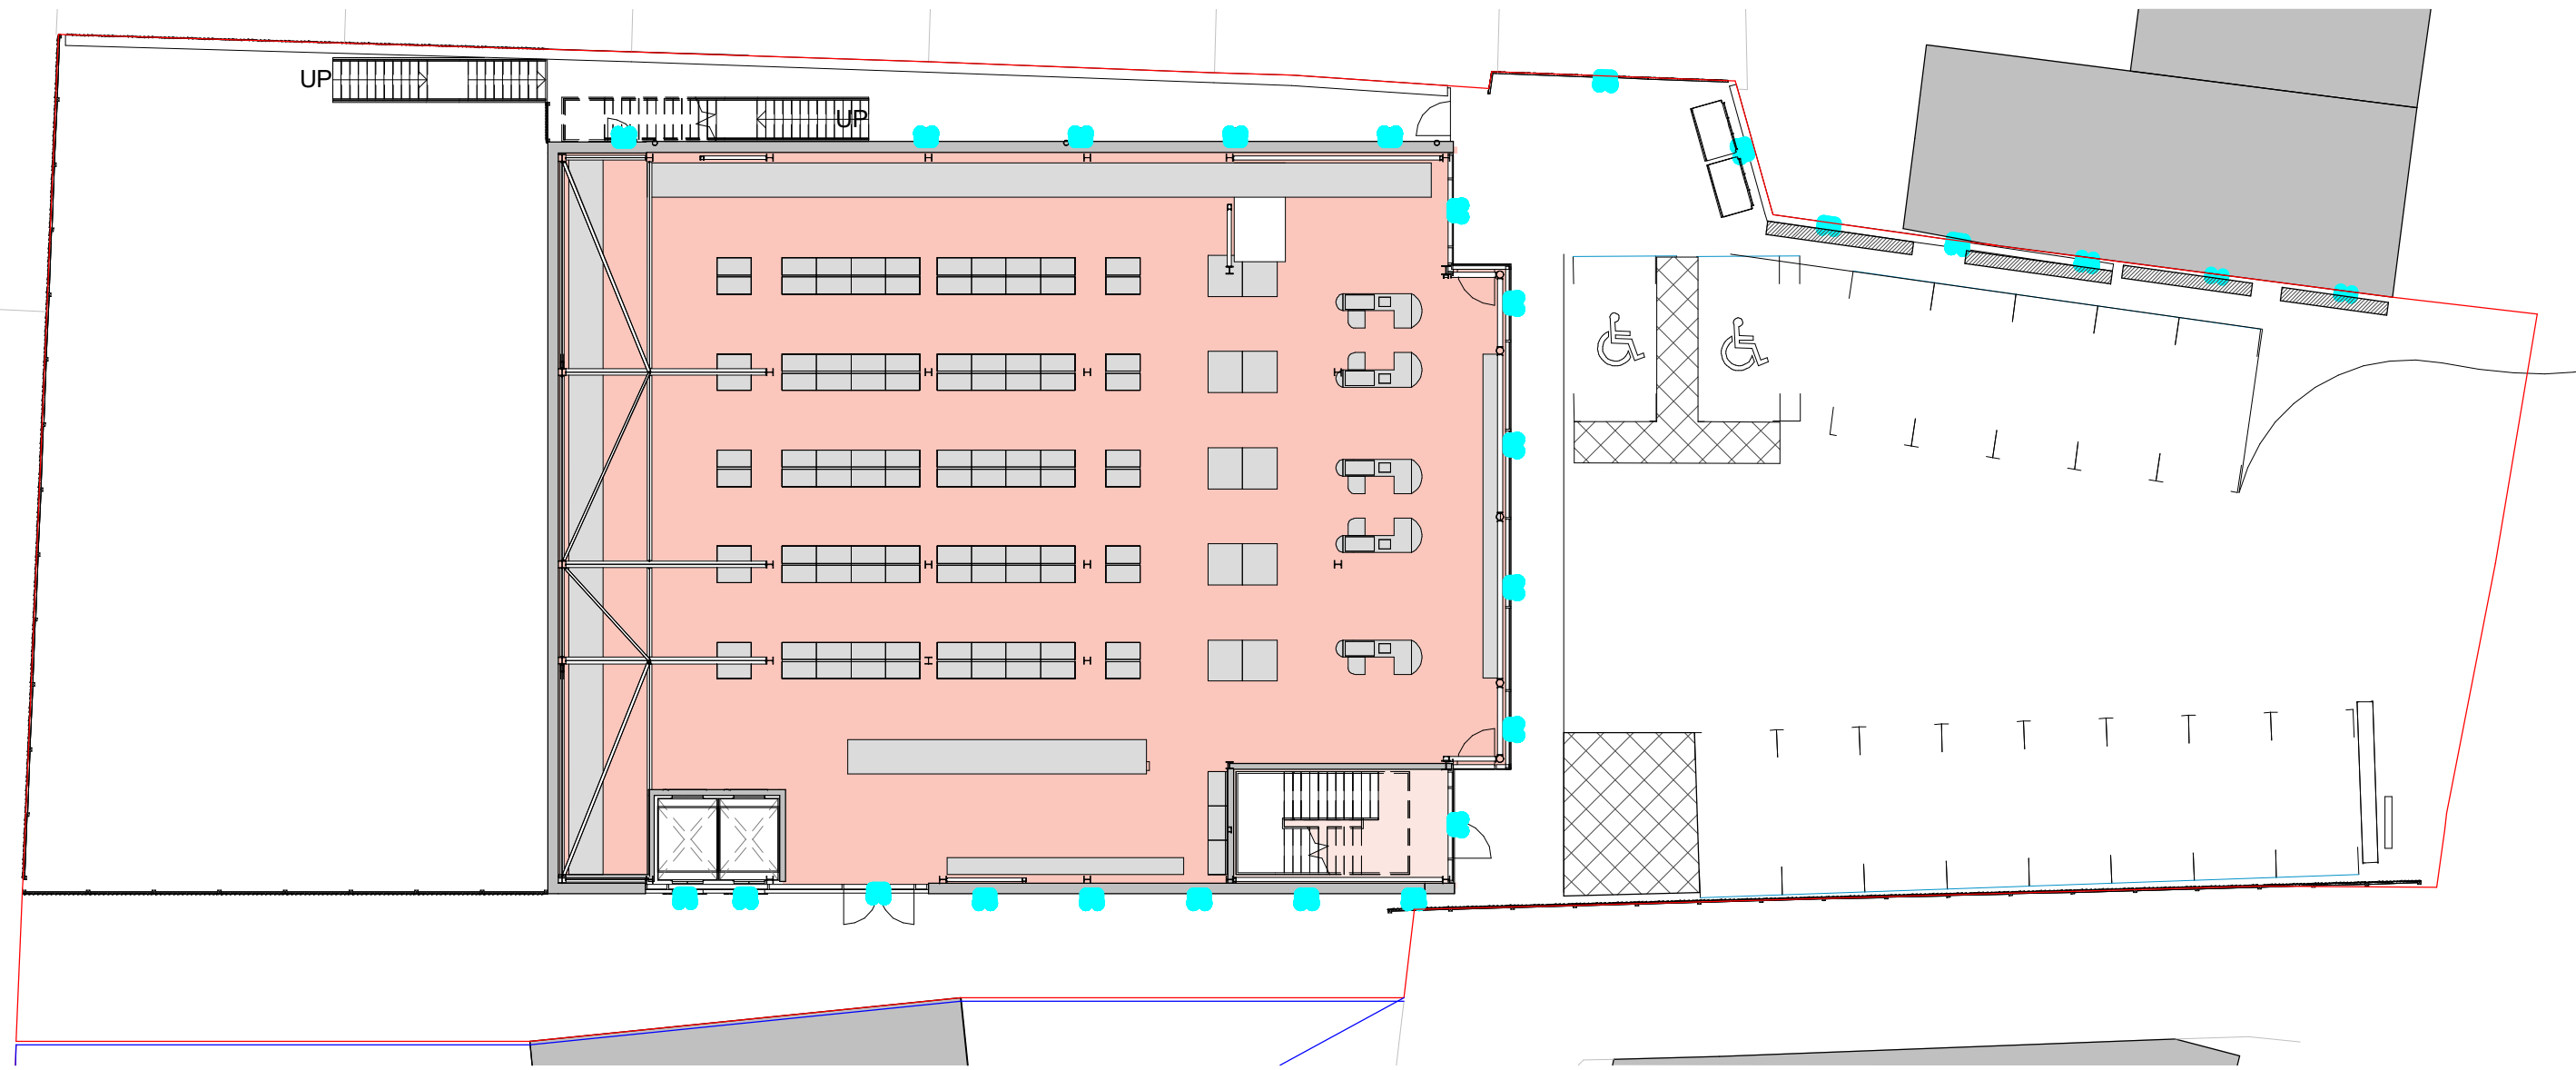



1. Level 0 - Lighting Plan
1 : 200

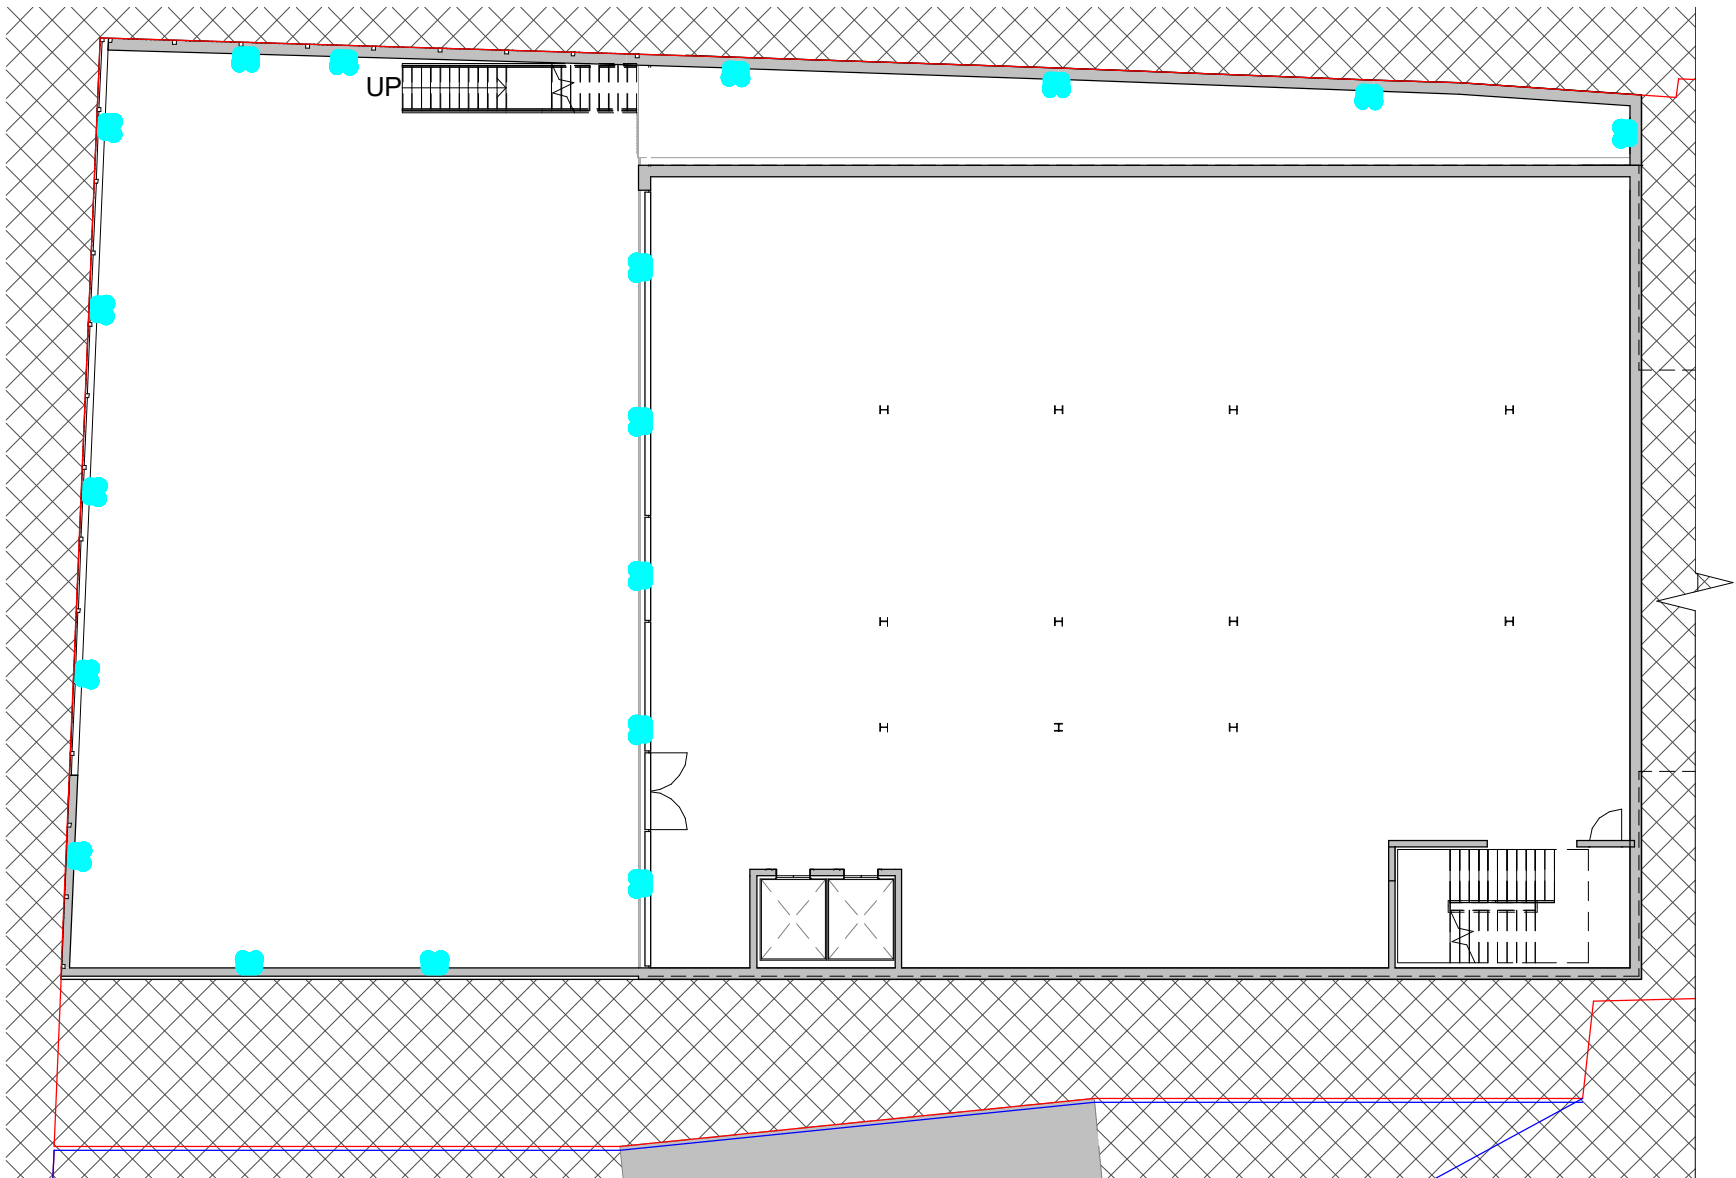

2. Level B1 - Lighting Plan
1 : 200

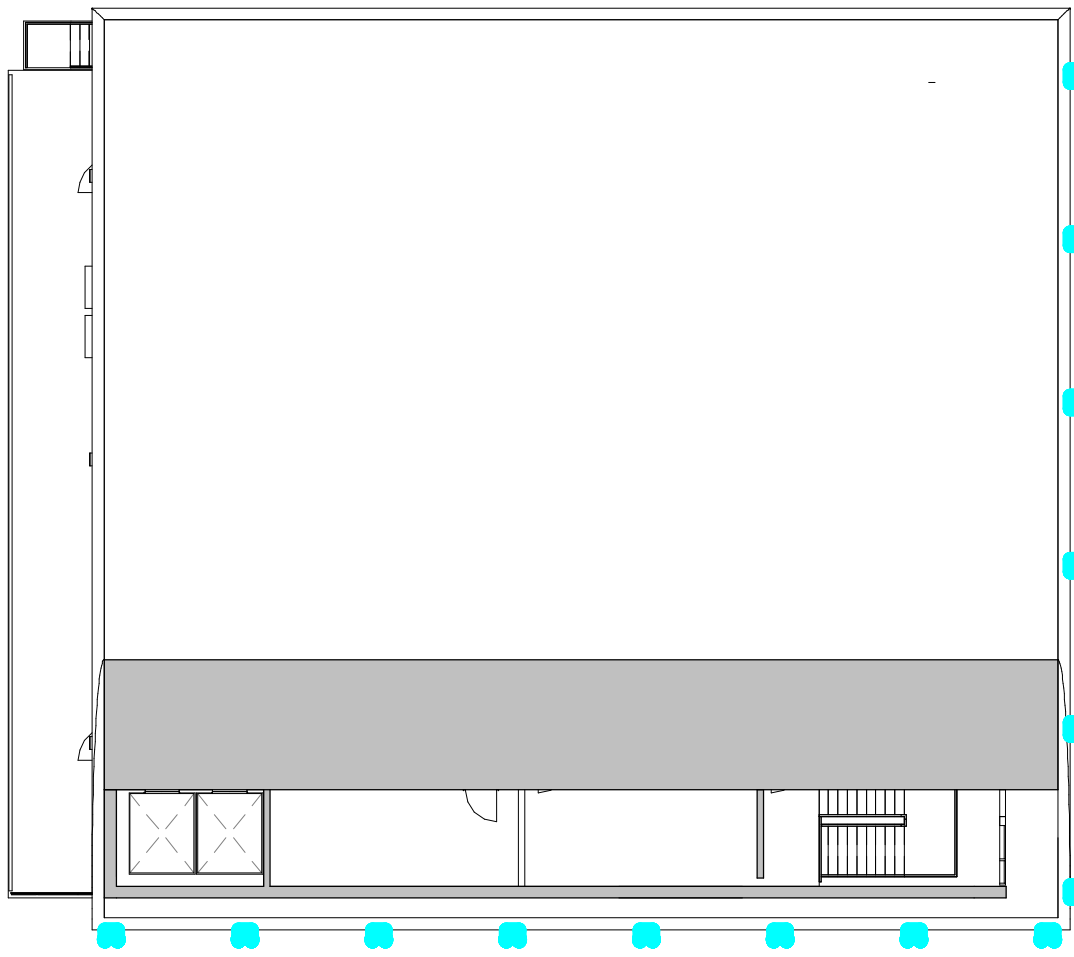

 
7. Level 1 - Lighting Plan
1 : 200

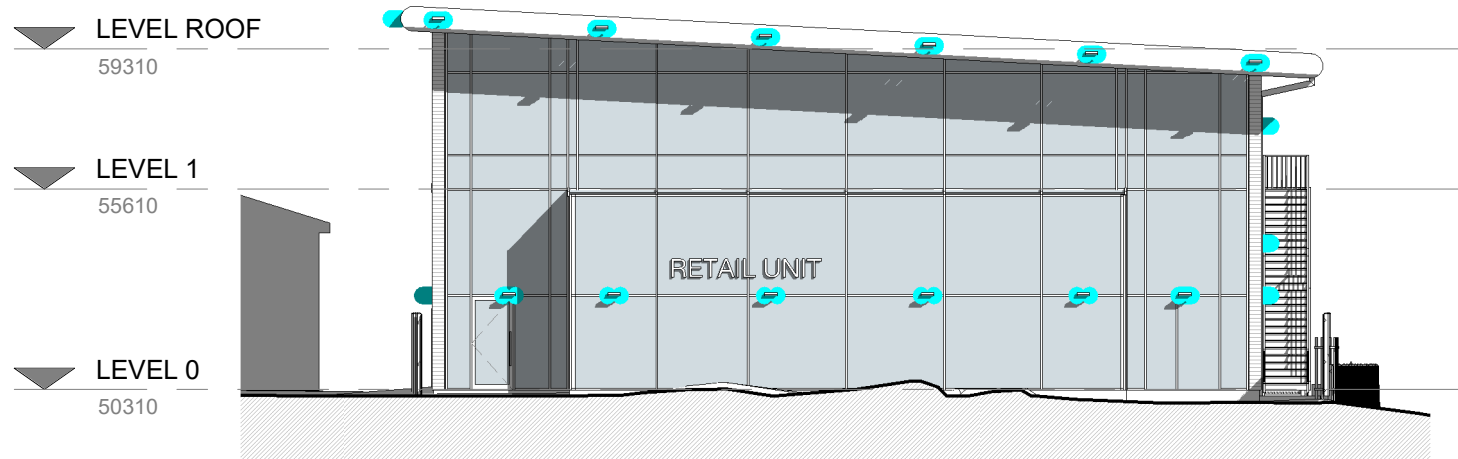


3. Front - Proposed - Lighting
1 : 200



4. Left Side - Proposed - Lighting
1 : 200

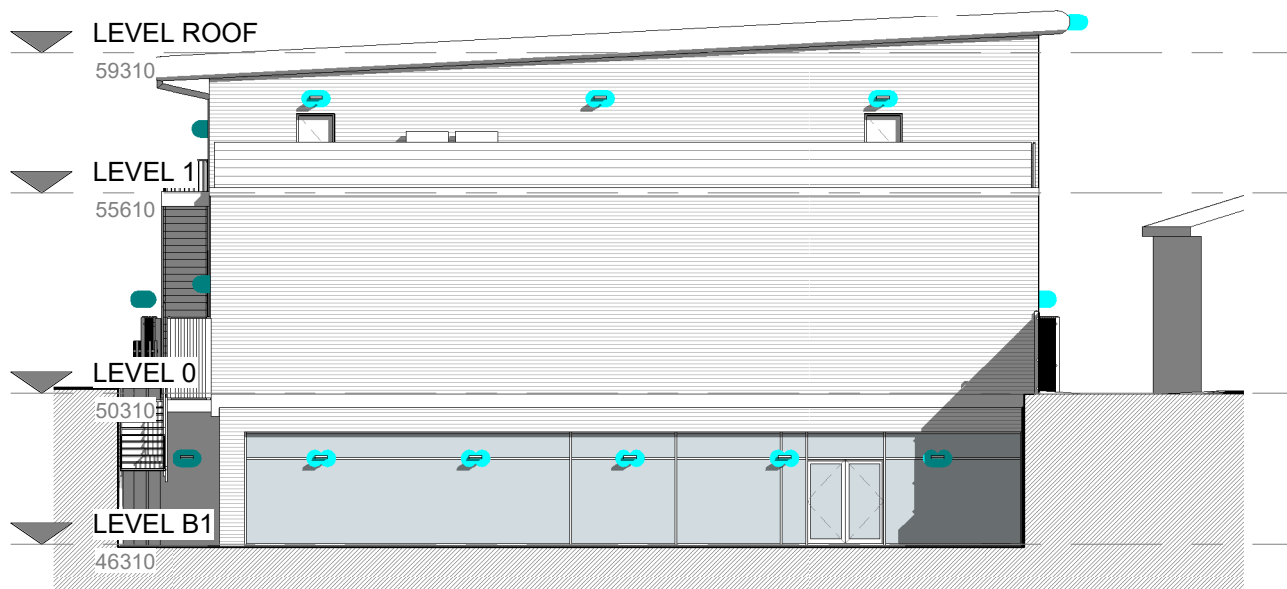

5. Rear - Proposed - Lighting
1 : 200

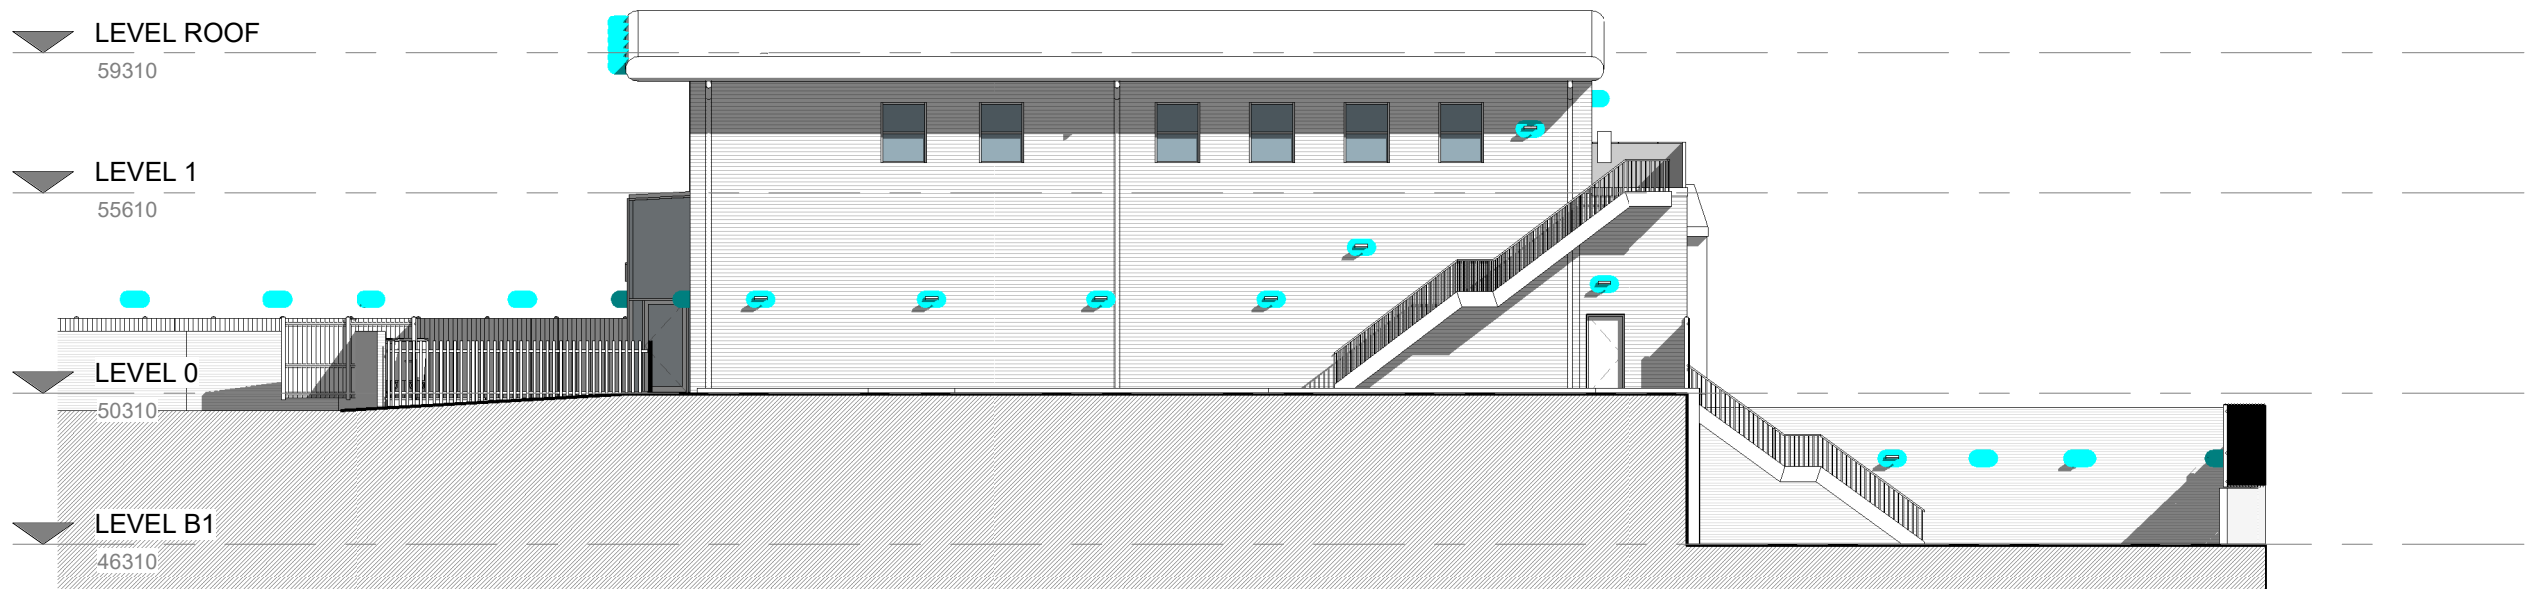

6. Right Side - Proposed - Lighting
1 : 200

LEGEND:

 Ledvion LV50013 200W 24000 lumen LED floodlight installed angled downwards and towards the building



2 0 2 4 6 8 10
SCALE 1:200 m

PROJECT	SCALE & A1	DATE	DRAWN BY
Unimore	As indicated	04 DEC 2024	SP
CLIENT	STATUS		
Unimore Ltd	Planning		
TITLE	PROJECT NO.	DRAWING NO.	REV.
Lighting Plan	DA14079.2.	402.	
NOTES			
THIS DRAWING MUST NOT BE REPRODUCED WITHOUT PRIOR WRITTEN CONSENT. ALL DIMENSIONS AND MATERIALS SHALL BE CHECKED AND CONFIRMED IN THE FIELD AND CORRECTED TO BE IN ACCORDANCE WITH THE REQUIREMENTS OF THE PROJECT AND THE CLIENT'S REQUIREMENTS. ALL DIMENSIONS ON THIS DRAWING ARE IN MILLIMETRES UNLESS OTHERWISE STATED.			

DA DEBTAL
ARCHITECTURE
www.debtal.co.uk