


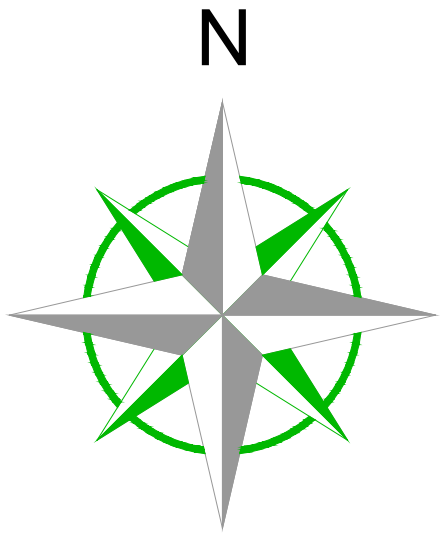

OVERALL SITE PLAN SHOWING LOCATION OF PROPOSED
SPRINKLER TANKS, PUMP ROOM & GRP KIOSK
SCALE NTS @ A1



CONSTRUCTION - It is considered that the proposed works are within the competency of a suitably experienced contractor subject to the Principal Contractor providing Risk Assessments and Method Statements.

LIFETIME/USAGE - The area of the site associated with these works has no exceptional features that present a hazard to potential users.

DECOMMISSIONING/DEMOLITION - There are no unusual aspects of this site that require highlighting in the event that the structure is demolished.

RECORD INFORMATION - The Health and Safety file for the site should be thoroughly studied and its implications assessed by any future designers or contractors appointed to work on this structure.

EXCEPTIONS - Any exceptions to the above statements are noted on the drawing.

WORKING TOWARDS NET
ZERO EMISSIONS


Engineers
Declare Climate
and Biodiversity
Emergency

GENERAL NOTES

- 1: This drawing to be read in conjunction with Francis Bradshaw Consulting drawings and all other relevant drawings and specifications.
- 2: Do not scale this drawing. Any discrepancies are to be reported to the Engineer immediately.
- 3: All dimensions and levels to be checked on site by the Contractor prior to preparing any working drawings or commencing work on site.
- 4: All work by the contractor must be carried out in such a way that all requirements under the Health and Safety at Work Act and CDM Regulations 2015 are satisfied.

INDICATES BORE HOLE AT
GRID REFERENCE
382879.7E, 410878.5N

INDICATES APPLICATION
BOUNDARY

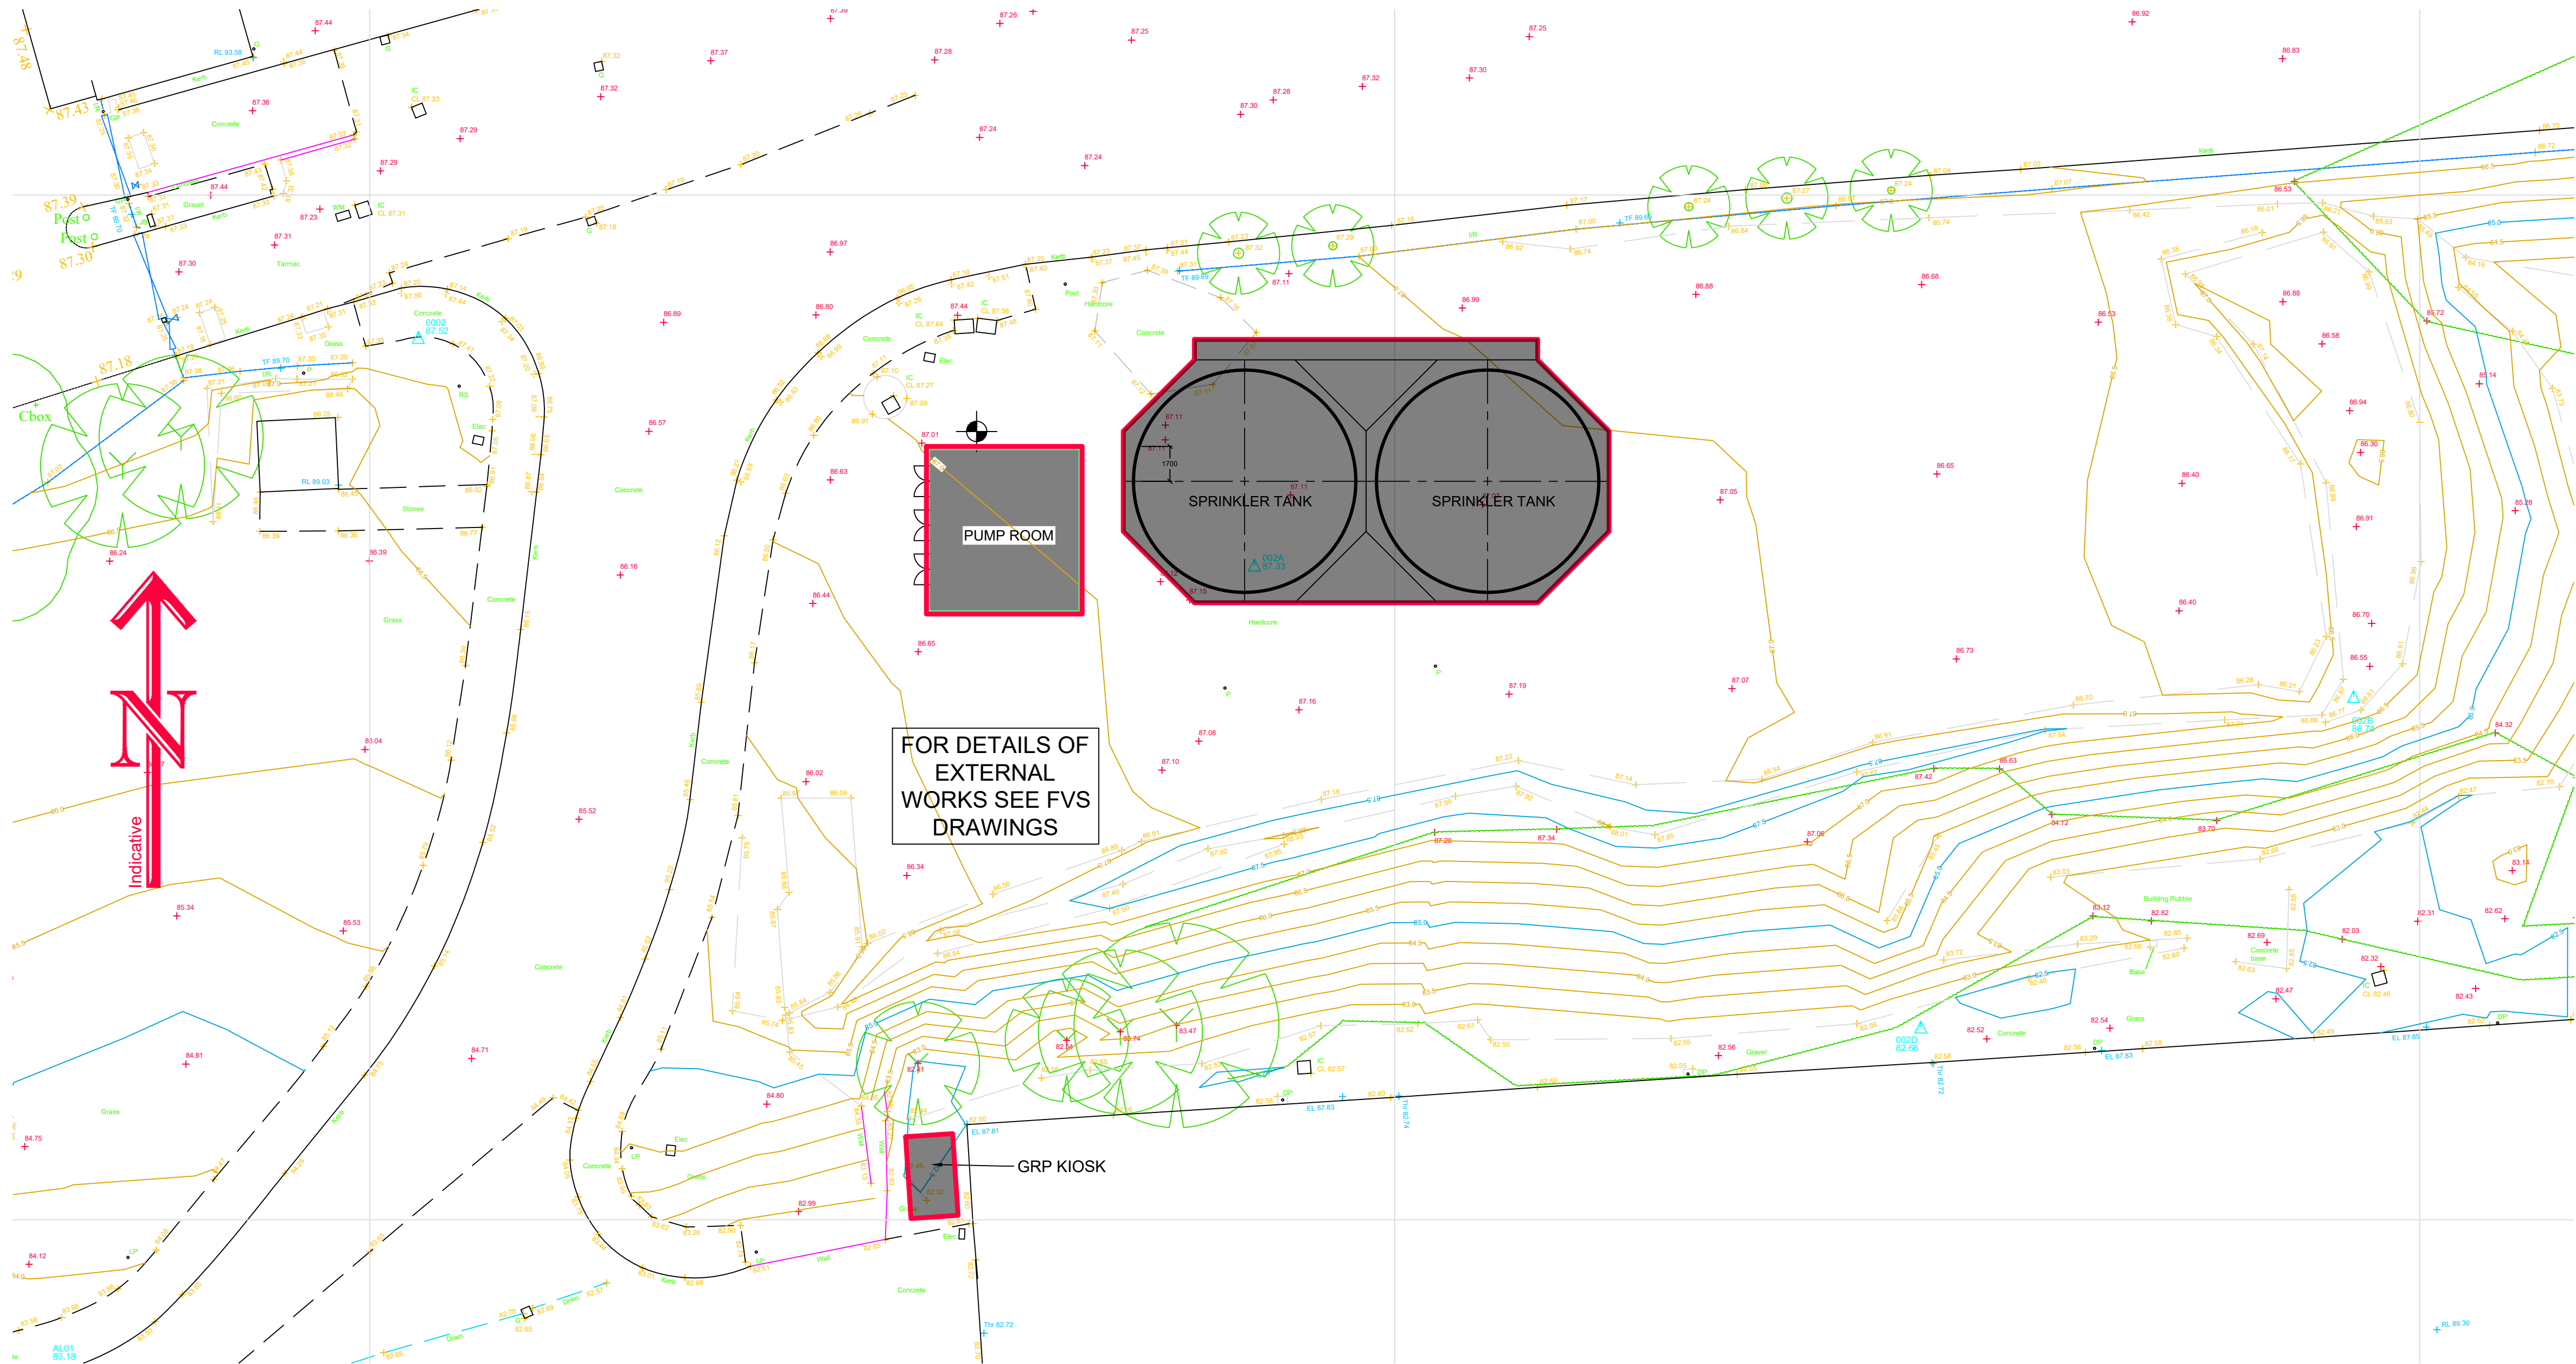

PROPOSED BLOCK PLAN
SCALE 1:200 @ A1



SCALE BAR 1:200

01	FIRST ISSUE	01.11.23	AH	-
REF	REVISION	DATE	CAD	APRVD

STATUS: FOR INFORMATION ONLY

THIS DRAWING IS COPYRIGHT. IT IS SENT TO YOU IN CONFIDENCE. IT MUST NOT BE COPIED, USED OR DISCLOSED TO THIRD PARTIES WITHOUT OUR PERMISSION. IT REMAINS OUR PROPERTY AND MUST BE RETURNED UPON REQUEST.

CLIENT:



JOB:

PROPOSED SPRINKLER TANKS &
ASSOCIATED WORKS FOR TETROSYL GROUP LTD,
BURY, BL9 7NY

DRAWING TITLE:

PROPOSED BLOCK PLAN

DRG No.:

3425-04-FBC-XX-XX-DR-S-001-S2-01

YEAR:

2023

SCALE:

AS SHOWN @ A1

DATE:

01.11.2023

DRAWN BY:

AH



Francis Bradshaw Consulting Ltd
Chartered Structural and Civil Engineers

Bank Chambers,
4-6 Church Street,
Wilmslow
SK9 1AU

www.fbpconsulting.co.uk
Wilmslow@fbpconsulting.co.uk

