


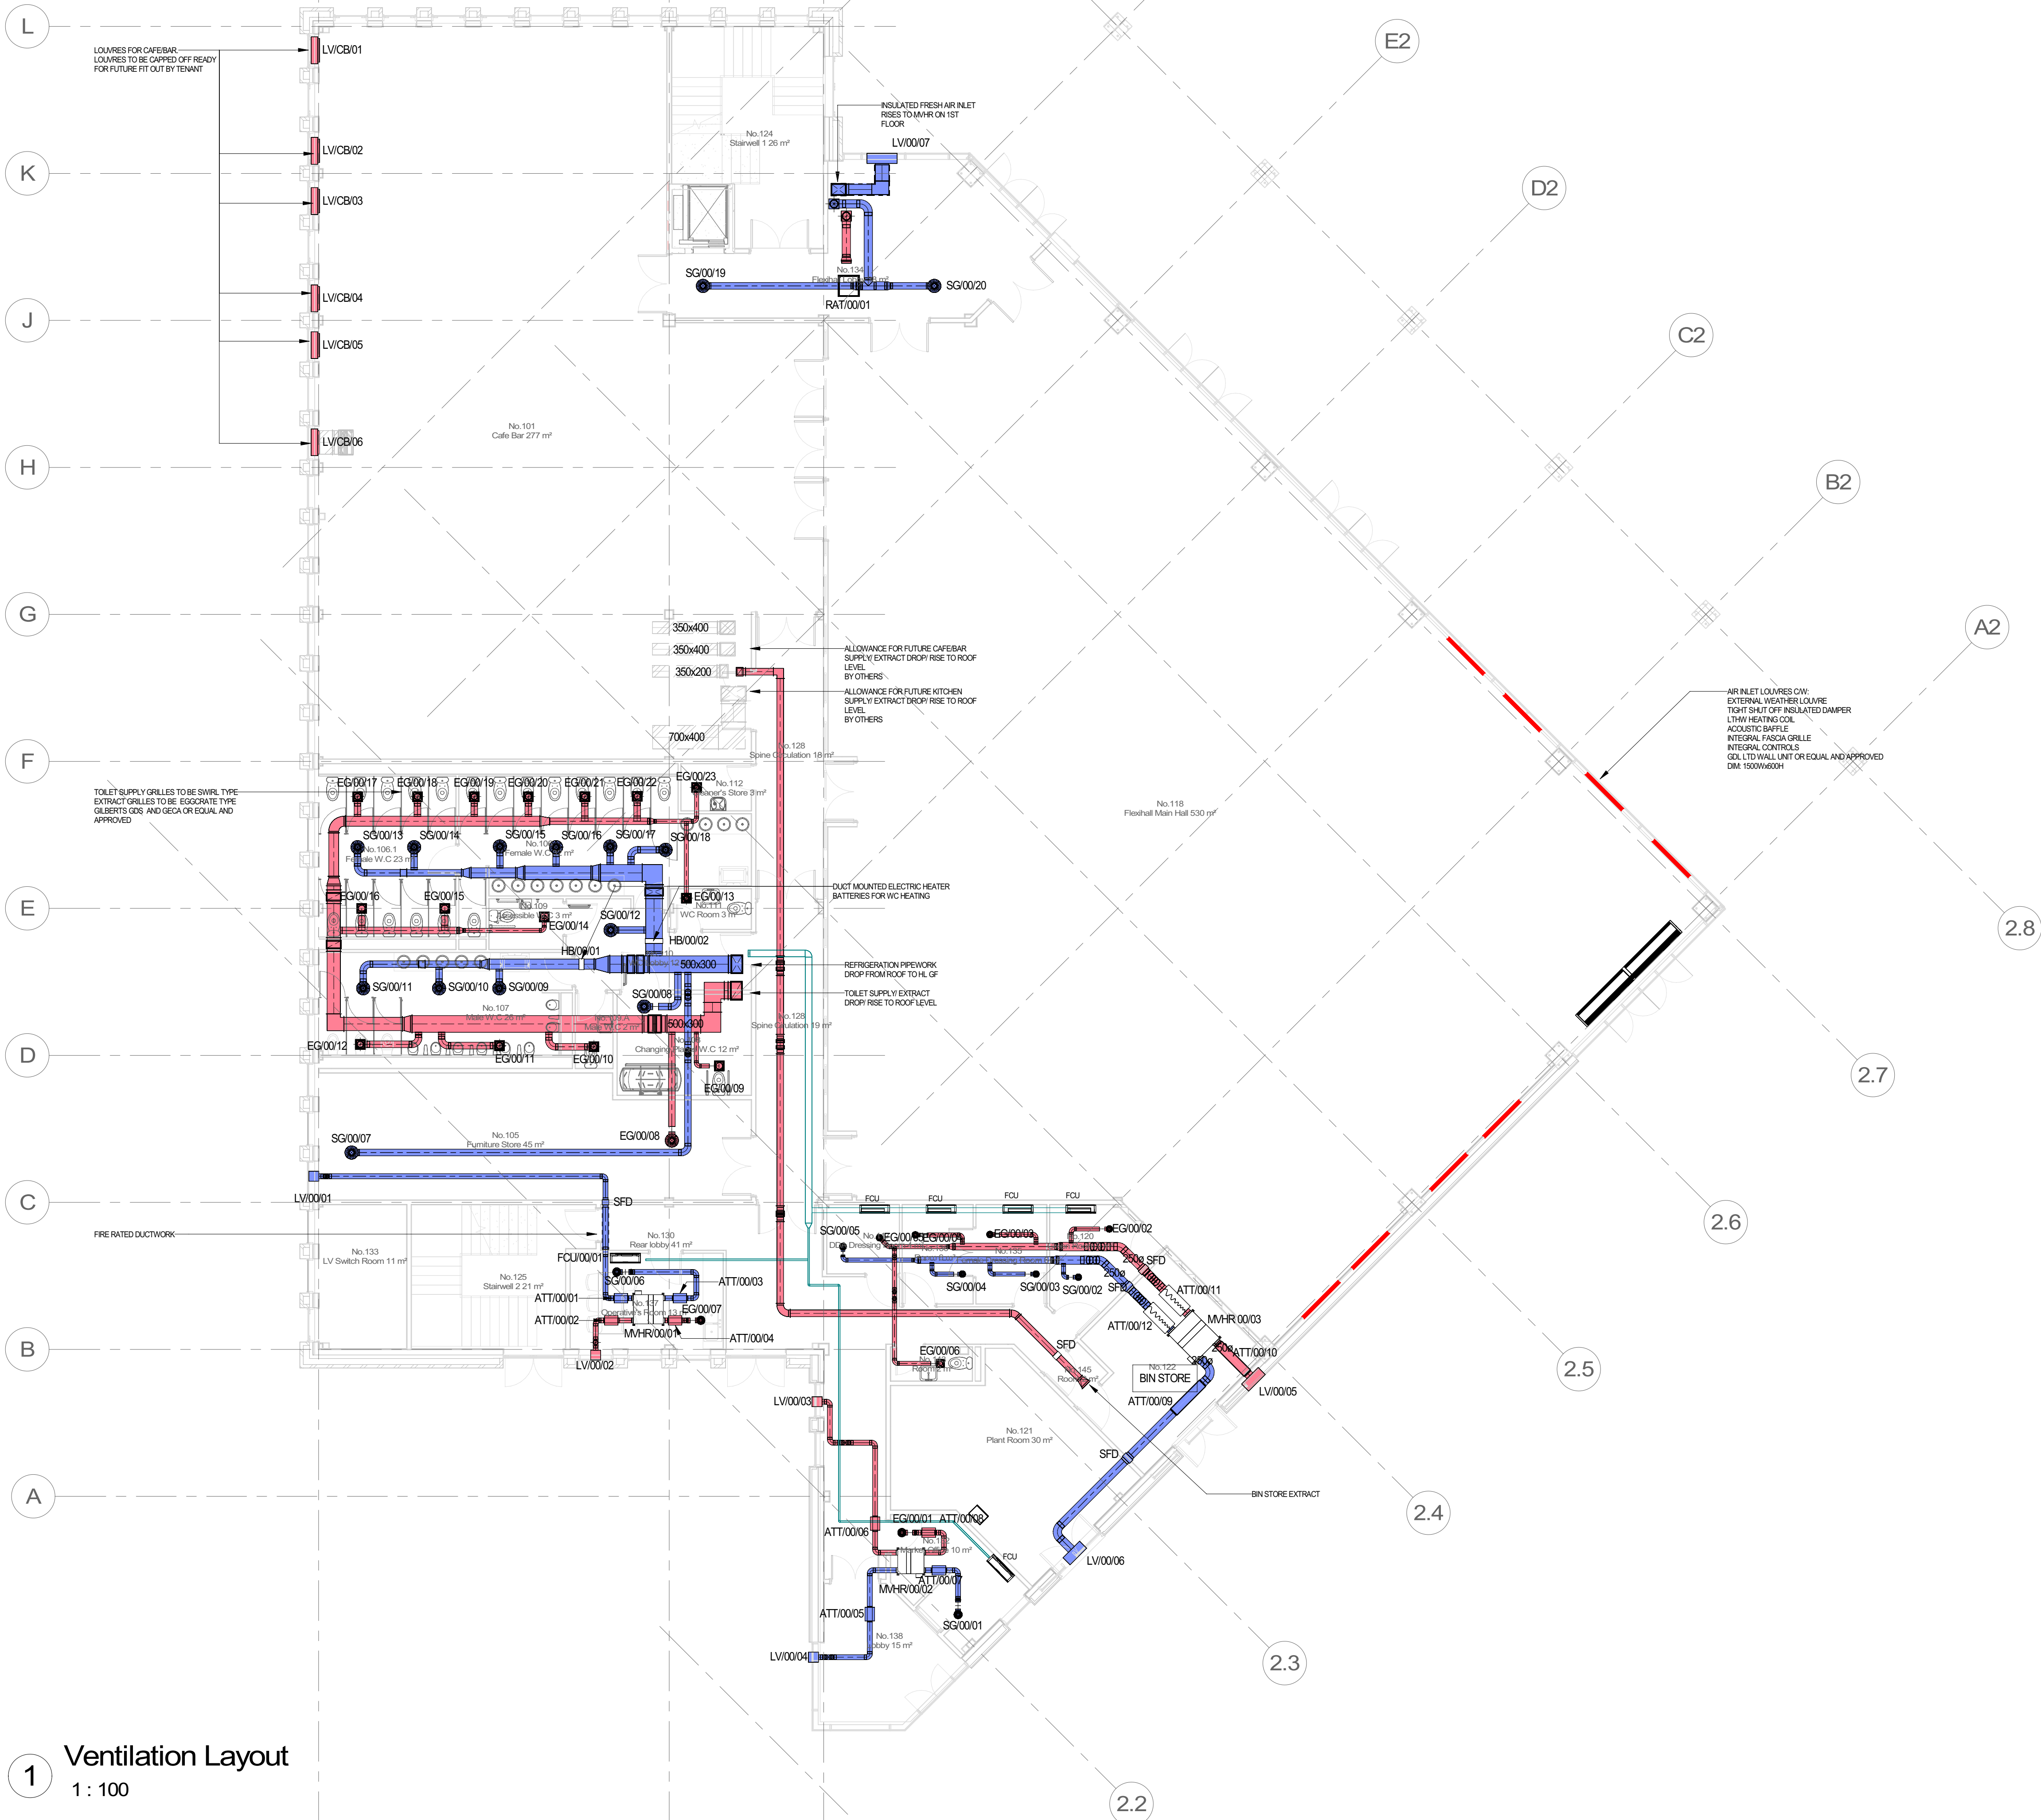

LOUVRES FOR CAFE BAR
LOUVRES TO BE CAPPED OFF READY
FOR FUTURE FIT OUT BY TENANT

TOILET SUPPLY GRILLES TO BE SWIRL TYPE
EXTRACT GRILLES TO BE EGSGRATE TYPE
GILBERTS G25 AND G24 OR EQUAL AND
APPROVED

FIRE RATED DUCTWORK

INSULATED FRESH AIR INLET
RISES TO MVHR ON 1ST
FLOOR

ALLOWANCE FOR FUTURE CAFE BAR
SUPPLY EXTRACT DROP RISE TO ROOF
LEVEL
BY OTHERS

ALLOWANCE FOR FUTURE KITCHEN
SUPPLY EXTRACT DROP RISE TO ROOF
LEVEL
BY OTHERS

DUCT MOUNTED ELECTRIC HEATER
BATTERIES FOR WC HEATING

REFRIGERATION PIPEWORK
DROP FROM ROOF TO H.L. GF

TOILET SUPPLY EXTRACT
DROP RISE TO ROOF LEVEL

AR INLET LOUVRES CW-
EXTERNAL WEATHER LOUVRE
TIGHT SHUT OFF INSULATED DAMPER
LTHW HEATING COIL
ACOUSTIC BAFFLE
INTERNAL FAN/GRILLE
INTEGRAL CONTROLS
GGL LTD WALL UNIT OR EQUAL AND APPROVED
DIM. 1500X600H

2.2

2.3

2.4

2.5

2.6

2.7

2.8

1 Ventilation Layout
1 : 100

This document and its contents are the property of the Purchaser/Employer and Crookes Walker Consulting. They may not be copied or reproduced in any way, in part or whole, without prior written approval of both parties. Violations will result in legal action. This drawing shall be read in conjunction with the CWC Mechanical and / or Electrical Specifications. DO NOT SCALE FROM THIS DRAWING

DESIGNERS RISK ASSESSMENT SCHEDULE
REFER TO APPENDIX 1 OF M&E SPECIFICATION FOR
DESIGNERS RISK ASSESSMENT SCHEDULE

DRAWING BACKGROUND(S):

- LEGEND
- EA - EXTRACT AIR
 - SA - SUPPLY AIR
 - REFRIGERATION PIPEWORK TRAY
 - AHU MAINTENANCE ZONE
 - SAFE ACCESS ROUTE
 - CONDENSER ATTENUATOR

MVHR - MECHANICAL VENTILATION HEAT RECOVERY
FCU - FAN COIL UNIT
AHU - AIR HANDLING UNIT
SFD - SMOKE FIRE DAMPER
ATT - ATTENUATOR

P4	22.02.23	STAGE 3 REDESIGN	AM	RW
P3	17.02.23	STAGE 3 REDESIGN	AM	RW
P2	16.09.22	PRELIMINARY	AM	RW
P1	09.08.22	PRELIMINARY	AM	RW
Rev	Date	Description	Eng	CWK

Suite 9a, Bloc, 17 Marble Street
Manchester M2 3AV
Tel: 0161 834 8858
The Plaza, Old Hall Street,
Liverpool L3 9QJ
Tel: 0151 600 5409
55 Colmore Row, Birmingham B3 2AA
Tel: 0121 262 4046
E-mail: admin@cwcon.co.uk
Website: www.cwcon.co.uk

Client
VINCI

Project
**BURY MARKET AND
FLEXI HALL**

Drawing Title
**GROUND FLOOR
VENTILATION LAYOUT**

Status
STAGE 3

Project No. 2451	Drawn AM	Scale / Paper Size 1 : 100 @ A1
Drawing No. BURMAR-CWC-V2-00-DR-M-5701	Rev P4	