




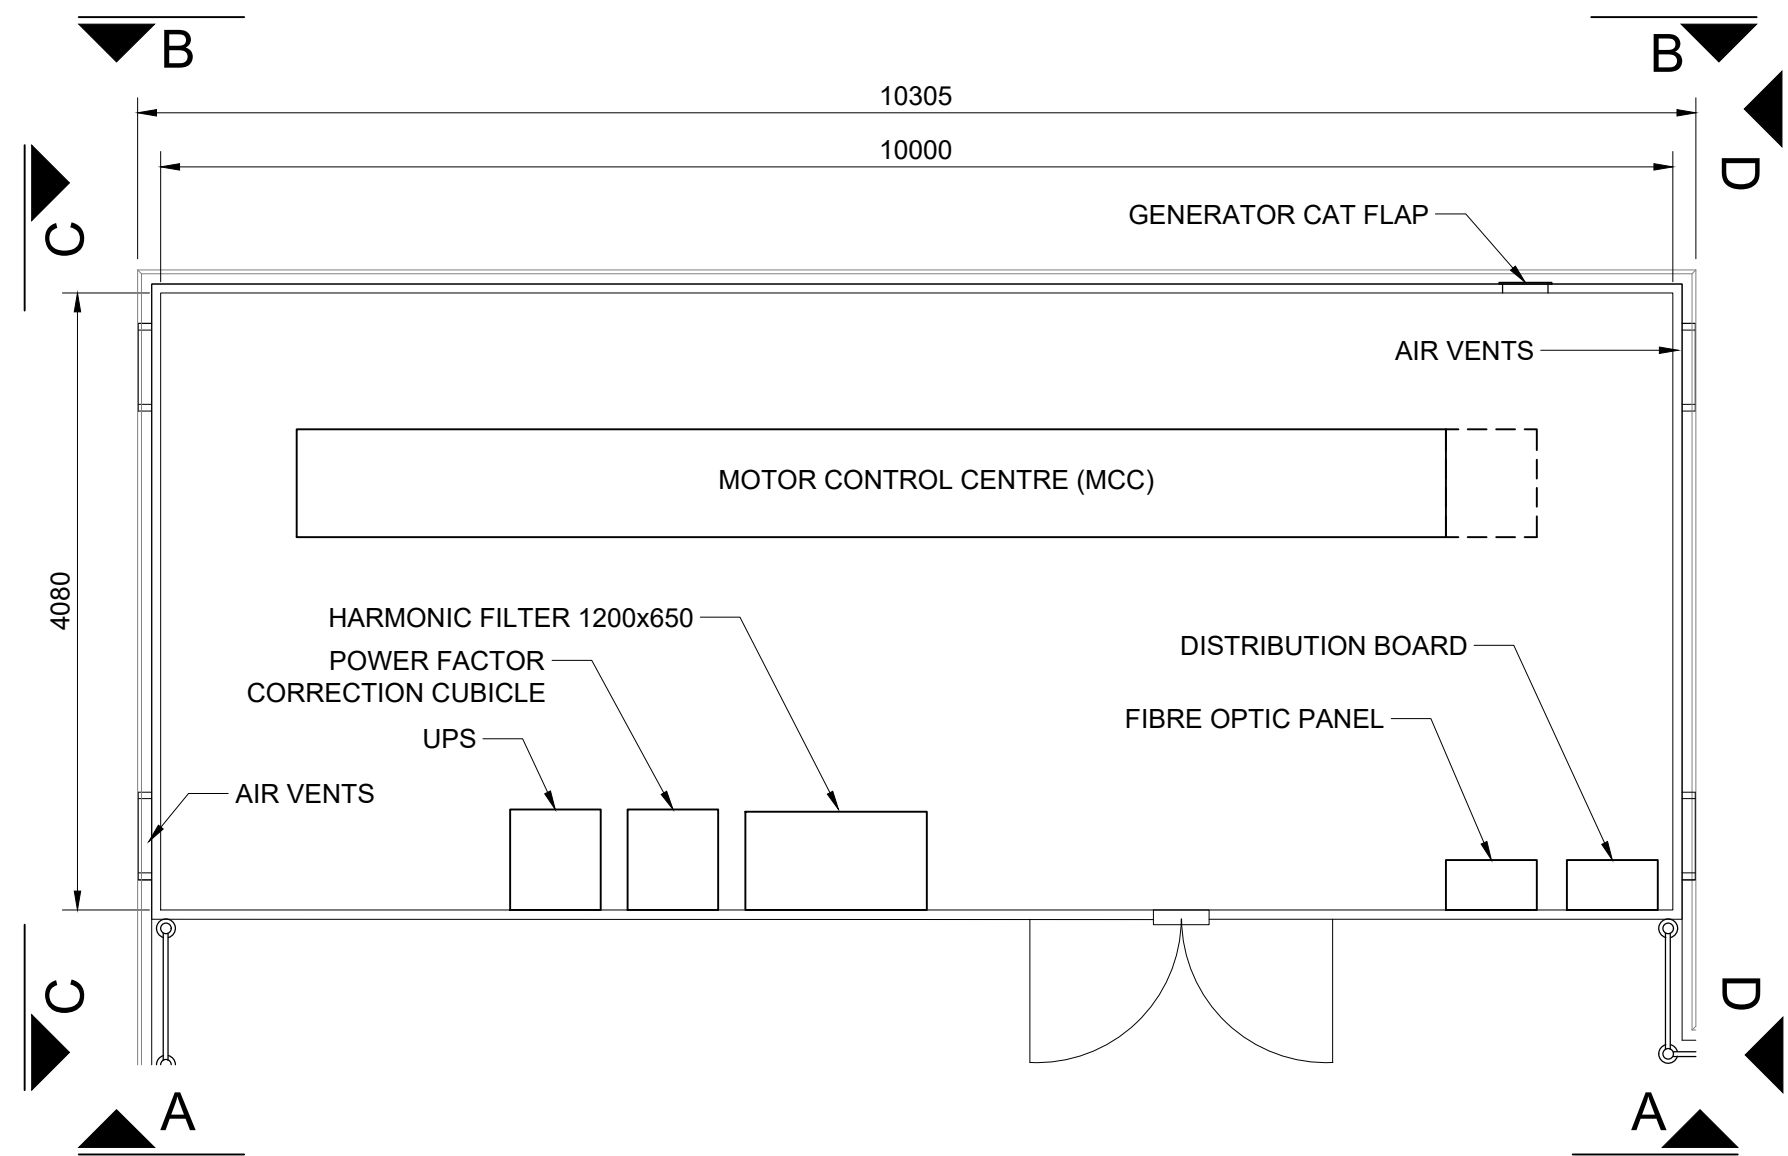


ELECTRICAL CONTROL BUILDING FLOOR PLAN

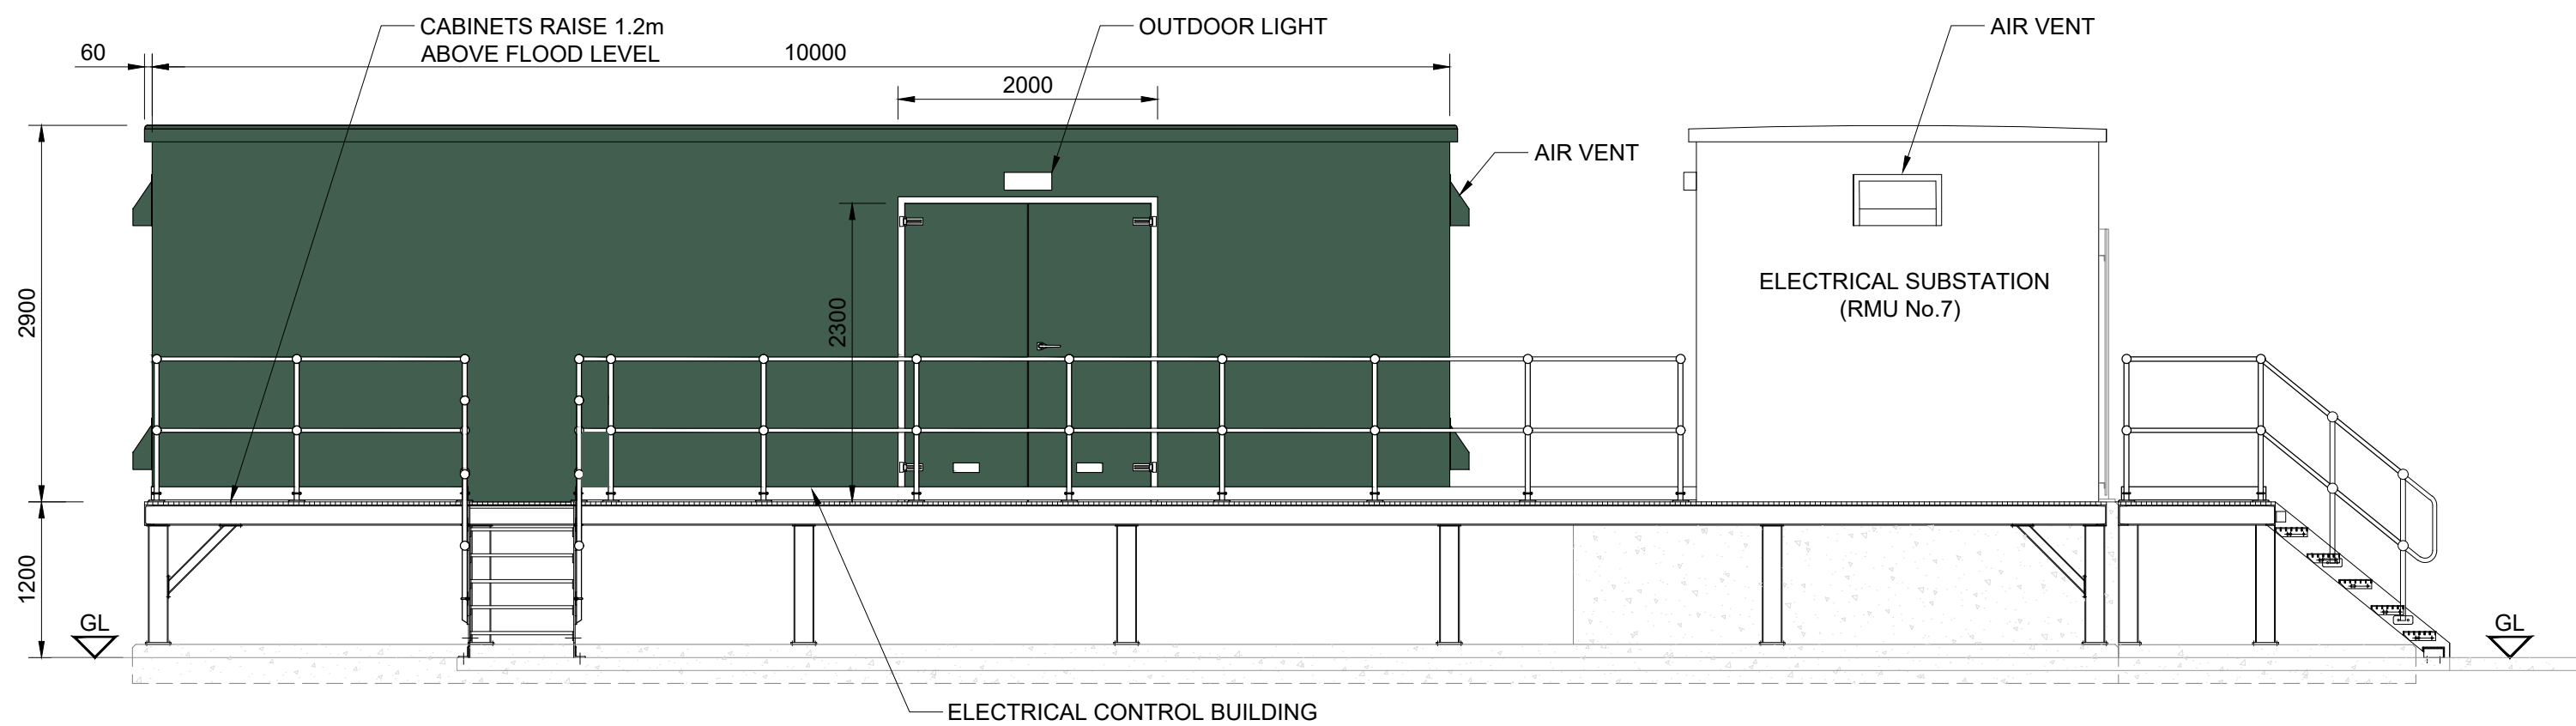


ELEVATION A - A

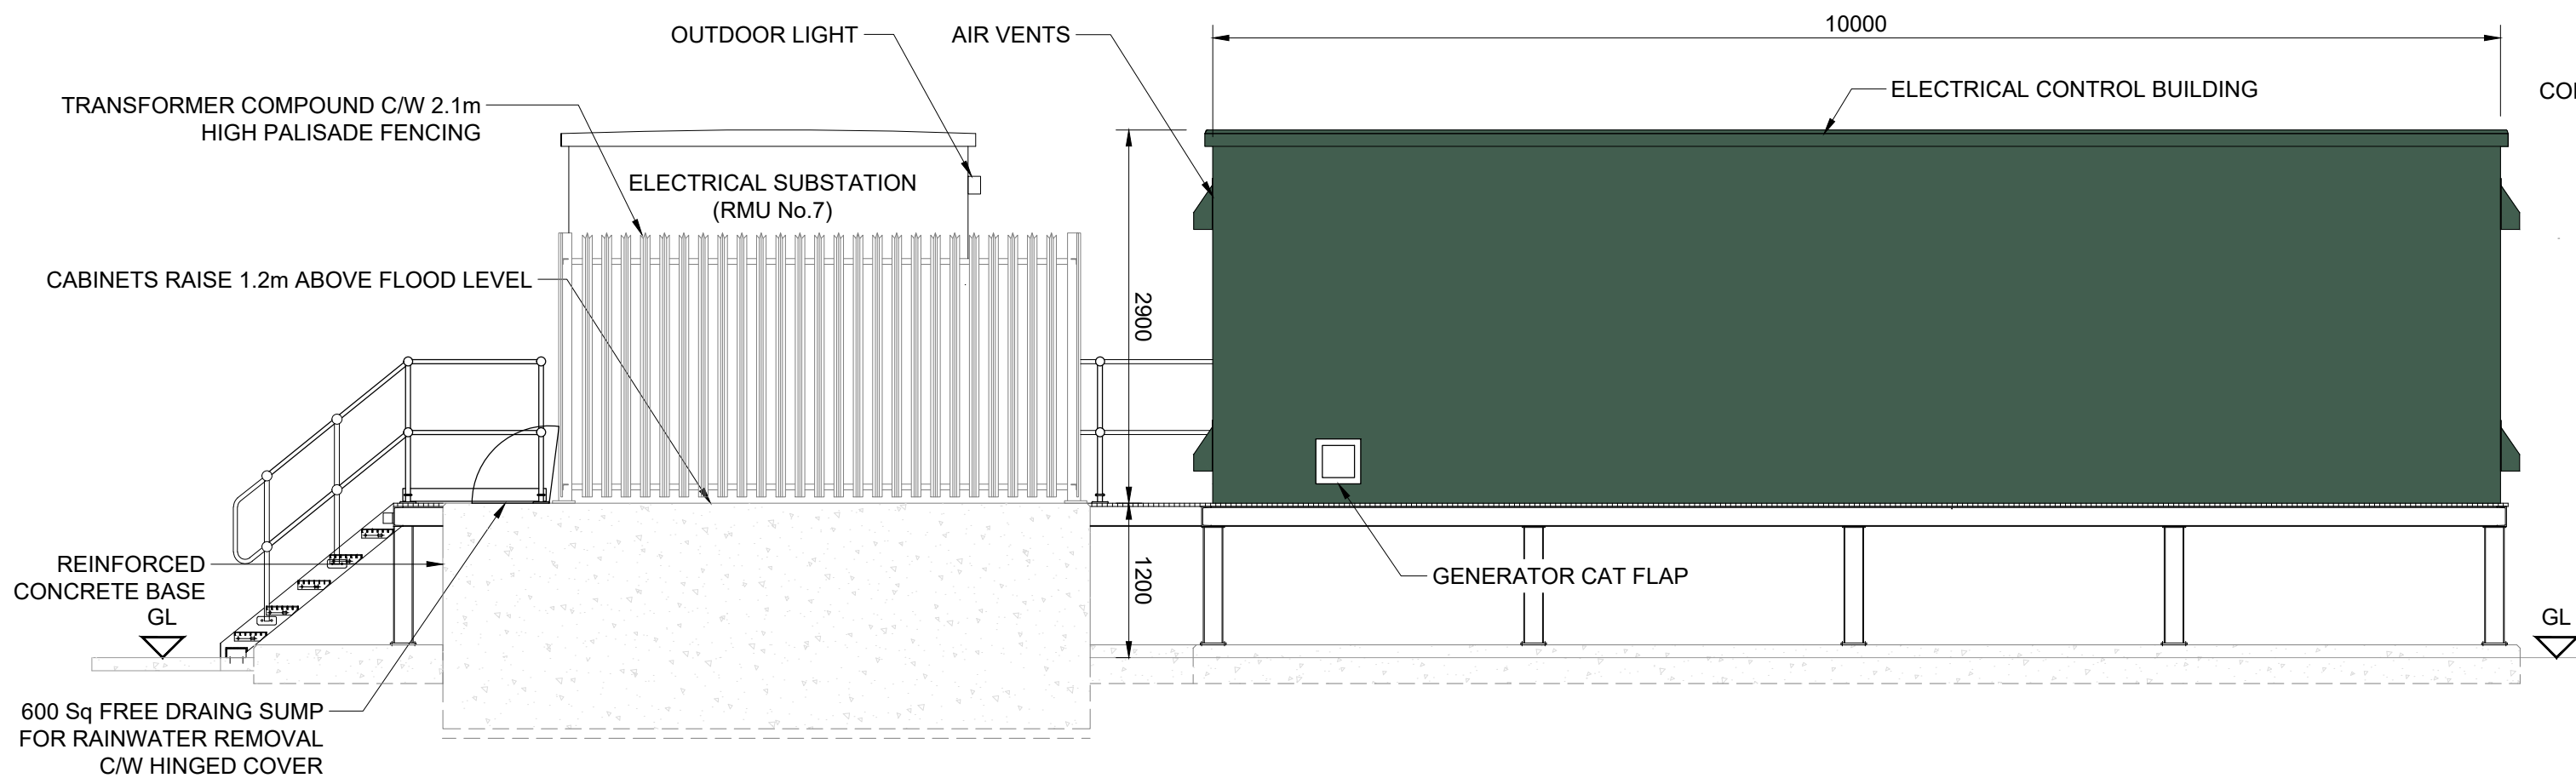

ELEVATION B - B

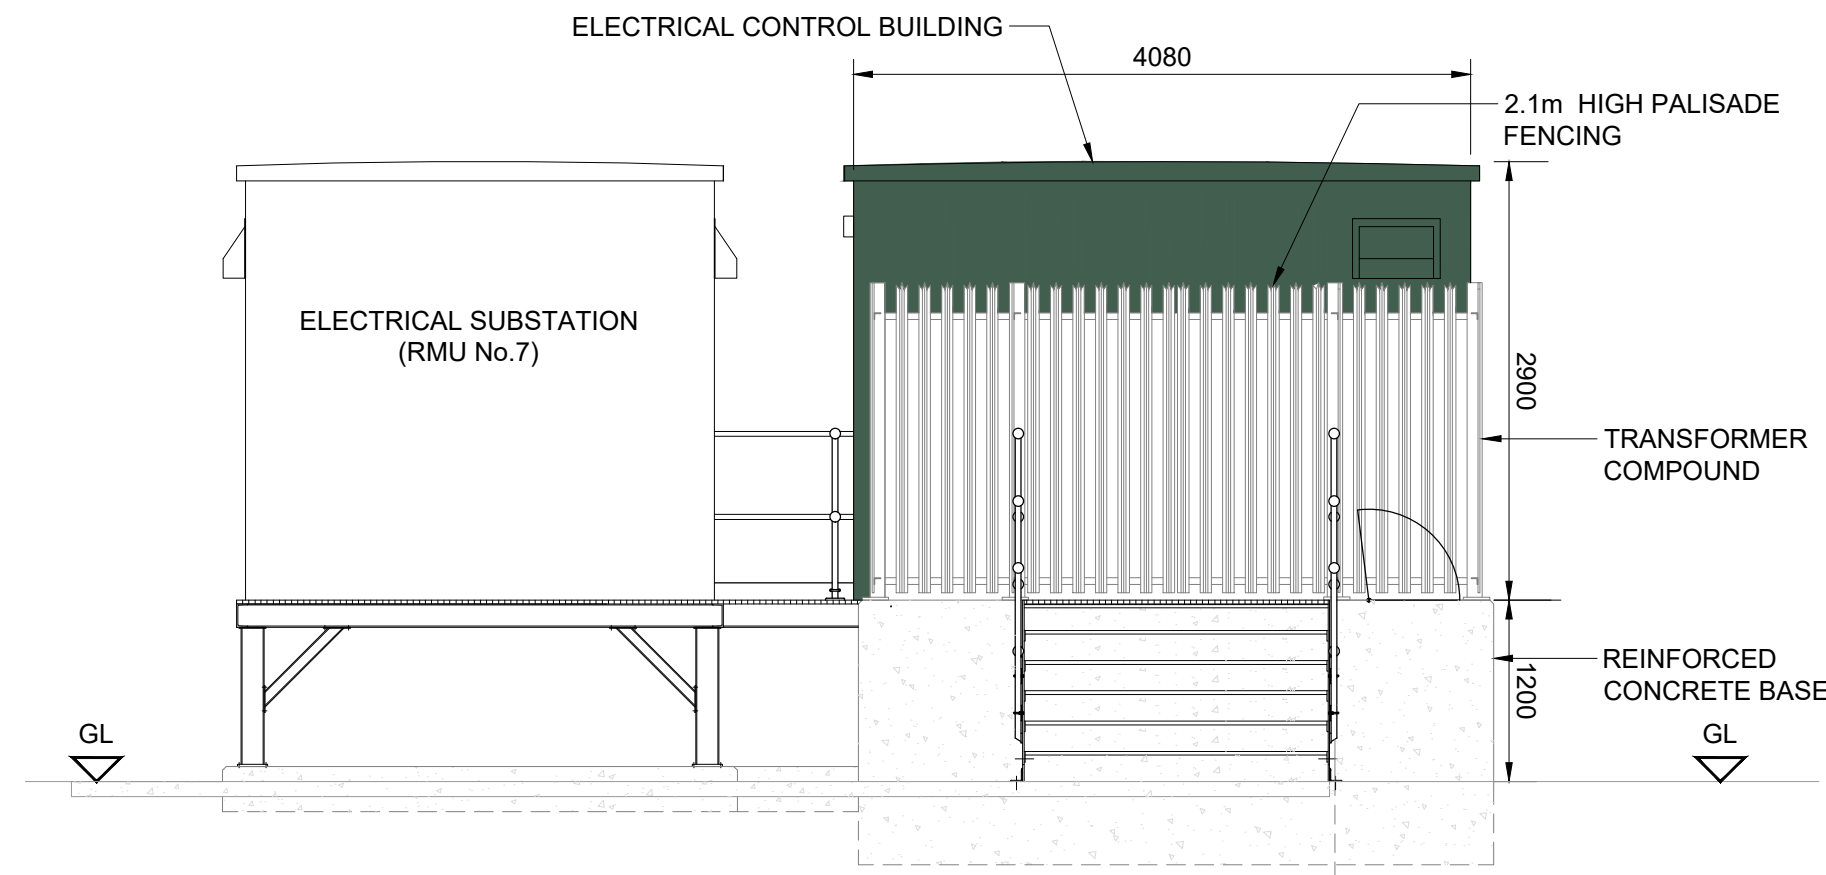

ELEVATION D - D

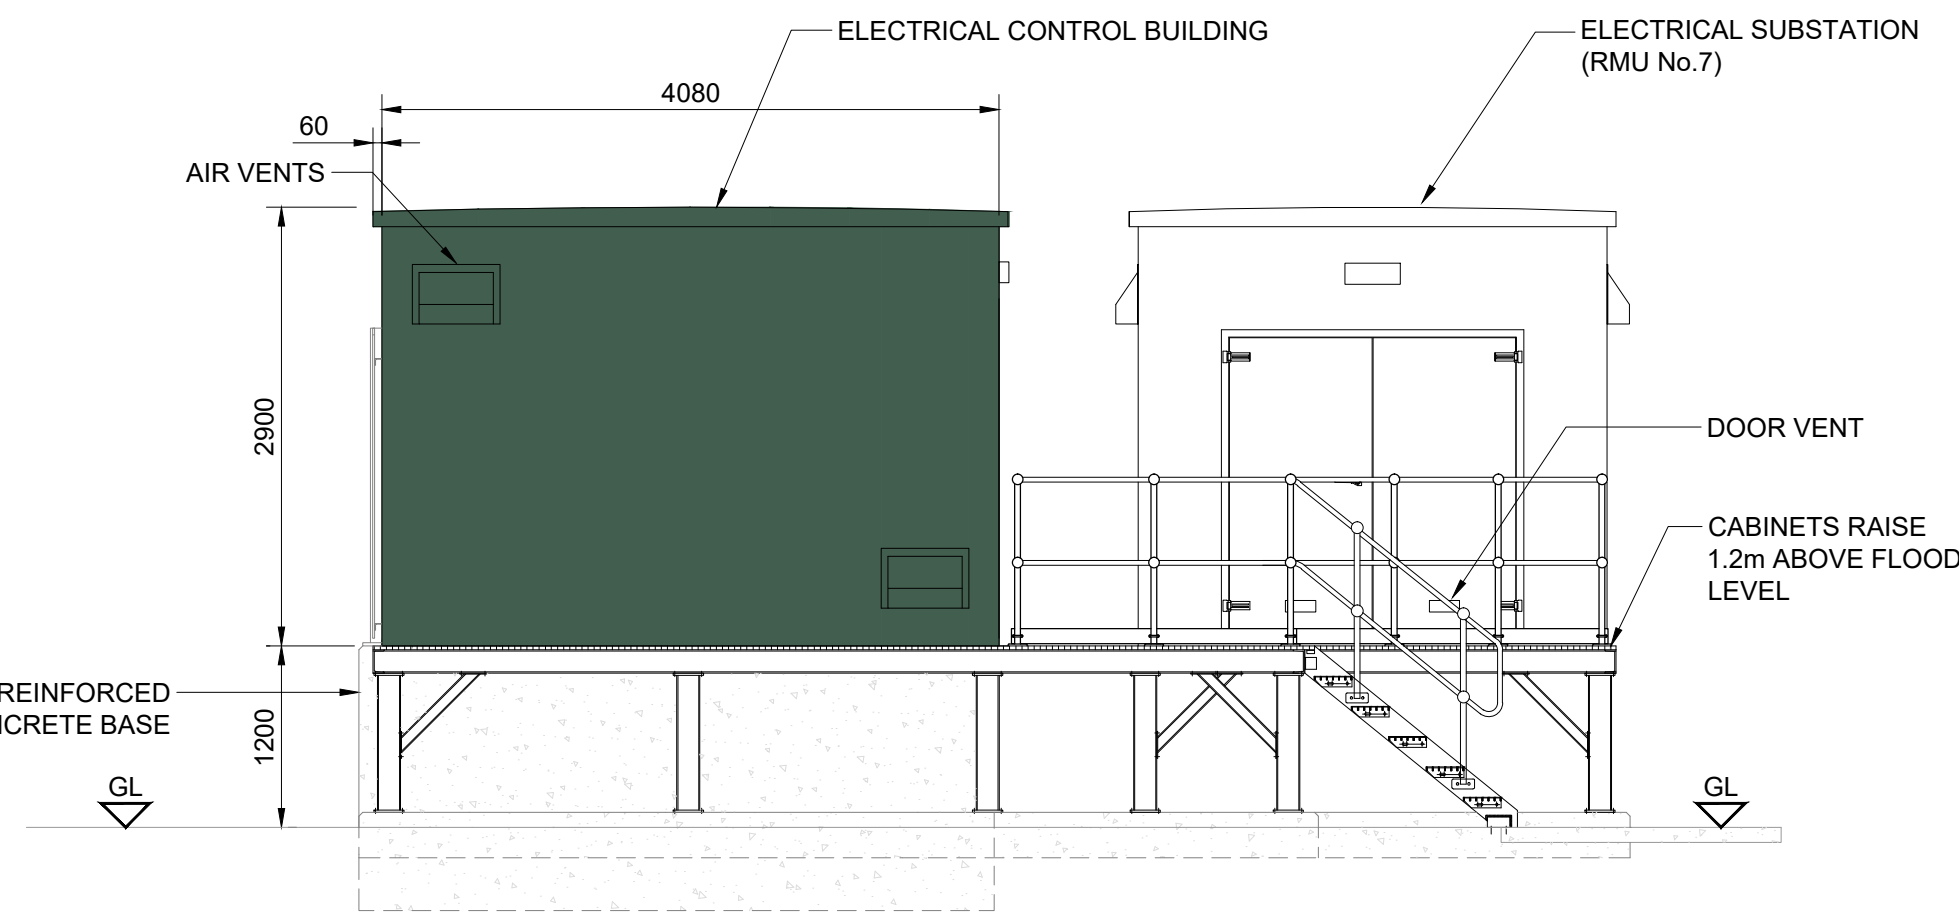

ELEVATION C - C

NOTES:

- ALL DIMENSIONS IN MILLIMETRES AND ALL LEVELS IN METRES AOD UNLESS NOTED OTHERWISE.
- REFER TO DRAWING No's:
80062960-02-UU-BURYZ-97-DR-C-00012 PROPOSED SITE LAYOUT PLAN.
80062960-02-UU-BURYZ-97-DR-C-00013 PROPOSED SITE ELEVATIONS SHEET 1 OF 2.
80062960-02-UU-BURYZ-97-DR-C-00014 PROPOSED SITE ELEVATIONS SHEET 2 OF 2.
- BUILDINGS TO BE PROVIDED WITH LIGHTING, POWER, FIRE AND INTRUDER SYSTEMS IN COMPLIANCE WITH UU ASSET STANDARDS.
- CONTROL BUILDING COLOUR TO BE GREEN (14 C 39).

LEGEND:



CURRENT ISSUE INFORMATION

P03	KA	NG	NG	For Information	08/06/23
VERSION	AUTH	CHKD	REVD	REASON FOR ISSUE	DATE
S2				Issued for Information	
SUITABILITY CODE	SUITABILITY DESCRIPTION				



GREEN RECOVERY BURY WwTW STORM TANKS
BURY WwTW SCHEME
PLANNING APPLICATION
PROPOSED ELECTRICAL CONTROL BUILDING
ELEVATIONS AND FLOOR LAYOUT

SCALE 1:50	SHEET SIZE A1
DRAWING NUMBER 80062960-02-UU-BURYZ-97-DR-C-00015	REVISION P03

