



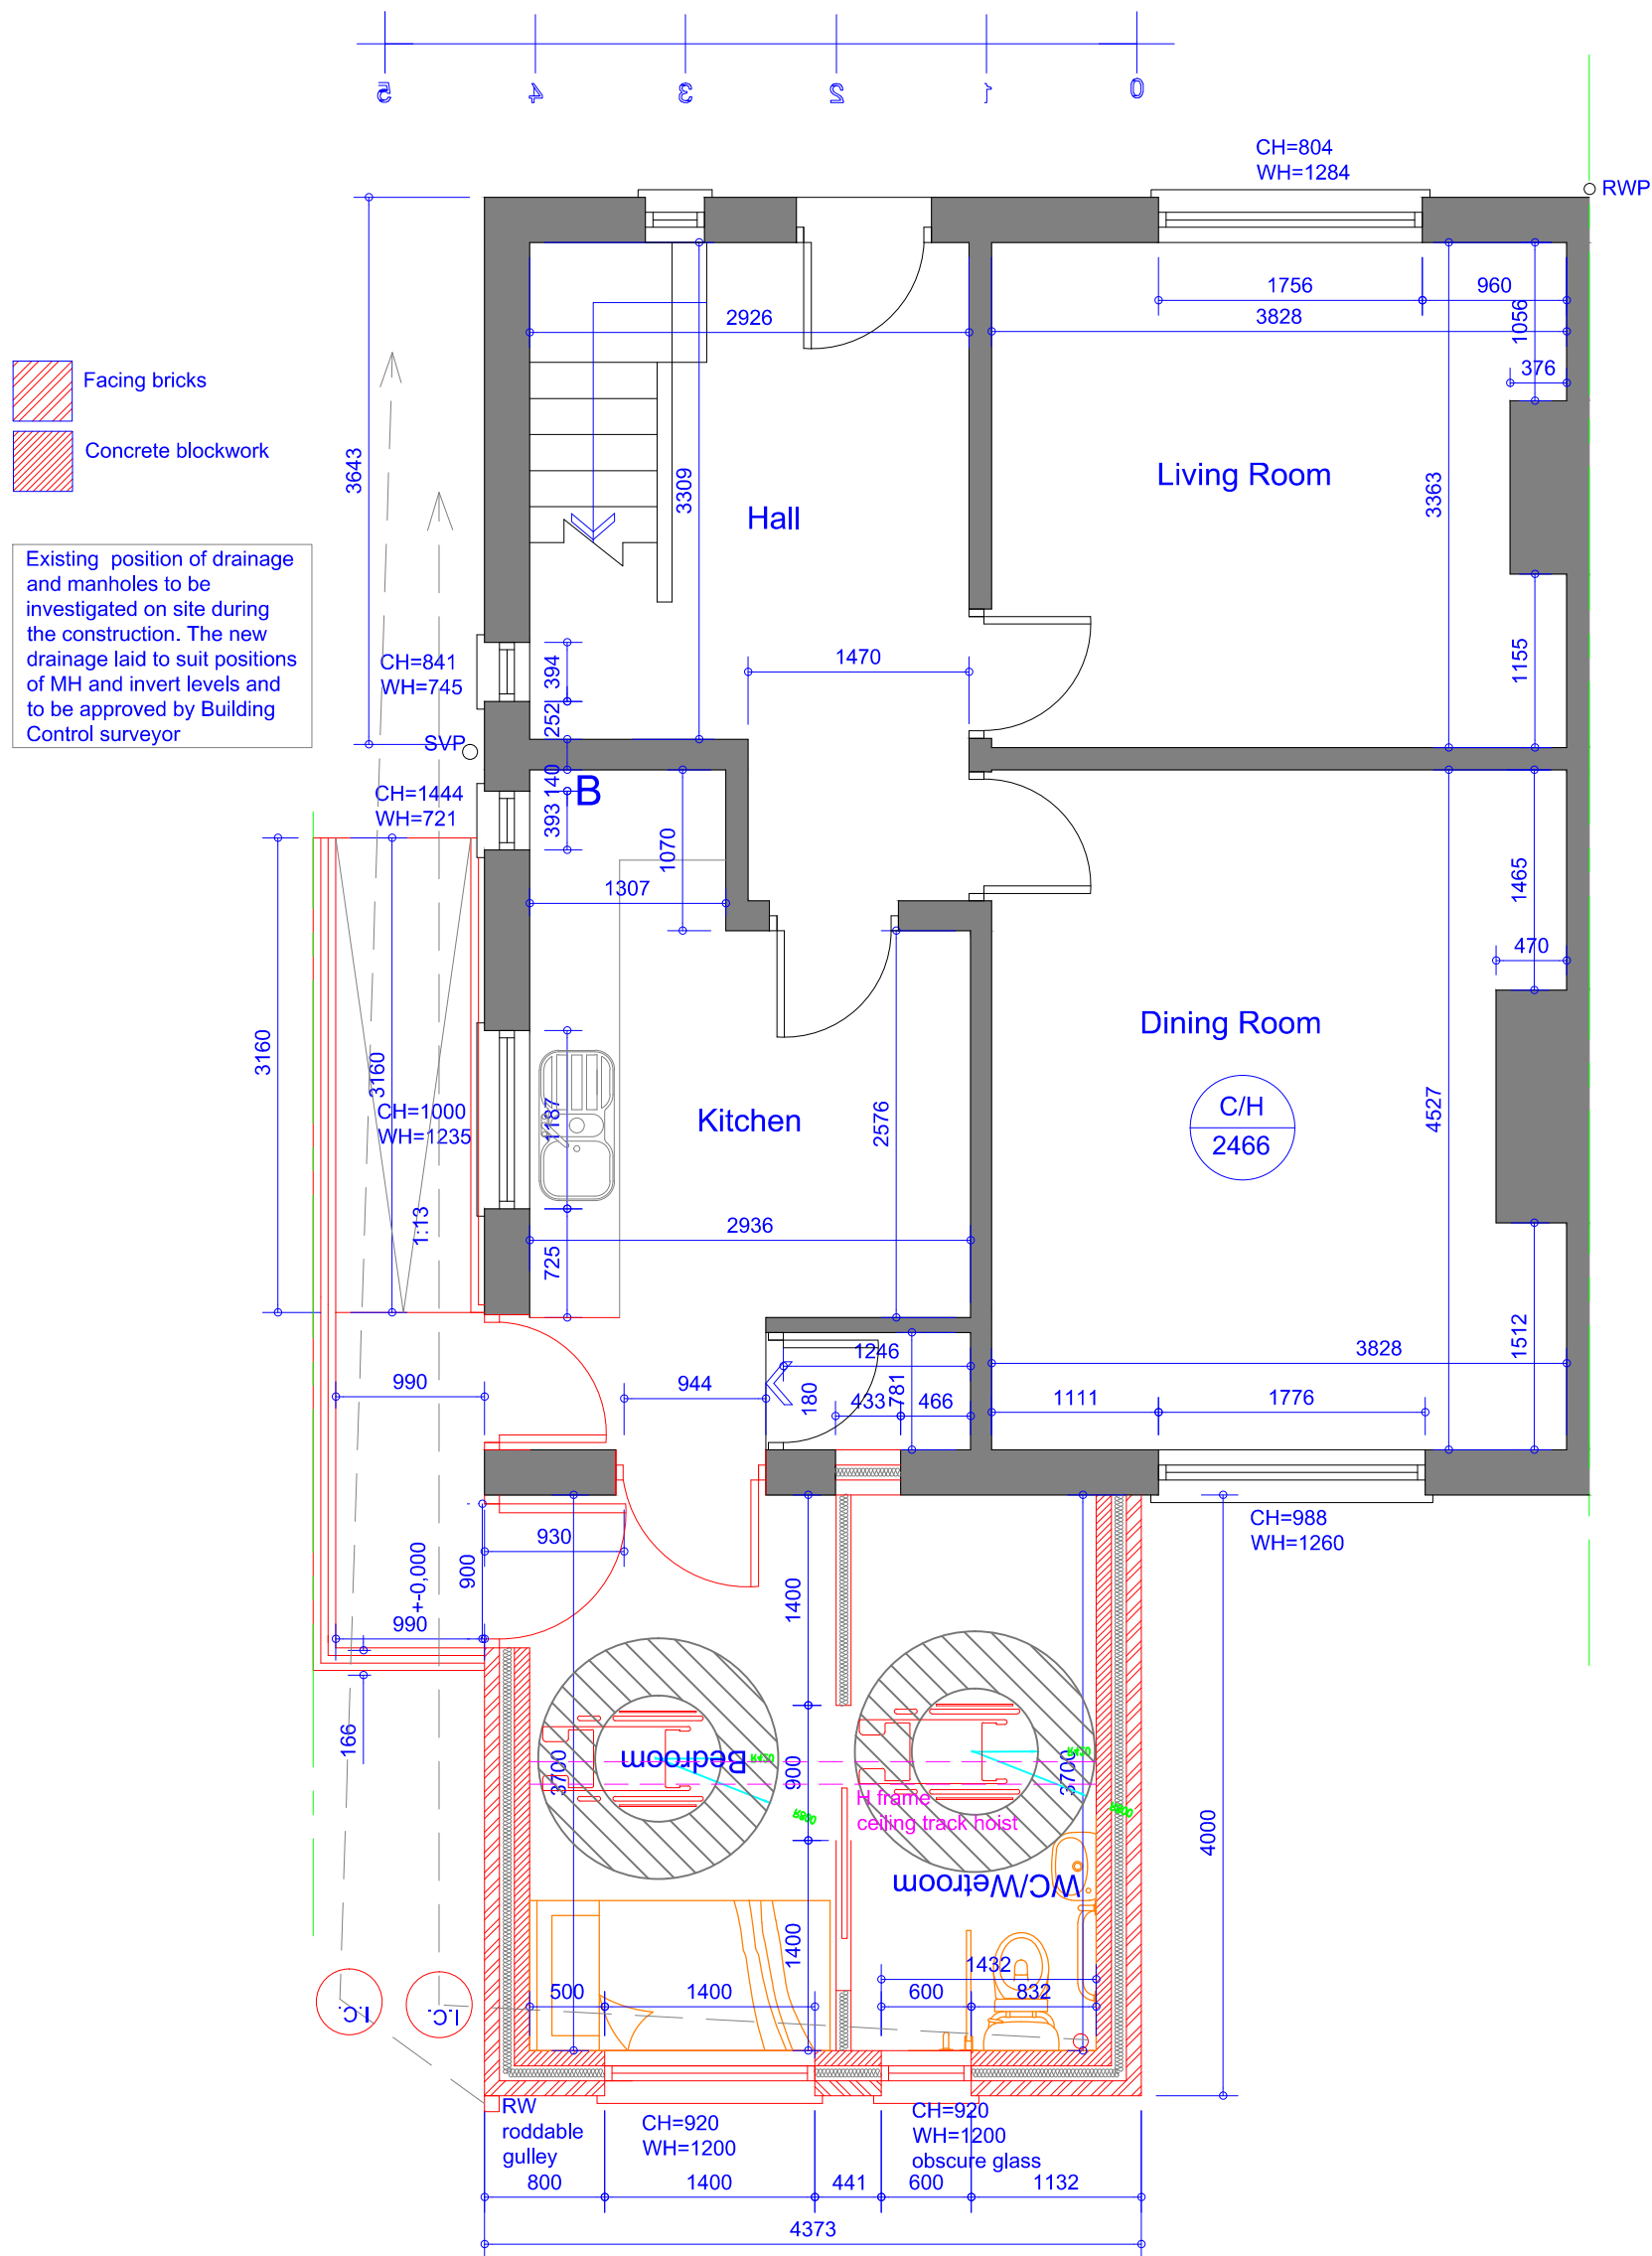

Proposed Ground Floor Plan
Scale 1:50

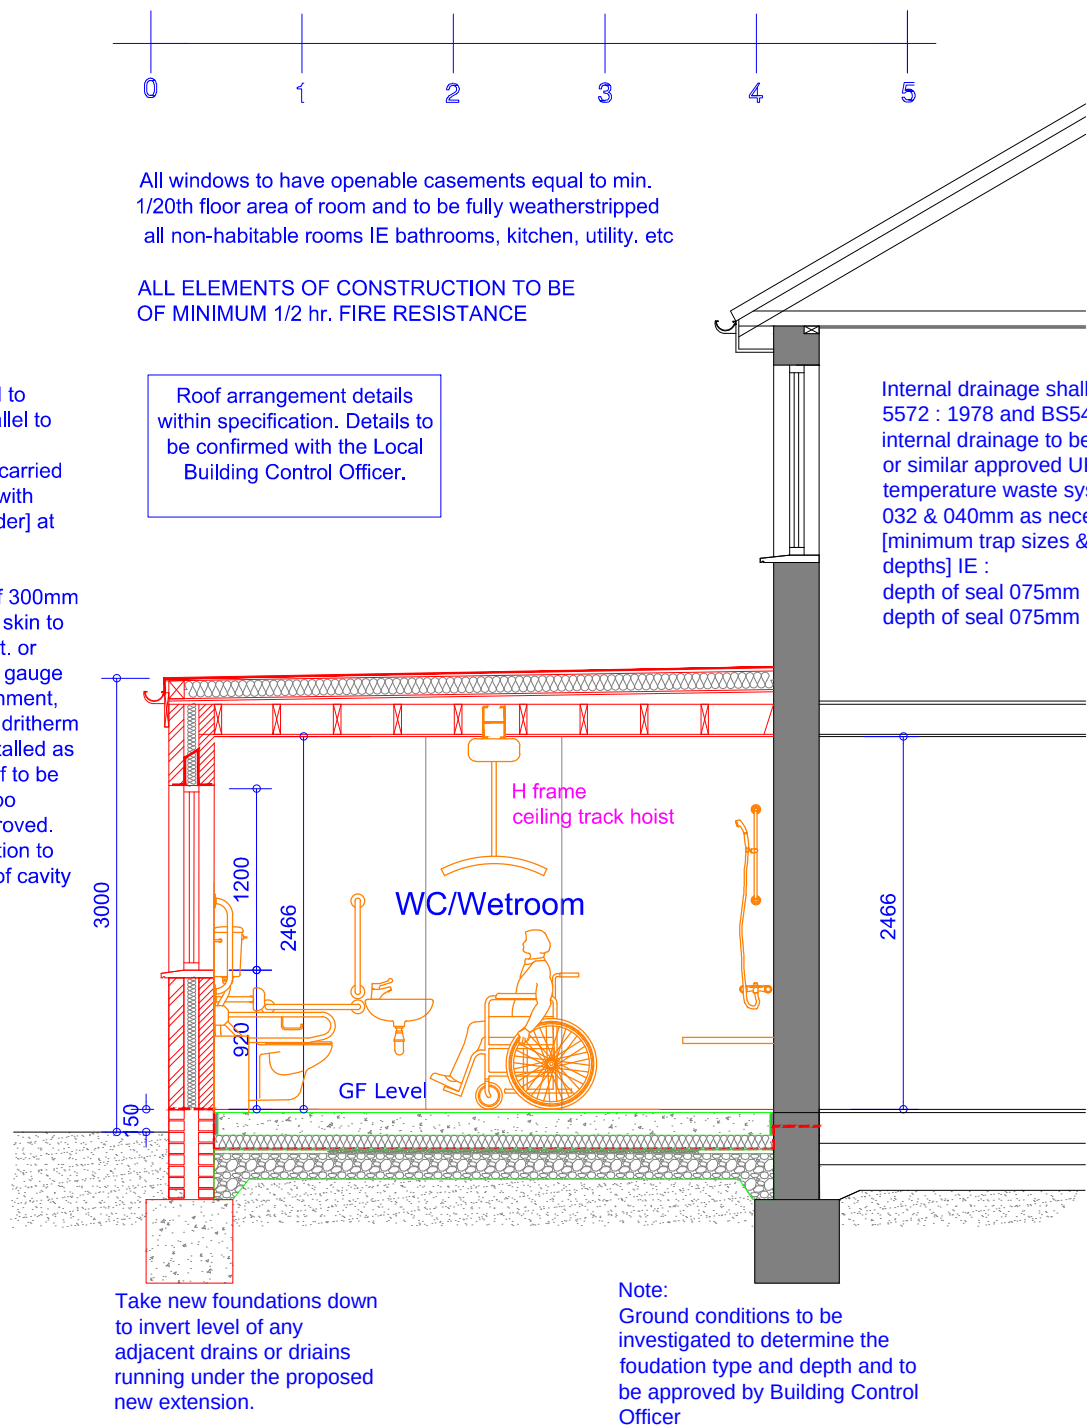

Proposed Section
Scale 1:50

ELECTRICITY service into existing buildings,, care must be taken when any excavation is taking place near these positions. Confirm position of electricity cables with Scottish Power [0151] 609 2394, before commencing on site, position of service cable to be marked on site, and also on copy of plans, once position of cable has

NOTE, Positions of proposed drainage runs and types of drainage indicated on drawings are provisional only, and may be altered to suit site conditions. Contractor to check invert & position of existing drainage systems to ensure adequate fall & to ensure BCO is satisfied with proposed drainage layout, fall and site inverts before excavation of drainage runs

WATER supply to be located & isolated prior to removal of any pipework, water supply pipe to be adequately protected from accidental / wilful damage at all times, contact United Utilities 0845 746 2200 GAS service into existing buildings,, care must be taken when any excavation is taking place near these positions. Confirm position of gas supply pipe with Transco 01204 - 546900, before commencing on site, position of service pipe to be marked on site, and also on copy of plans, once position of pipe has been established, IN AN EMERGENCY CALL 0800 111999 IMMEDIATELY

Maintain any existing floor ventilation from the existing dwelling with 100mm dia PVC duct over / under new floor and extending telescopic air vents and air bricks with cavity trays over at maximum 1500mm centres. all vegetable strip to be removed from site of slab & ground to be treated were necessary with proprietary weedkiller

Rev	Date	Description
Issued For : INFORMATION PURPOSES ONLY		
Client		
Mr. Richard Bawden		
Project		
55 Arley Avenue, Bury. BL9 5HD Proposed single storey rear extension and access ramp.		
Scheme - Drawing Title		
Proposed Ground Floor and Section.		
02		
Drawing No.	Revision	Date 28.10.21 Scale 1:50 @A2
		
JK Technical Services (NW) Ltd Tel: 0161 728 5730 Mob: 07741175755 www.jktechservs.co.uk		