



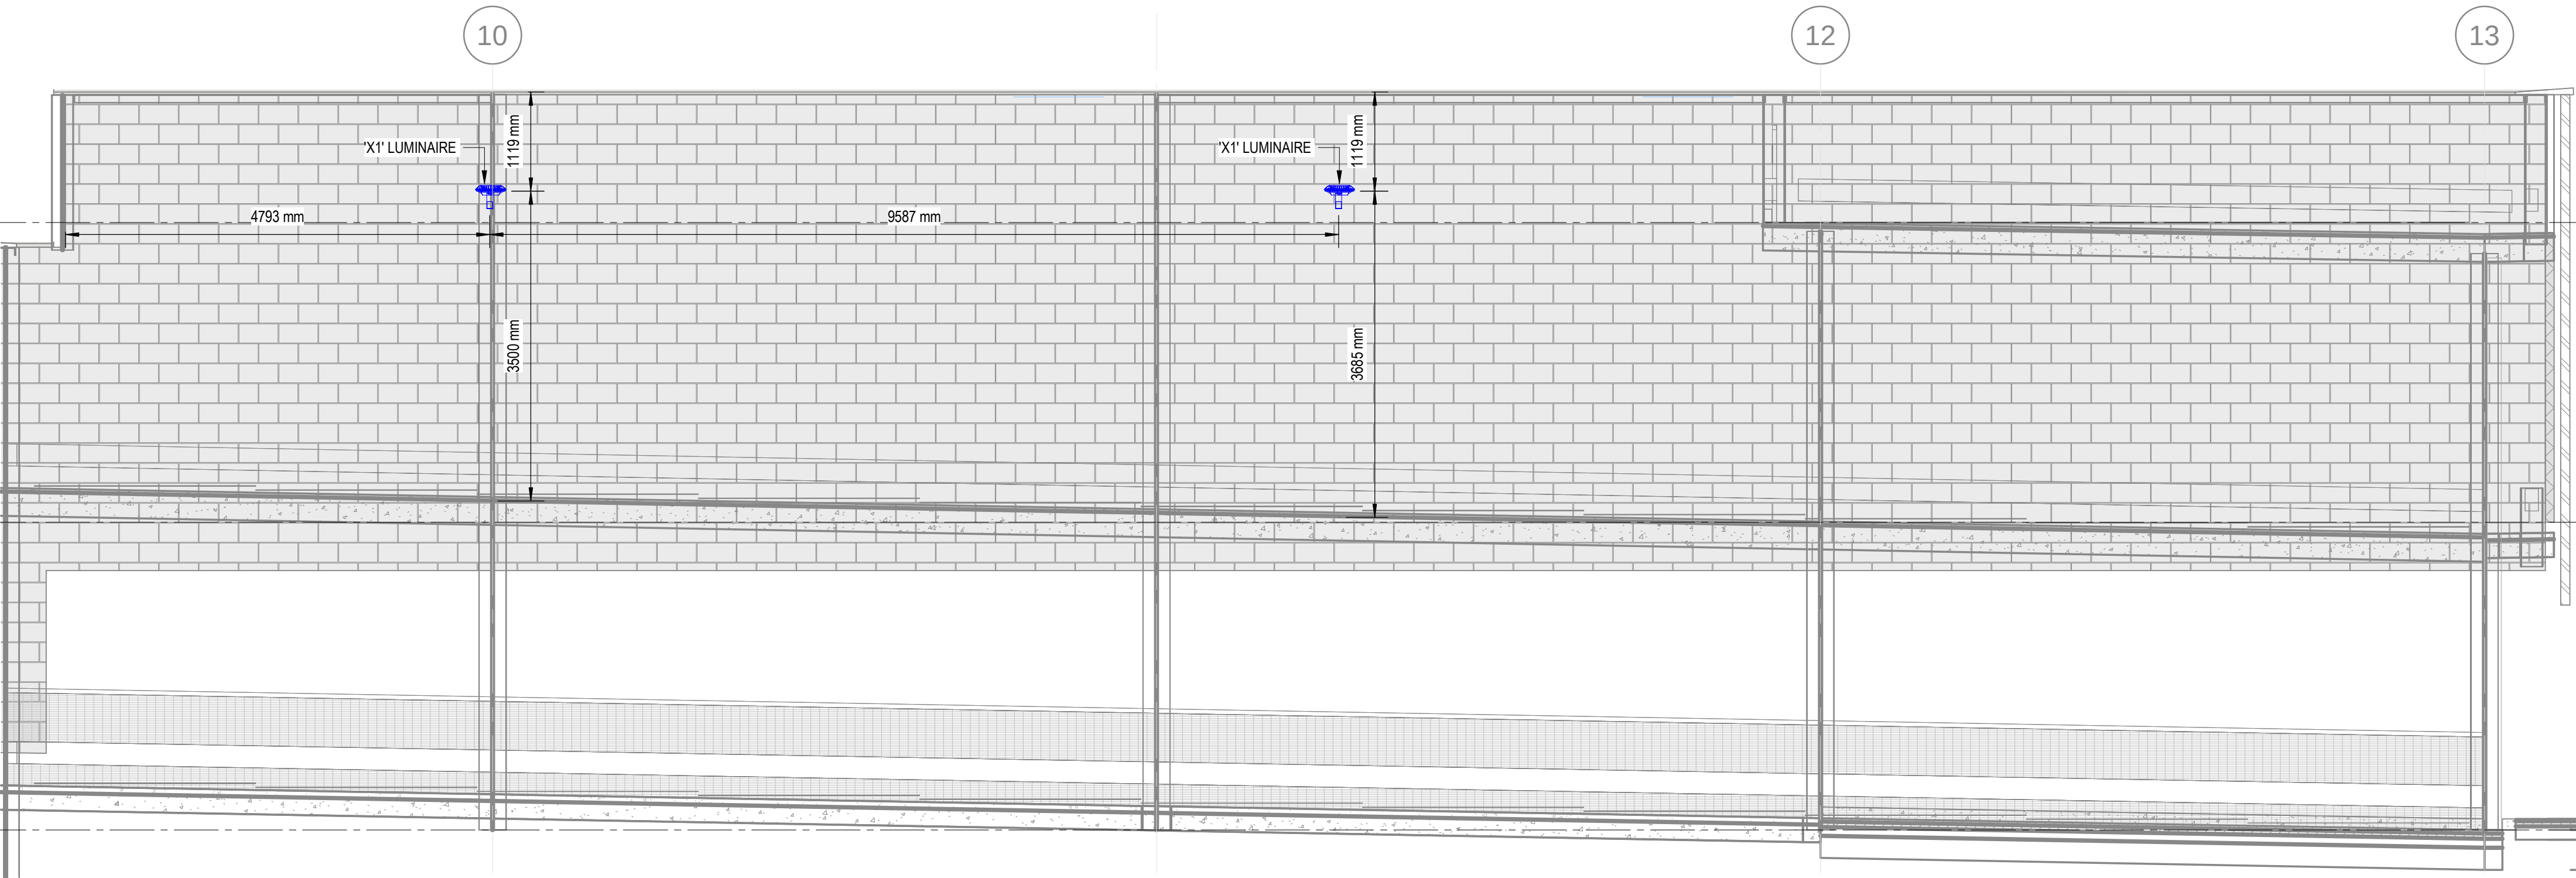

SECTION A - A EXTERNAL CAR PARK
REFER TO DRAWING REF
17300-247-P1-01-D-E-630002
FOR LIGHTING LAYOUT

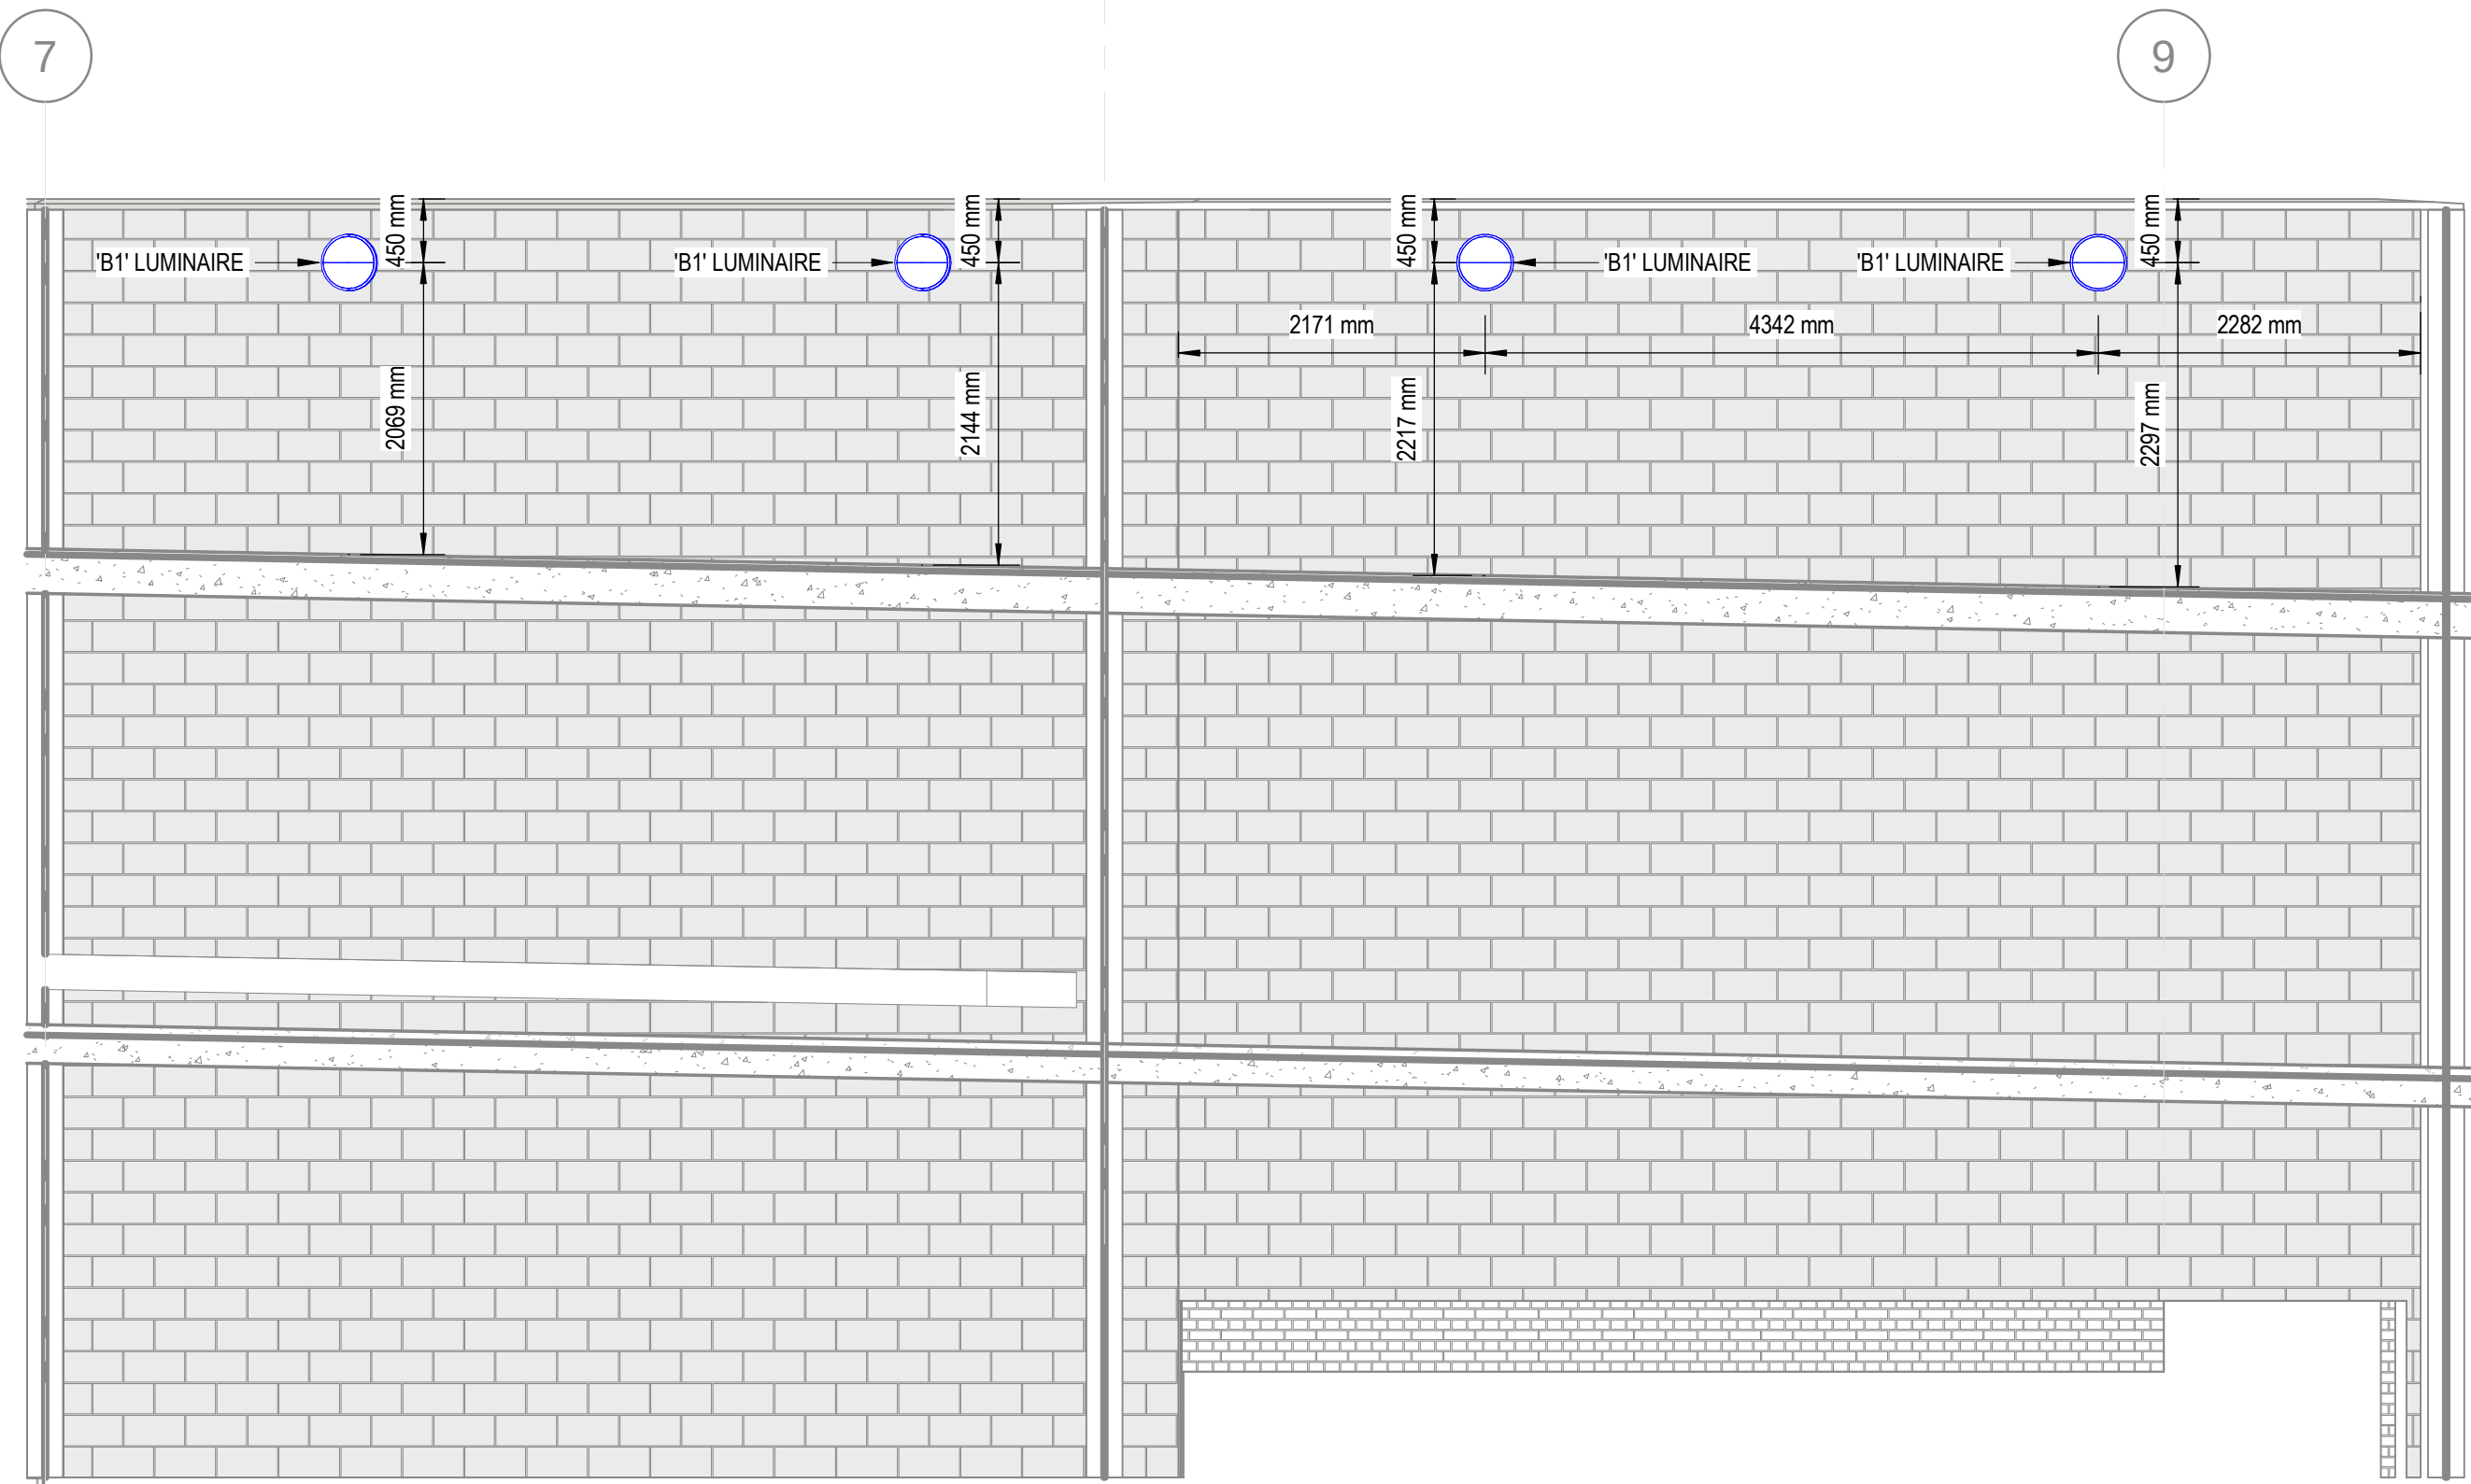

SECTION B - B EXTERNAL CAR PARK
REFER TO DRAWING REF
17300-247-P1-01-D-E-630002
FOR LIGHTING LAYOUT

NOTES

- NOTES
- THIS DRAWING SHALL BE READ IN CONJUNCTION WITH ALL OTHER 24-7 GROUP DRAWINGS AND DOCUMENTATION.
 - THE ELECTRICAL INSTALLATION SHALL BE IN ACCORDANCE WITH THE LATEST EDITION OF THE IET WIRING REGULATIONS BS7671, INCLUDING ANY AMENDMENTS.
 - ALL EQUIPMENT TO BE INSTALLED IN ACCORDANCE WITH THE MANUFACTURER'S RECOMMENDATIONS.
 - REFER TO LIGHTING CONTROL PHILOSOPHY DRAWINGS (REF: 17300-247-P1-00-D-E-630500, 17300-247-P1-01-D-E-630501 & 17300-247-P1-02-D-E-630502) FOR LIGHTING CONTROL METHODS.
 - EMERGENCY TEST KEY SWITCHES FOR TESTING OF EMERGENCY LIGHTING LUMINAIRE ARE LOCATED ADJACENT TO EACH RELEVANT DISTRIBUTION BOARD. EACH EMERGENCY LUMINAIRE CONTAINS AN INTEGRAL 3-HOUR BATTERY PACK.
 - ALL GENERAL FINAL CIRCUITS ARE PROVIDED WITH EITHER MCB OR RCBO PROTECTION, AS STATED ON THE DISTRIBUTION BOARD SCHEDULES.

C01	CONSTRUCTION ISSUE	JA	JM	24/12/2025
P01	PRELIMINARY ISSUE	JD	JM	14/10/2025
rev	description	dwn	chkd	date

Status
CONSTRUCTION

Client


Architect/Proj
Jon Matthews Architects


Craven House - Britannia Road - Sale - Manchester - M33 2AA
☎ 0161 6202047 ✉ mail@24-7group.co.uk 🌐 www.24-7group.co.uk

project
PRESTWICH TRAVEL HUB

title
FIRST FLOOR
EXTERNAL ELEVATIONS

project no.	drawn by	date	checked	scale
PN01735	JD	SEPT 2025	JM	1 : 50 @ A1
drawing no.				revision
17300-247-P1-01-D-E-630009				C01