

The Firepit Bury



Plan Produced for: The Firepit Bury
Date Produced: 13 Oct 2024
Plan Reference Number: TQRQM24287191836975
Scale: 1:1250 @ A4
© Crown copyright and database rights 2023 OS 100042766



THE FIREPIT
BURY

Signage Drawings


Scale 1:1250

Date	13/10/24
Drawing Type	Proposal
Drawn by	KL
Revision	-





ELEVATION B

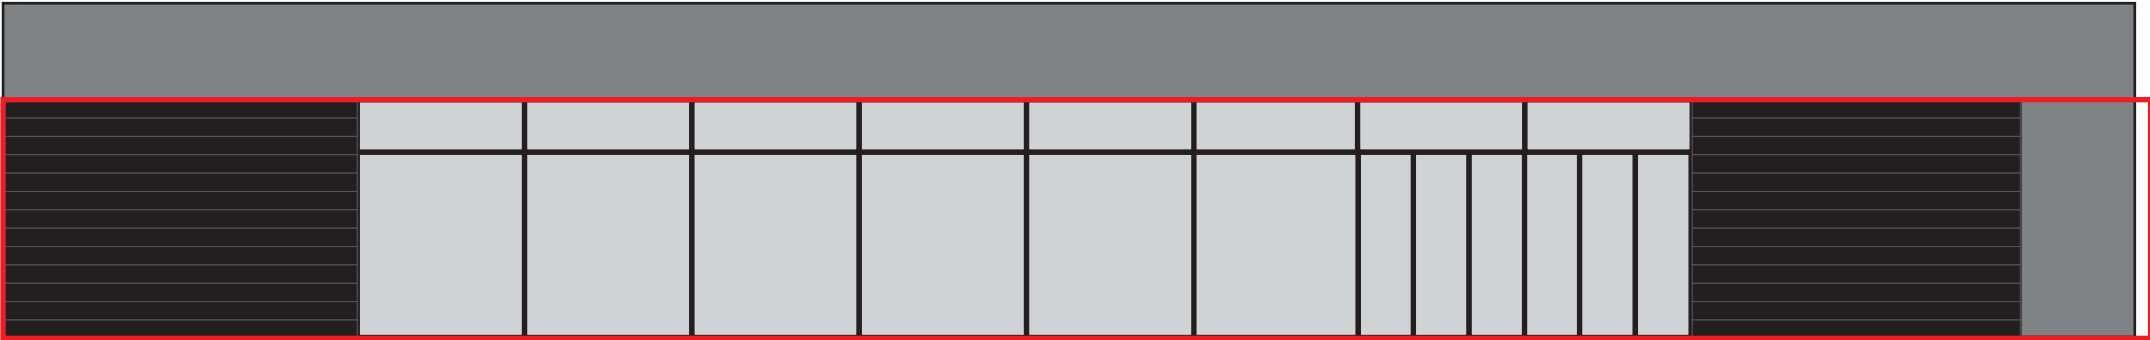

ELEVATION A



EXISTING	
THE FIREPIT	
BURY	
Signage Drawings	
Scale 1:100	
Date	13/08/24
Drawing Type	Proposal
Drawn by	KL
Revision	-



A. MENU CASE

A1 poster frame
illuminated 1w 122 lumens 6500k
fixed directly to brickwork

B. ILLUMINTATED LOGO

80 mm deep face illuminated
opal acrylic lettering
with cut white vinyl charcoal detail
110lumens 6500k
fixed directly to brickwork

C. ILLUMINTATED LOGO

80 mm deep face illuminated
opal acrylic lettering
with cut white vinyl charcoal detail
110lumens 6500k
fixed directly to timber wall cladding

D. PROJECTING SIGN

Translucent acrylic red box
with LED neon rope inside
and cut white vinyl logo to
front and back


ELEVATION B



D. PROJECTING SIGN

C. ILLUMINTATED LOGO

ELEVATION A

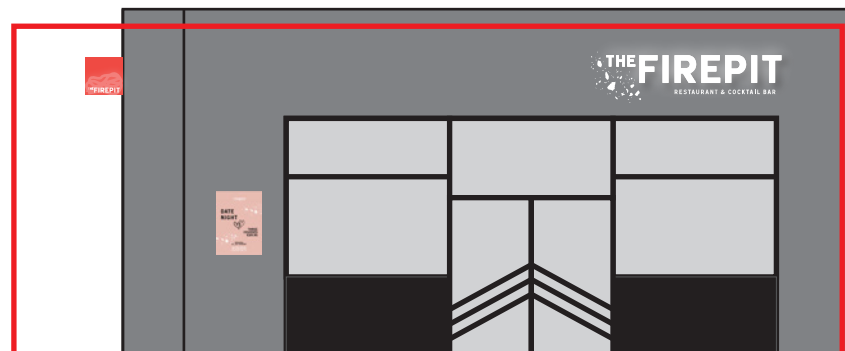

A. MENU CASE

B. MENU CASE

PROPOSED

THE FIREPIT
BURY

Signage Drawings

Scale 1:100


Date	13/08/24
Drawing Type	Proposal
Drawn by	KL
Revision	-

FRIDAY&

A1 poster frame
illuminated 1w 122 lumens 6500k
fixed directly to brickwork

A diagram of a rectangular frame. The top horizontal edge is labeled "634mm" with a double-headed arrow above it. The right vertical edge is labeled "880mm" with a double-headed arrow to its right. The left vertical edge is labeled "20mm deep" with a line pointing to it from the left. The frame is represented by a thick black border.

Fitted 1400mm from FFL to underside. Any wires to be fed through the reverse into unit.

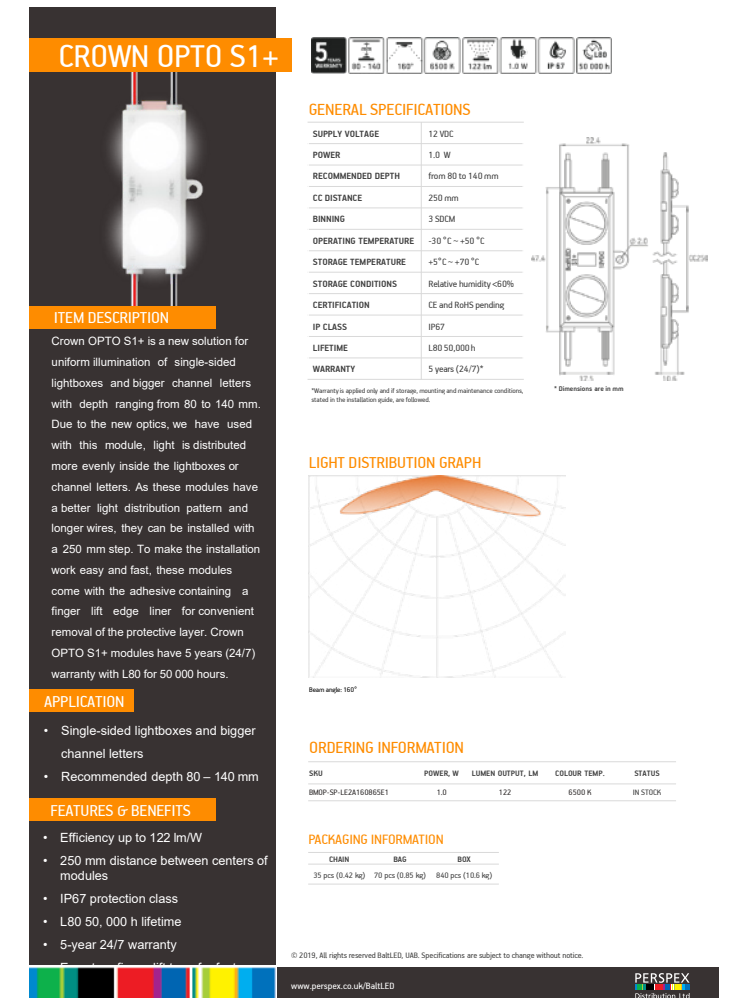

THE FIREPIT BURY

Scale 1:10

Date	13/08/24
Drawing Type	Proposal
Drawn by	KL
Revision	-

FRIDAY&

B+C. ILLUMINTATED LOGO
80 mm deep face illuminated
opal acrylic lettering
with cut white vinyl charcoal detail
fixed directly to brickwork



ELEVATION A



Fitted 3300mm from FFL to underside. Any wires to be fed through the reverse into unit.

ELEVATION B




Fitted 1400mm from FFL to underside. Any wires to be fed through the reverse into unit.

ILLUMINATED LOGO	
THE FIREPIT BURY	
Signage Drawings	
Scale 1:10	
Date	13/08/24
Drawing Type	Proposal
Drawn by	KL
Revision	-


D. PROJECTING SIGN

Translucent acrylic red box with LED neon rope inside and cut white vinyl logo to front and back

110lumens 6500k
static illumination

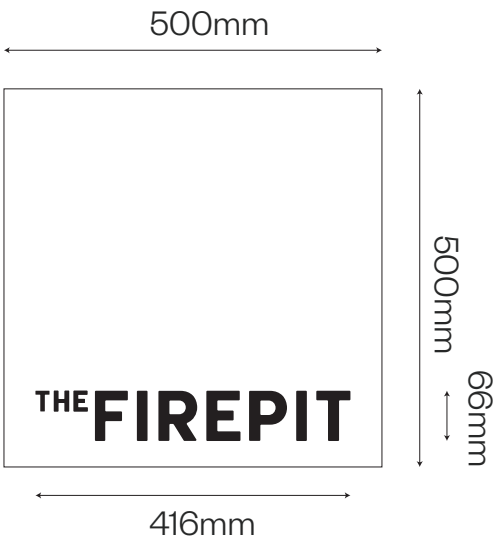

Fixing plate
fixed directly into
brick work

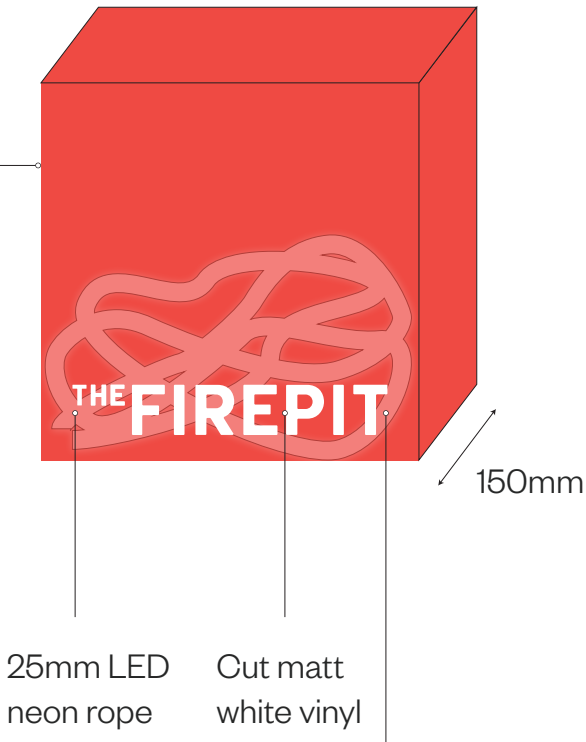

ELEVATION A

Fitted 3300mm from FFL
to underside. Any wires to be
fed through the reverse into
unit.



Ref



PROJECTING SIGN


THE FIREPIT
BURY

Signage Drawings

Scale 1:10

Date	13/08/24
Drawing Type	Proposal
Drawn by	KL
Revision	-

FRIDAY&

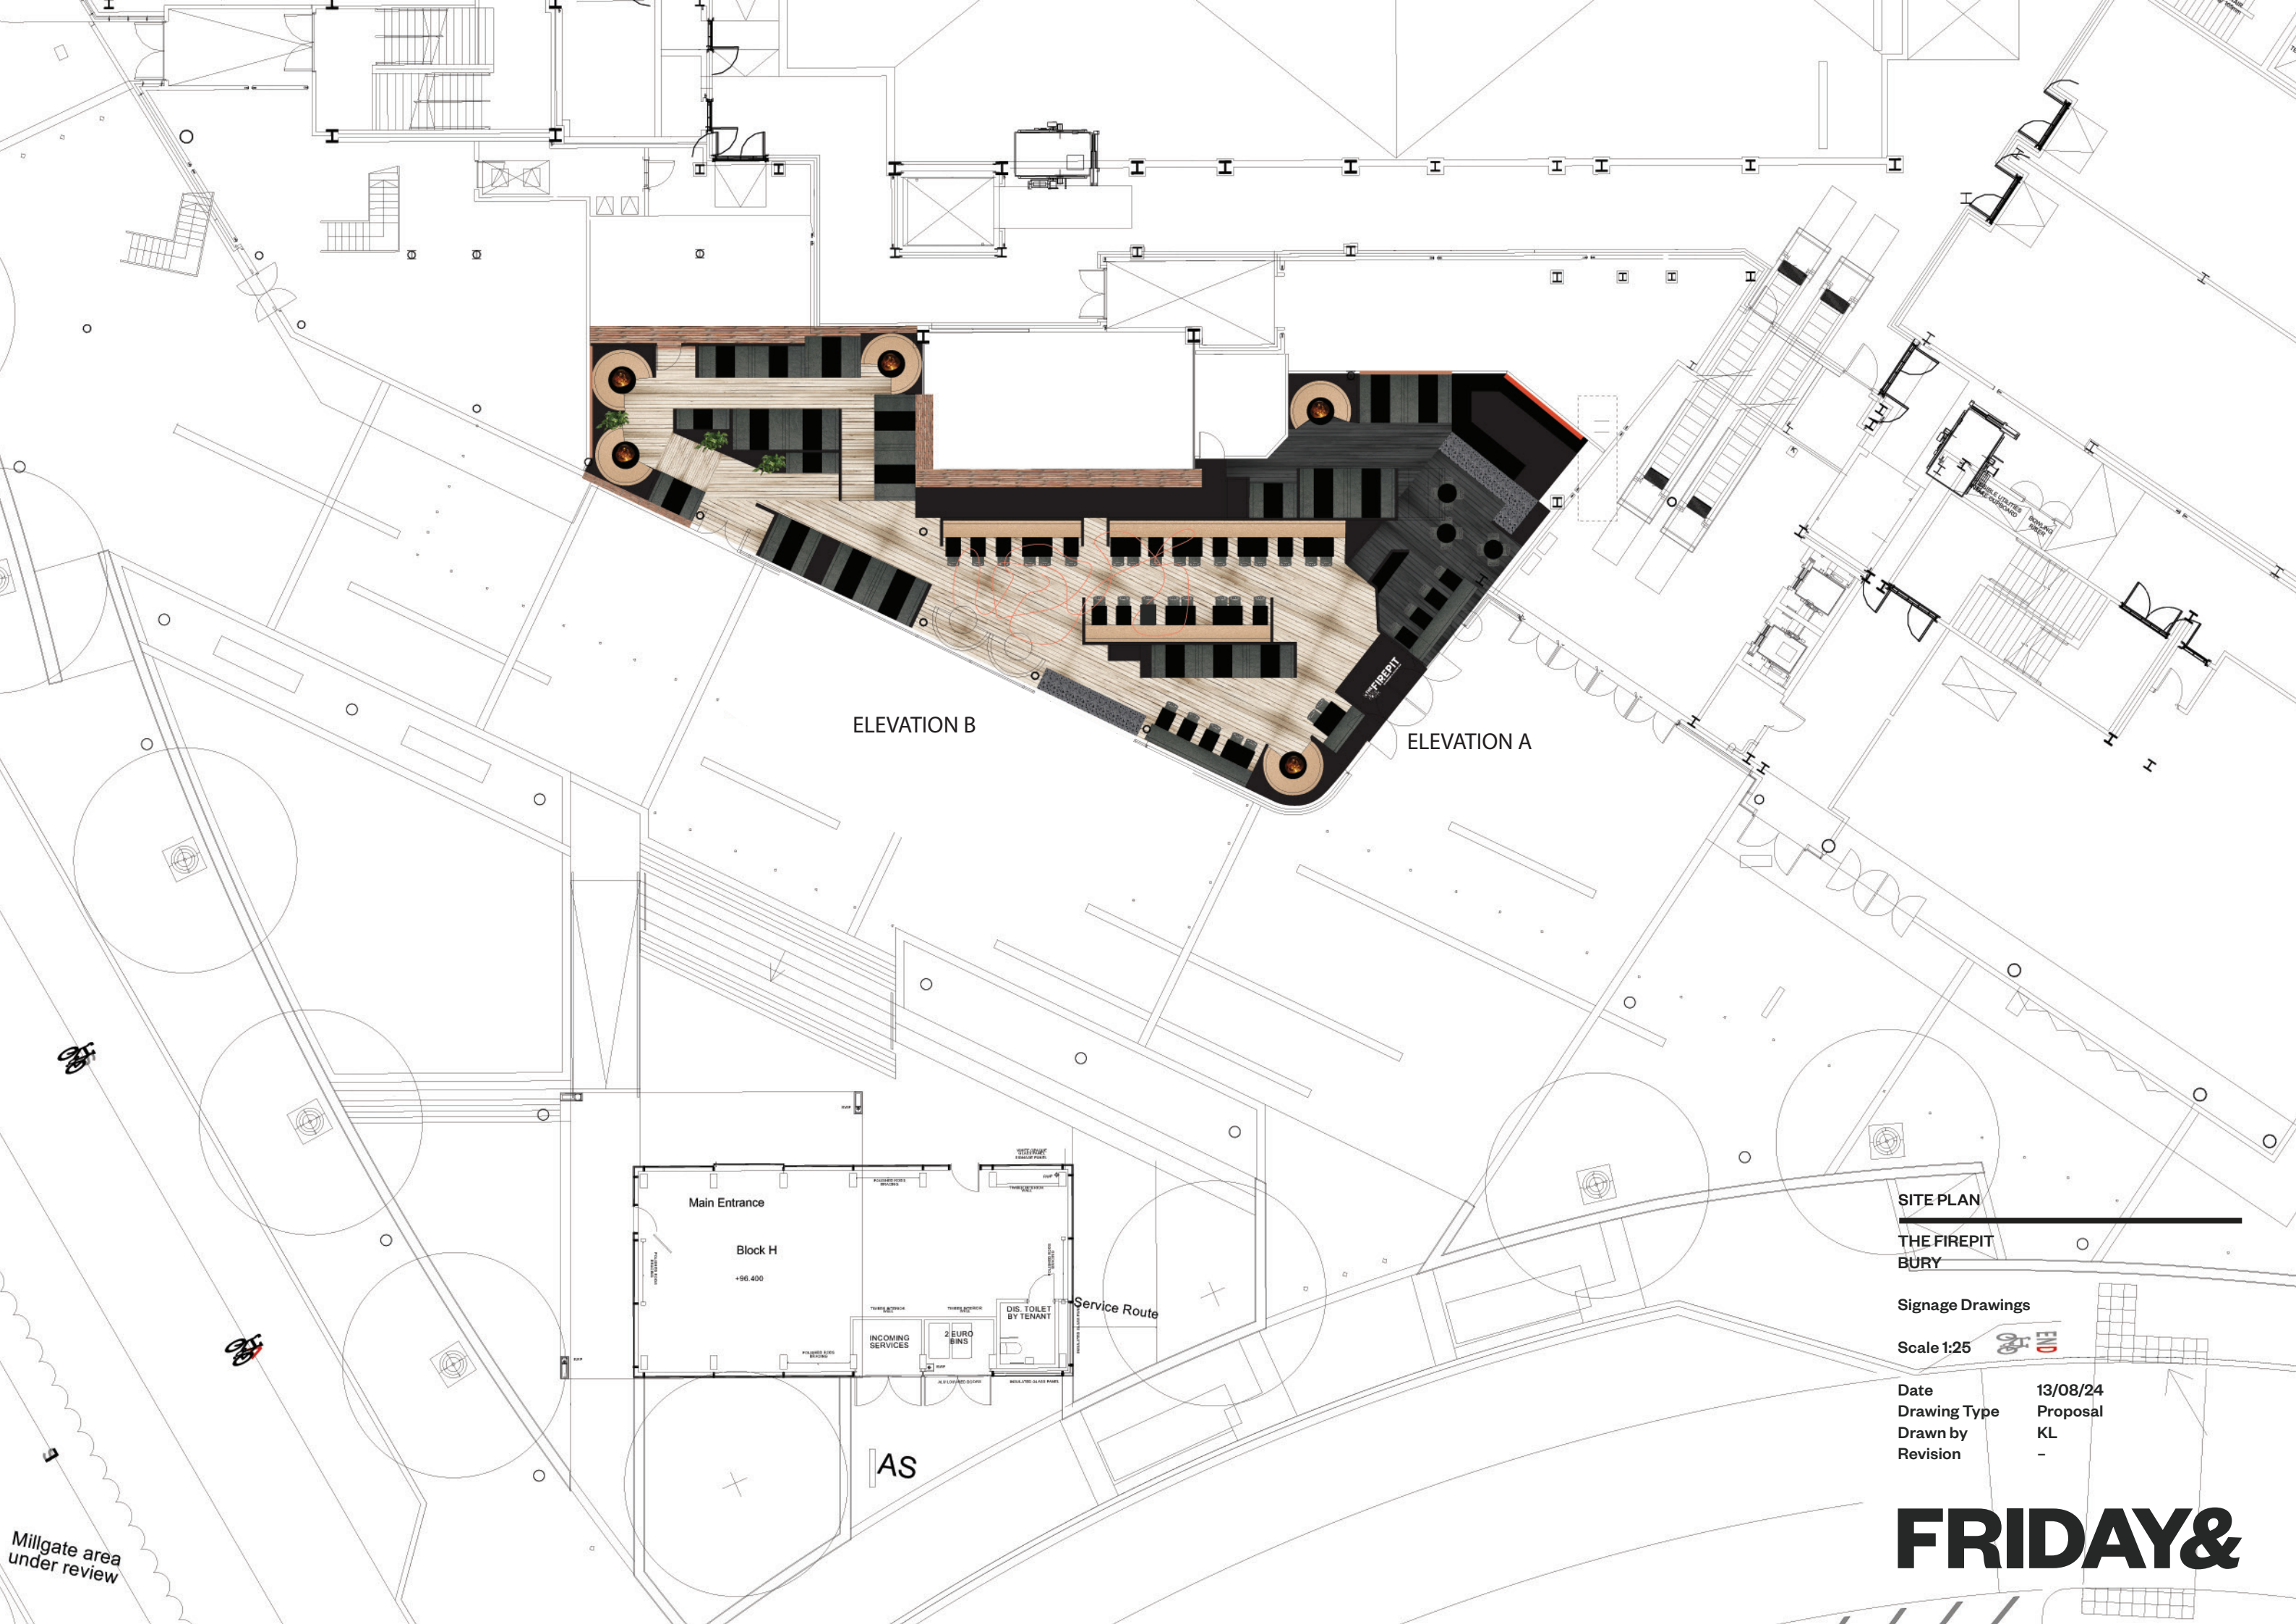

ELEVATION B

ELEVATION A

SITE PLAN
THE FIREPIT
BURY

Signage Drawings

Scale 1:25

Date
Drawing Type
Drawn by
Revision

13/08/24
Proposal
KL
-

FRIDAY&

Millgate area
under review