


PROPOSED INSTALLATION OF PV PANEL ARRAYS TO PITCHED / FLAT ROOFS.
TO BE MIN. 1000MM FROM THE ROOF EDGES.NO PROJECTION TO BE MORE
THAN 200MM ABOVE PITCHED ROOF OR 1000MM ABOVE FLAT ROOF LEVEL. 331no.
MODULES (1950X1134MM) TO PRODUCE 165.50 kWp

TYPICAL MOUNTING DETAIL - PITCHED / FLAT ROOF FOR STAND AND SEAM

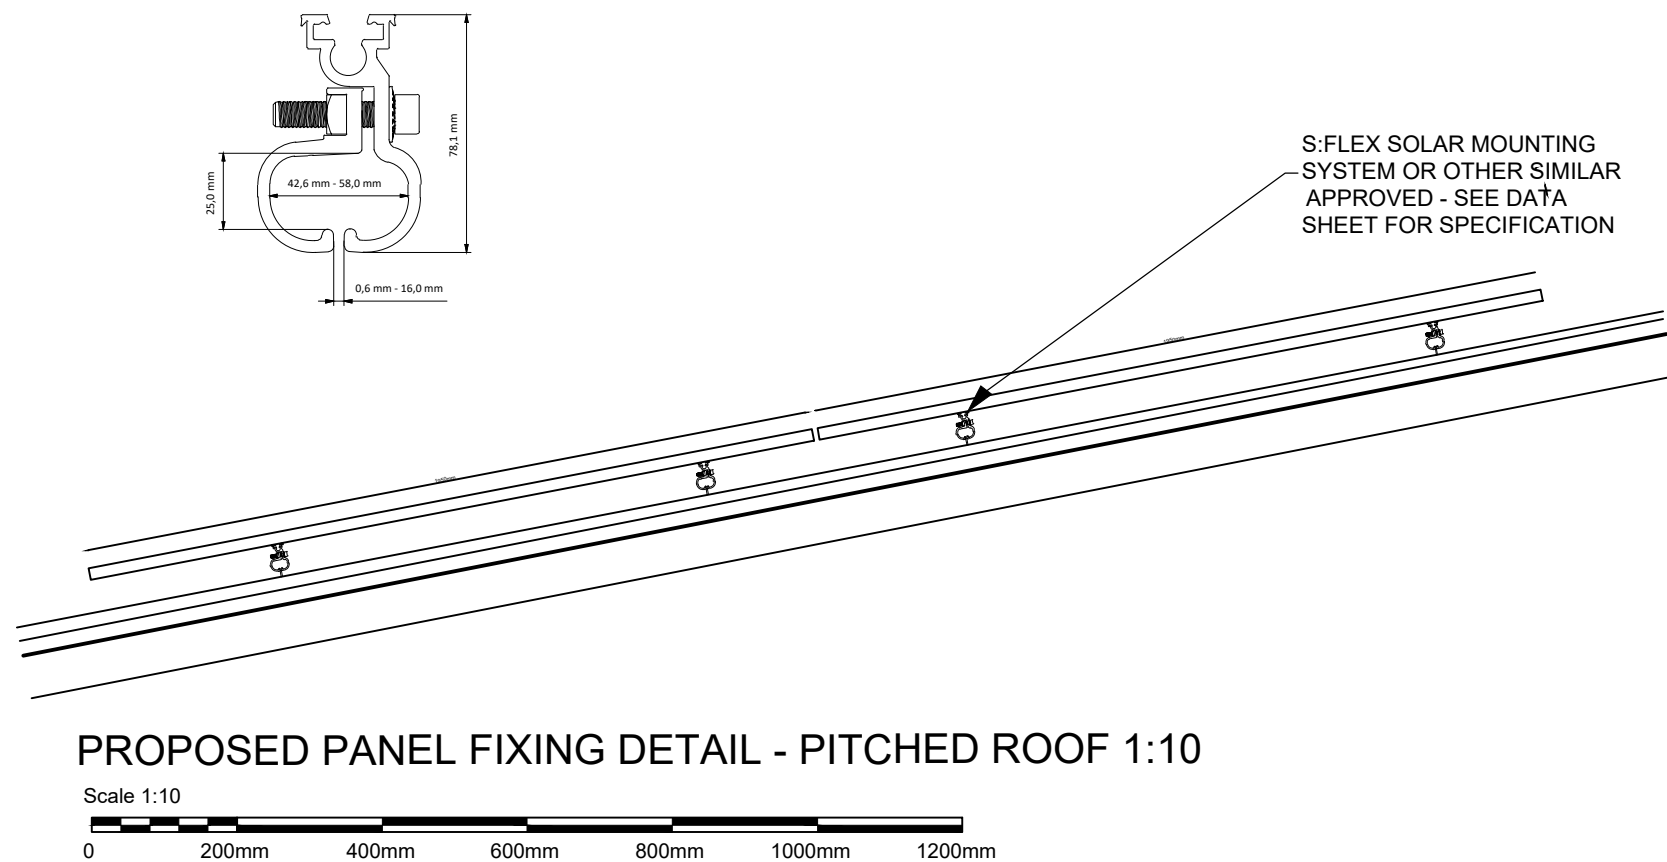

Ashcroft Electrical Services

72A New Court Way
Ormskirk
L39 2YT

01695 566 7520
info@ashcroftelectrical.co.uk

www.ashcroftelectrical.co.uk



LOCATION

Iceland, Bury,
Park 66, Pilsworth Rd,
Unsworth, Bury
BL9 8RS

PROJECT
Bury Iceland
PV Panel Installation

CLIENT
Ashcroft Electrical Services Ltd.

DRAWING TITLE

SITE LOCATION PLAN, PROPOSED
ROOF PLAN & PROPOSED DETAILS

PURPOSE OF ISSUE
PRIOR APPROVAL
PERMITTED DEVELOPMENT

DRAWN BY JB	CHECKED BY KD	DATE MAR 2025
SCALE (@ A1) AS INDICATED		PROJECT NUMBER TBD
DRAWING NUMBER 0001		REV -