


—

Y18

Y18

Master: MBNL / EE / H3G:		Project:		Purpose of Issue:		Issue:	
M004 MBNL		H3G UNILATERAL SW		Planning		D	
Date: 27/08/2020		Revision / Upgrade Description:					
Drawn: C.D.N		Client comments					
Checked: AF							
Approved: BS							
Master: MBNL / EE / H3G:		Project:		Purpose of Issue:		Issue:	
M003 MBNL		H3G UNILATERAL SW		Planning		C	
Date: 21/08/2020		Revision / Upgrade Description:					
Drawn: C.D.N		Client comments					
Checked: AF							
Approved: BS							
Master: MBNL / EE / H3G:		Project:		Purpose of Issue:		Issue:	
M002 MBNL		H3G UNILATERAL SW		Planning		B	
Date: 25/06/2020		Revision / Upgrade Description:					
Drawn: C.D.N		Site relocated					
Checked: AF							
Approved: BS							
Master: MBNL / EE / H3G:		Project:		Purpose of Issue:		Issue:	
M001 MBNL		H3G UNILATERAL SW		Planning		A	
Date: 20/06/2020		Revision / Upgrade Description:					
Drawn: C.D.N		First Issue					
Checked: AF							
Approved: BS							
 Hutchison 3G UK Limited Star House, 20 Grenfell Road Maddenhead, SL6 1EH Tel: 01628 765 000 Fax: 01628 765 001 H3G Base Station Information line: 0845 6043000 Available 8am-8pm Monday to Friday				Hatfield Business Park Hatfield Hertfordshire AL10 9BW Tel: 01707 315000 Fax: 01707 319001			
		Mobile Broadband Network Limited Sixth Floor, Thames Tower, Station Road, Reading, RG1 1LX					
Design Consultant & Principal Contractor:							
		WHP Telecoms Unit 1 Maple Park, Low Fields Avenue, Leeds LS12 6HH Tel: 01133023550 e-mail: info@whptelecoms.com					
Site Name:		WALSHAW ROAD					
Site ID:		786142					
Address:		WALSHAW ROAD, BURY GREATER, MANCHESTER, BL8 3AF					
Title:		001 DRAWING REGISTER					
Project:		H3G UNILATERAL SW					
Purpose of Issue:		PLANNING					
EE Cell ID:		MBNL Cell ID:		3UK Cell ID:			
76007		BRY020		BL0121			
Master Drawing No:							Issue:
786142_BRY020_76007_BL0121_M004							D


SITE LOCATION

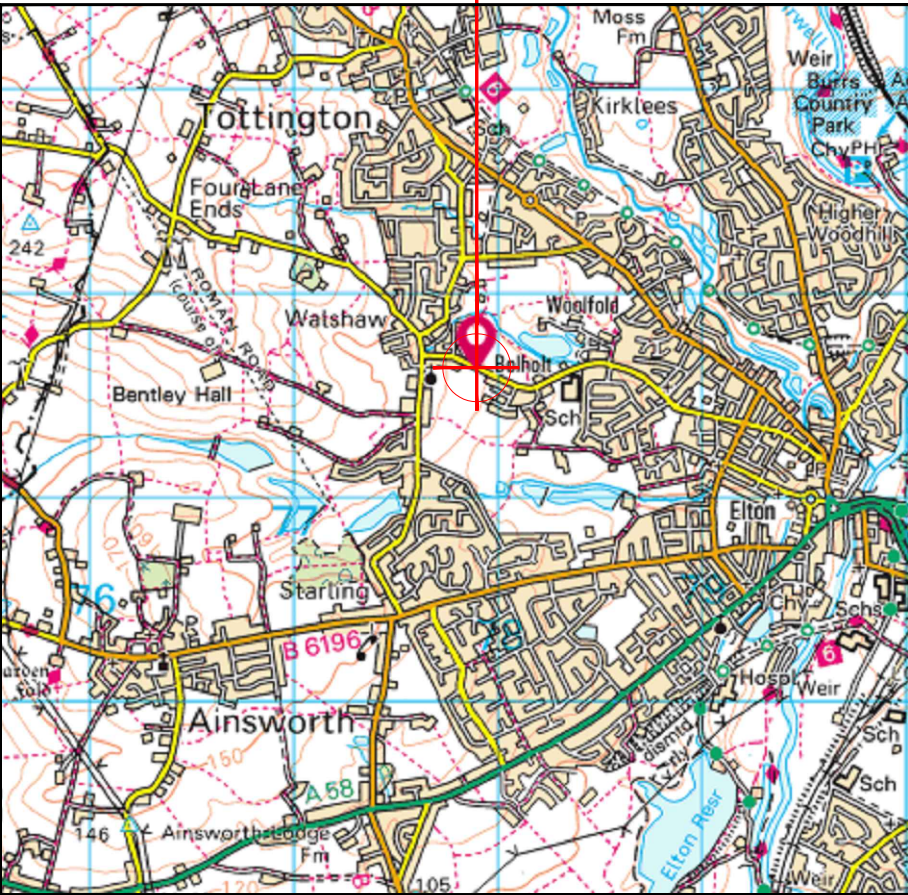

Reproduced by permission of Ordnance Survey on behalf of the Controller of Her Majesty's Stationery Office
All rights reserved. © Crown Copyright licence no. 100022432

SITE AREA PLAN

 
Scale 1:50000



SITE PHOTOGRAPH



PROPOSED SITE LOCATION

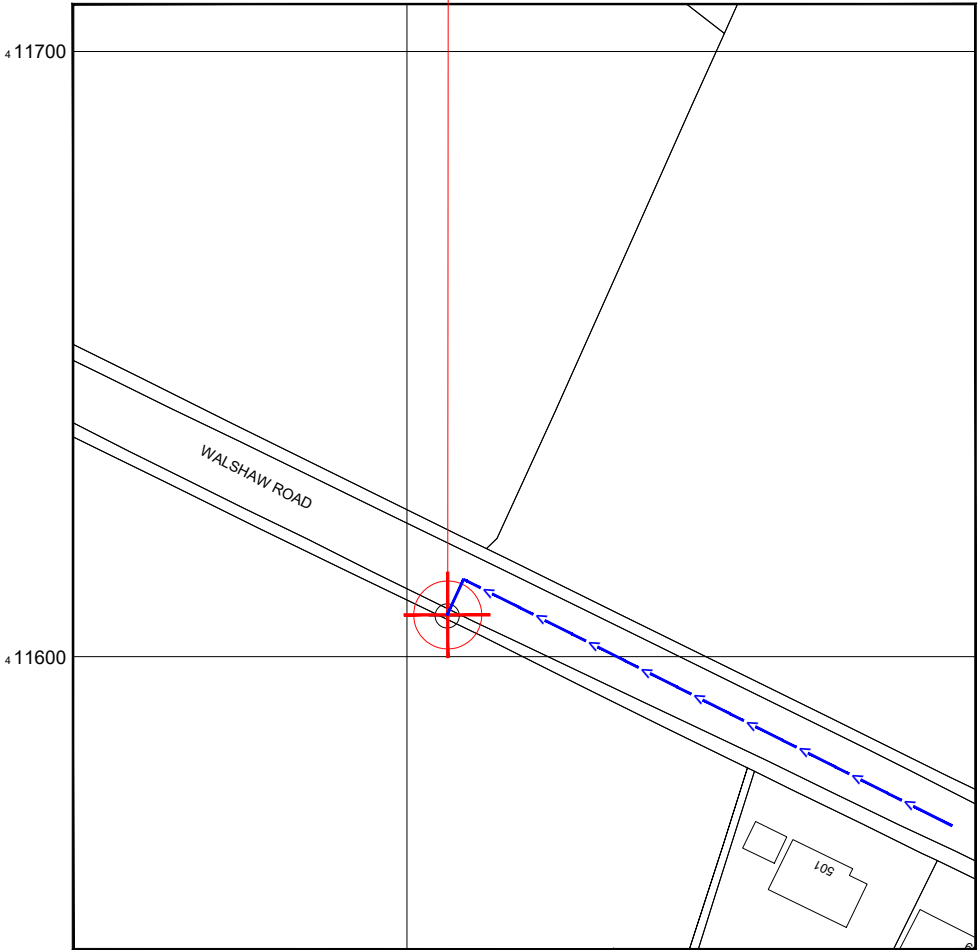


Reproduced by permission of Ordnance Survey on behalf of the Controller of Her Majesty's Stationery Office All rights reserved. © Crown Copyright licence no. 100062043

NGR E: 377905 N: 411609

SITE LOCATION PLAN

 Scale 1:1250



GOOGLE MAPS QR CODE

GOOGLE MAPS - <https://goo.gl/maps/cxg7Ka36kM8vBD14A>

GOOGLE STREETVIEW - <https://goo.gl/maps/rBL9Q5efF4LpT6Y96>

NOTES:

1. ALL DIMENSIONS IN MM UNLESS OTHERWISE NOTED.

DIRECTIONS TO SITE: Junction A56 & B6214 go north on B6214 take 3rd left hand turn you are now on Walshaw Rd. Follow road until you come to area with fenced off fields on both sides of road. Site located on rhs of road on footpath

Access Route To Site:



Access Route:



Master:	MBNL / EE / H3G:	Project:	Purpose of Issue:	Issue:
M004	MBNL	H3G UNILATERAL SW	Planning	D
Date:	27/08/2020	Revision / Upgrade Description:		
Drawn:	C.D.N	Client comments		
Checked:	AF			
Approved:	BS			
Master:	MBNL / EE / H3G:	Project:	Purpose of Issue:	Issue:
M003	MBNL	H3G UNILATERAL SW	Planning	C
Date:	21/08/2020	Revision / Upgrade Description:		
Drawn:	C.D.N	Client comments		
Checked:	AF			
Approved:	BS			
Master:	MBNL / EE / H3G:	Project:	Purpose of Issue:	Issue:
M002	MBNL	H3G UNILATERAL SW	Planning	B
Date:	25/06/2020	Revision / Upgrade Description:		
Drawn:	C.D.N	Site relocated		
Checked:	AF			
Approved:	BS			
Master:	MBNL / EE / H3G:	Project:	Purpose of Issue:	Issue:
M001	MBNL	H3G UNILATERAL SW	Planning	A
Date:	20/06/2020	Revision / Upgrade Description:		
Drawn:	C.D.N	First Issue		
Checked:	AF			
Approved:	BS			



Hutchison 3G UK Limited
Star House, 20 Grenfell Road
Maidenhead, SL6 1EH
Tel: 01628 765 000
Fax: 01628 765 001
H3G Base Station Information line:
0845 6043000
Available 8am-8pm Monday to Friday



Hatfield Business Park
Hatfield
Hertfordshire
AL10 9BW
Tel: 01707 315000
Fax: 01707 319001



Mobile Broadband Network Limited
Sixth Floor, Thames Tower, Station Road, Reading, RG1 1LX

Design Consultant & Principal Contractor:



WHP Telecoms

Unit 1 Maple Park,
Low Fields Avenue, Leeds
LS12 6HH

Tel: 01133023550
e-mail: info@whptelecoms.com

Site Name: WALSHAW ROAD

Site ID: 786142

Address: WALSHAW ROAD,
BURY GREATER,
MANCHESTER,
BL8 3AF


Title: 002 SITE LOCATION PLAN

Project: H3G UNILATERAL SW

Purpose of Issue: PLANNING

EE Cell ID:	MBNL Cell ID:	3UK Cell ID:
76007	BRY020	BL0121

Master Drawing No:	Issue:
786142_BRY020_76007_BL0121_M004	D

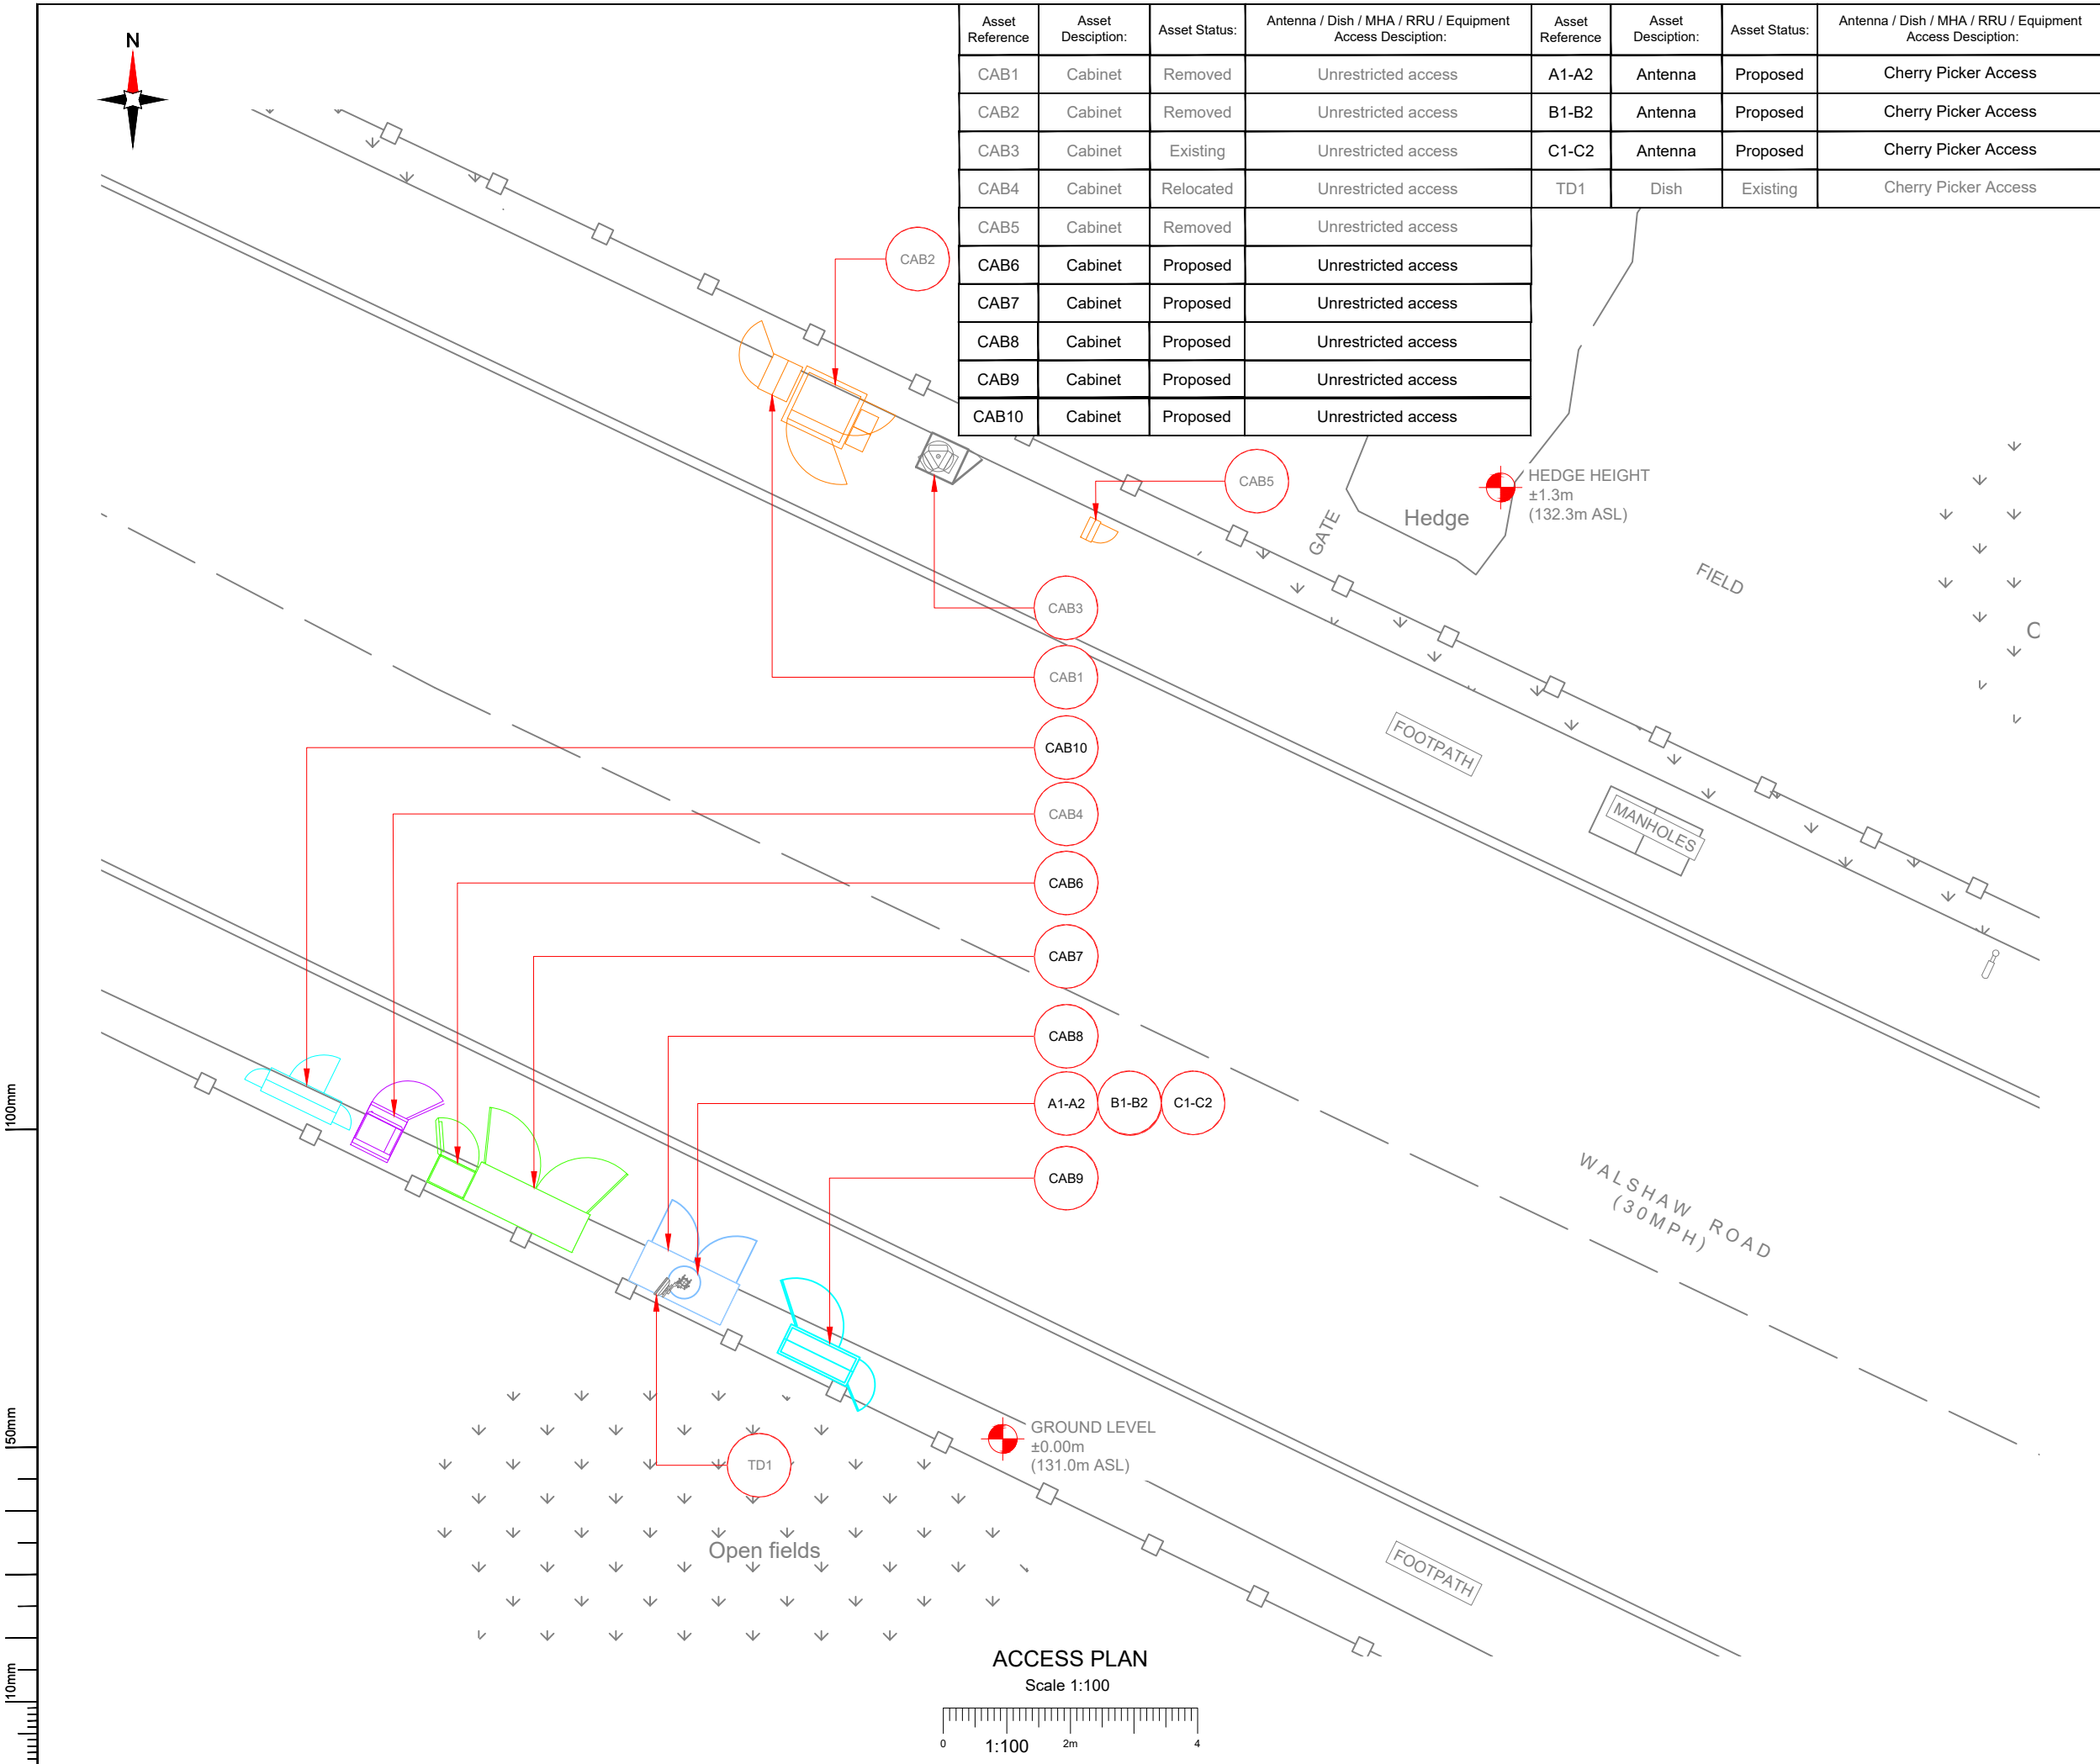

Asset Reference	Asset Description:	Asset Status:	Antenna / Dish / MHA / RRU / Equipment Access Description:	Asset Reference	Asset Description:	Asset Status:	Antenna / Dish / MHA / RRU / Equipment Access Description:
CAB1	Cabinet	Removed	Unrestricted access	A1-A2	Antenna	Proposed	Cherry Picker Access
CAB2	Cabinet	Removed	Unrestricted access	B1-B2	Antenna	Proposed	Cherry Picker Access
CAB3	Cabinet	Existing	Unrestricted access	C1-C2	Antenna	Proposed	Cherry Picker Access
CAB4	Cabinet	Relocated	Unrestricted access	TD1	Dish	Existing	Cherry Picker Access
CAB5	Cabinet	Removed	Unrestricted access				
CAB6	Cabinet	Proposed	Unrestricted access				
CAB7	Cabinet	Proposed	Unrestricted access				
CAB8	Cabinet	Proposed	Unrestricted access				
CAB9	Cabinet	Proposed	Unrestricted access				
CAB10	Cabinet	Proposed	Unrestricted access				

NOTES:

1. ALL DIMENSIONS IN MM UNLESS OTHERWISE NOTED.

DEFINED ACCESS ROUTE DESCRIPTION FROM SITE ENTRANCE TO THE EQUIPMENT:

Master:	MBNL / EE / H3G:	Project:	Purpose of Issue:	Issue:
M004	MBNL	H3G UNILATERAL SW	Planning	D
Date:	27/08/2020	Revision / Upgrade Description:		
Drawn:	C.D.N	Client comments		
Checked:	AF			
Approved:	BS			
Master:	MBNL / EE / H3G:	Project:	Purpose of Issue:	Issue:
M003	MBNL	H3G UNILATERAL SW	Planning	C
Date:	21/08/2020	Revision / Upgrade Description:		
Drawn:	C.D.N	Client comments		
Checked:	AF			
Approved:	BS			
Master:	MBNL / EE / H3G:	Project:	Purpose of Issue:	Issue:
M002	MBNL	H3G UNILATERAL SW	Planning	B
Date:	25/06/2020	Revision / Upgrade Description:		
Drawn:	C.D.N	Site relocated		
Checked:	AF			
Approved:	BS			
Master:	MBNL / EE / H3G:	Project:	Purpose of Issue:	Issue:
M001	MBNL	H3G UNILATERAL SW	Planning	A
Date:	20/06/2020	Revision / Upgrade Description:		
Drawn:	C.D.N	First Issue		
Checked:	AF			
Approved:	BS			

Hutchison 3G UK Limited
Star House, 20 Grenfell Road
Maidenhead, SL6 1EH
Tel: 01628 765 000
Fax: 01628 765 001
H3G Base Station Information line:
0845 6043000
Available 8am-8pm Monday to Friday

Hatfield Business Park
Hatfield
Hertfordshire
AL10 9BW
Tel: 01707 315000
Fax: 01707 319001

Design Consultant & Principal Contractor:

WHP Telecoms
Unit 1 Maple Park,
Low Fields Avenue, Leeds
LS12 6HH
Tel: 01133023550
e-mail: info@whptelecoms.com

Site Name:

WALSHAW ROAD

Site ID:

786142

Address:

WALSHAW ROAD,
BURY GREATER,
MANCHESTER,
BL8 3AF

Title:

003 ACCESS PLAN

Project:

H3G UNILATERAL SW

Purpose of Issue:

PLANNING


EE Cell ID:	MBNL Cell ID:	3UK Cell ID:
76007	BRY020	BL0121

Master Drawing No:

786142_BRY020_76007_BL0121_M004

Issue:

D

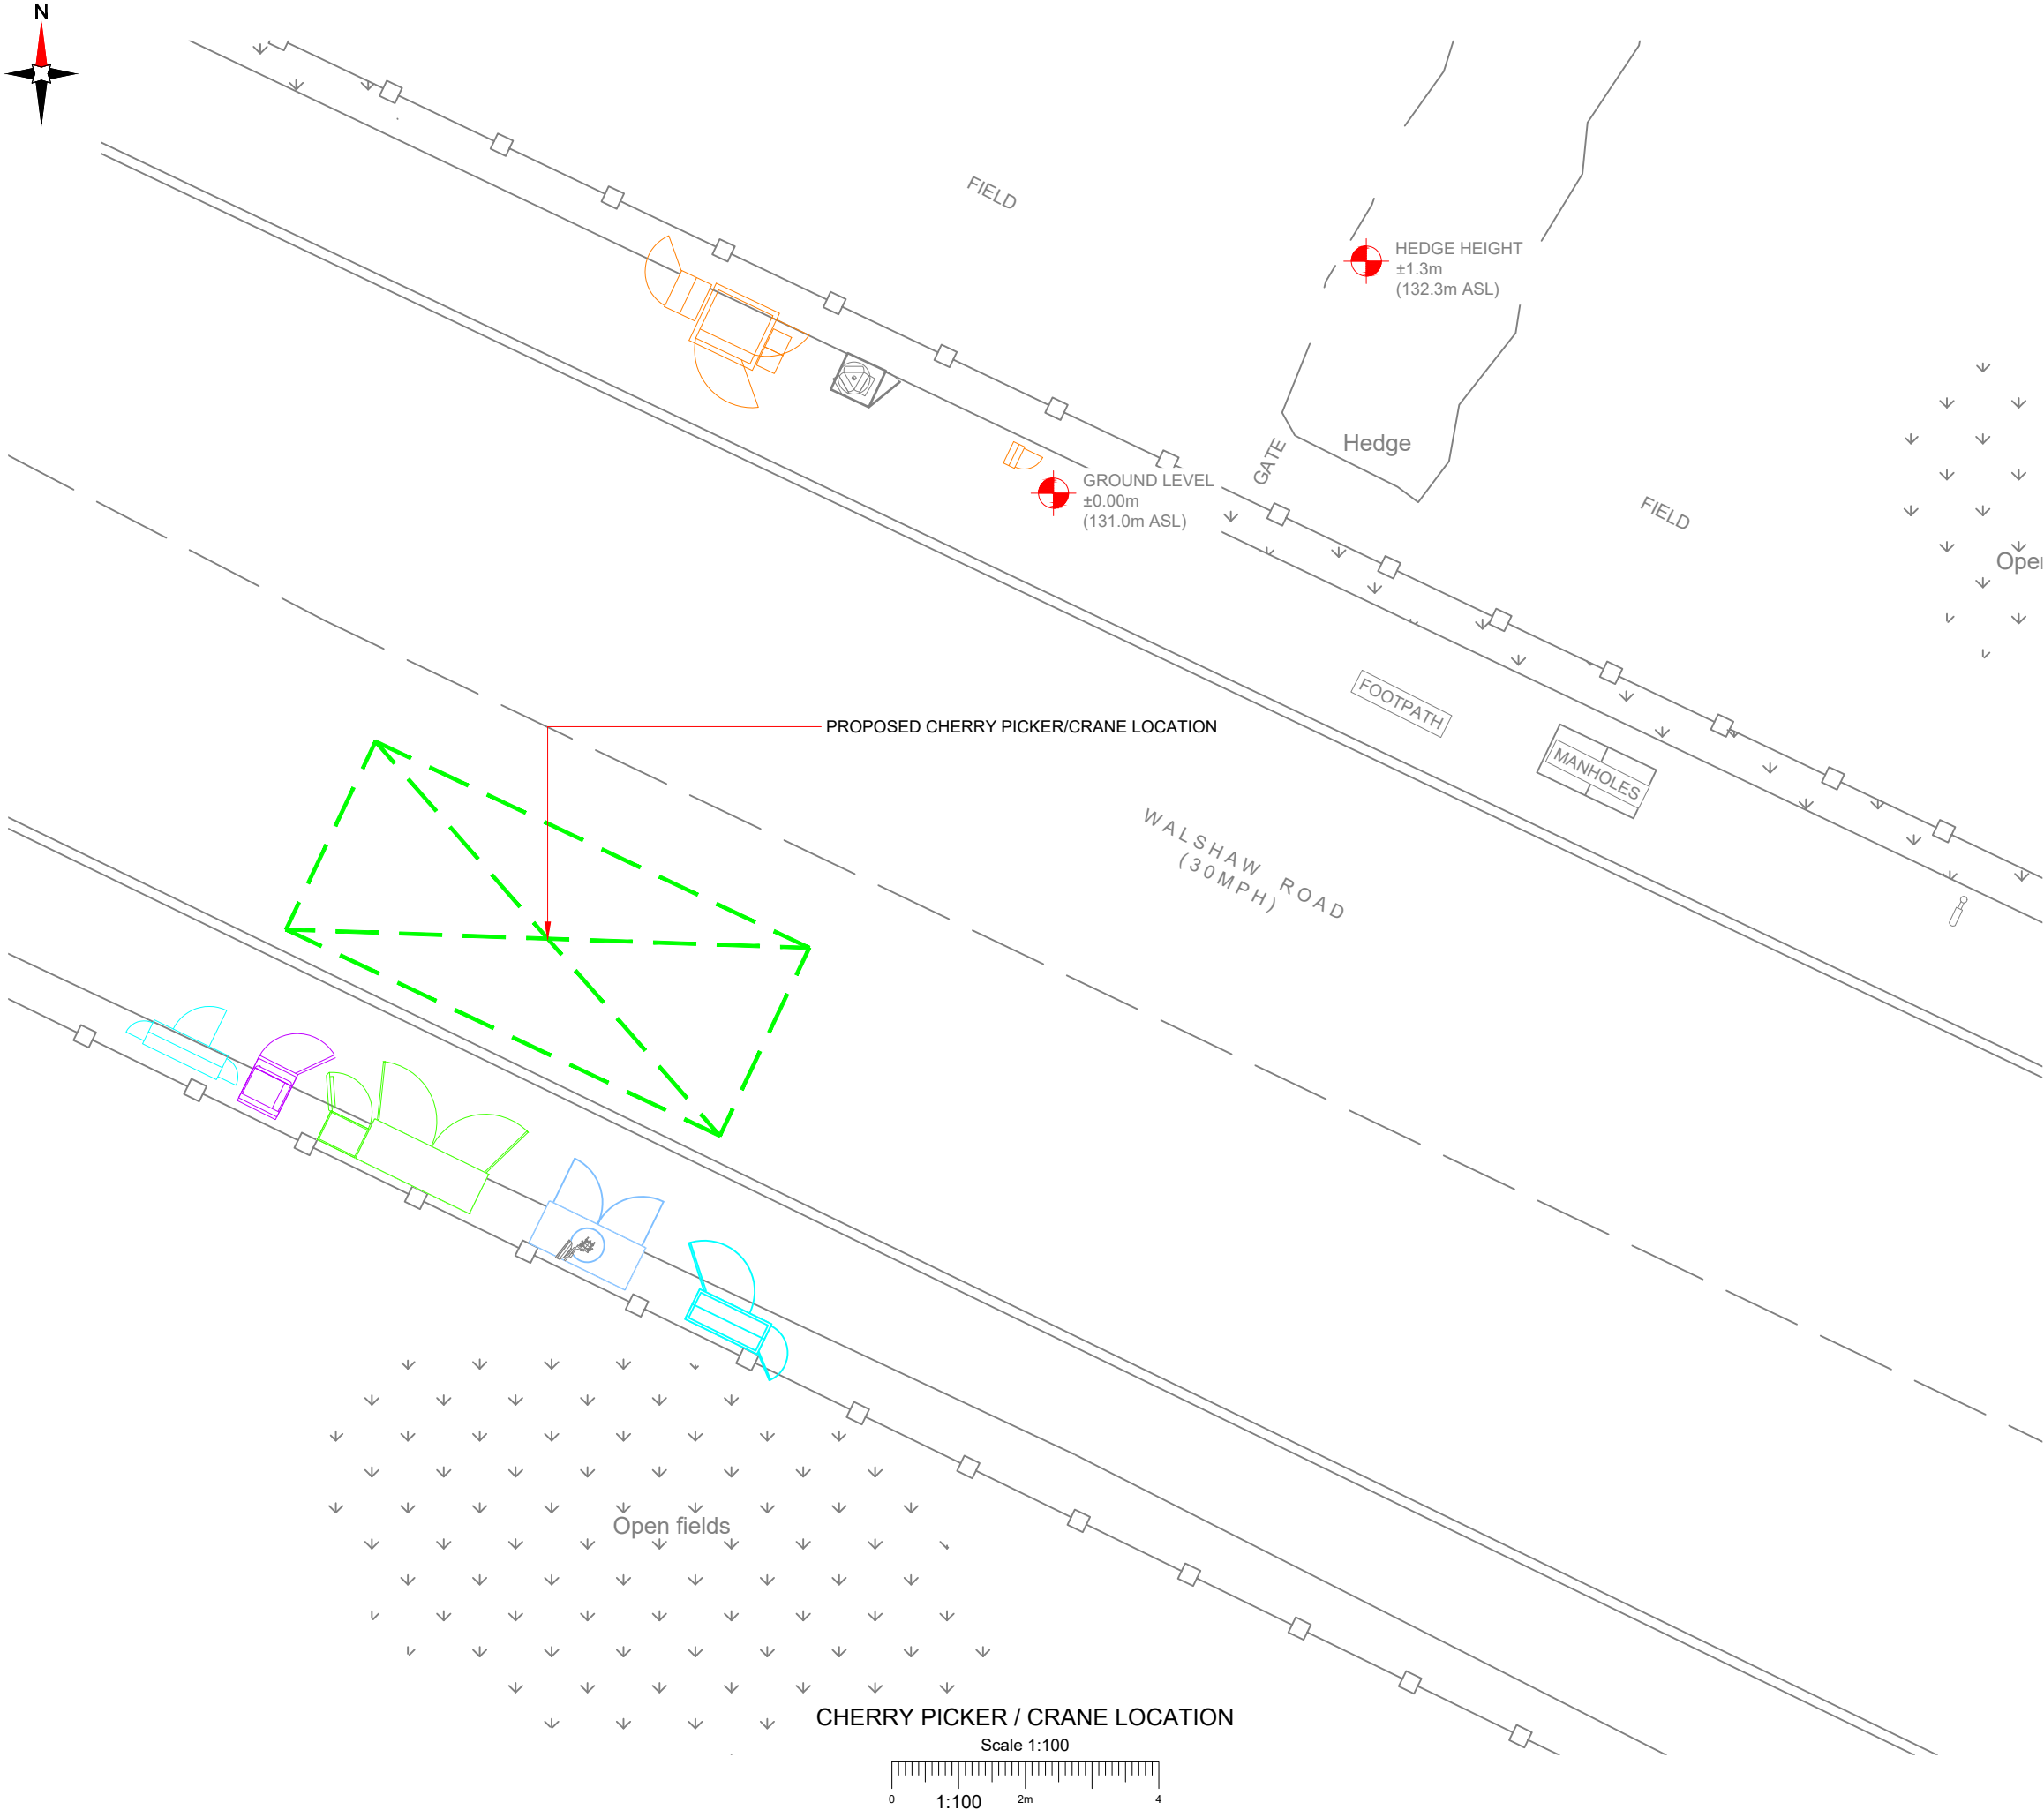

NOTES:

 1. ALL DIMENSIONS IN MM UNLESS OTHERWISE NOTED.

 PROPOSED CRANE OR CHERRY PICKER LOCATION:

Master:	MBNL / EE / H3G:	Project:	Purpose of Issue:	Issue:
M004	MBNL	H3G UNILATERAL SW	Planning	D
Date:	27/08/2020	Revision / Upgrade Description:		
Drawn:	C.D.N	Client comments		
Checked:	AF			
Approved:	BS			
Master:	MBNL / EE / H3G:	Project:	Purpose of Issue:	Issue:
M003	MBNL	H3G UNILATERAL SW	Planning	C
Date:	21/08/2020	Revision / Upgrade Description:		
Drawn:	C.D.N	Client comments		
Checked:	AF			
Approved:	BS			
Master:	MBNL / EE / H3G:	Project:	Purpose of Issue:	Issue:
M002	MBNL	H3G UNILATERAL SW	Planning	B
Date:	25/06/2020	Revision / Upgrade Description:		
Drawn:	C.D.N	Site relocated		
Checked:	AF			
Approved:	BS			
Master:	MBNL / EE / H3G:	Project:	Purpose of Issue:	Issue:
M001	MBNL	H3G UNILATERAL SW	Planning	A
Date:	20/06/2020	Revision / Upgrade Description:		
Drawn:	C.D.N	First Issue		
Checked:	AF			
Approved:	BS			

Hutchison 3G UK Limited
Star House, 20 Grenfell Road
Maidenhead, SL6 1EH
Tel: 01628 765 000
Fax: 01628 765 001

H3G Base Station Information line:
0845 6043000
Available 8am-8pm Monday to Friday

Hatfield Business Park
Hatfield
Hertfordshire
AL10 9BW

Tel: 01707 315000
Fax: 01707 319001

Mobile Broadband Network Limited
Sixth Floor, Thames Tower, Station Road, Reading, RG1 1LX

Design Consultant & Principal Contractor:

WHP Telecoms
Unit 1 Maple Park,
Low Fields Avenue, Leeds
LS12 6HH

Tel: 01133023550
e-mail: info@whptelecoms.com

Site Name:

WALSHAW ROAD

Site ID:

786142

Address:

**WALSHAW ROAD,
BURY GREATER,
MANCHESTER,
BL8 3AF**

Title:

005 CHERRY PICKER & CRANE LOCATION

Project:

H3G UNILATERAL SW

Purpose of Issue:

PLANNING


EE Cell ID:	MBNL Cell ID:	3UK Cell ID:
76007	BRY020	BL0121

Master Drawing No:

786142_BRY020_76007_BL0121_M004

Issue:

D

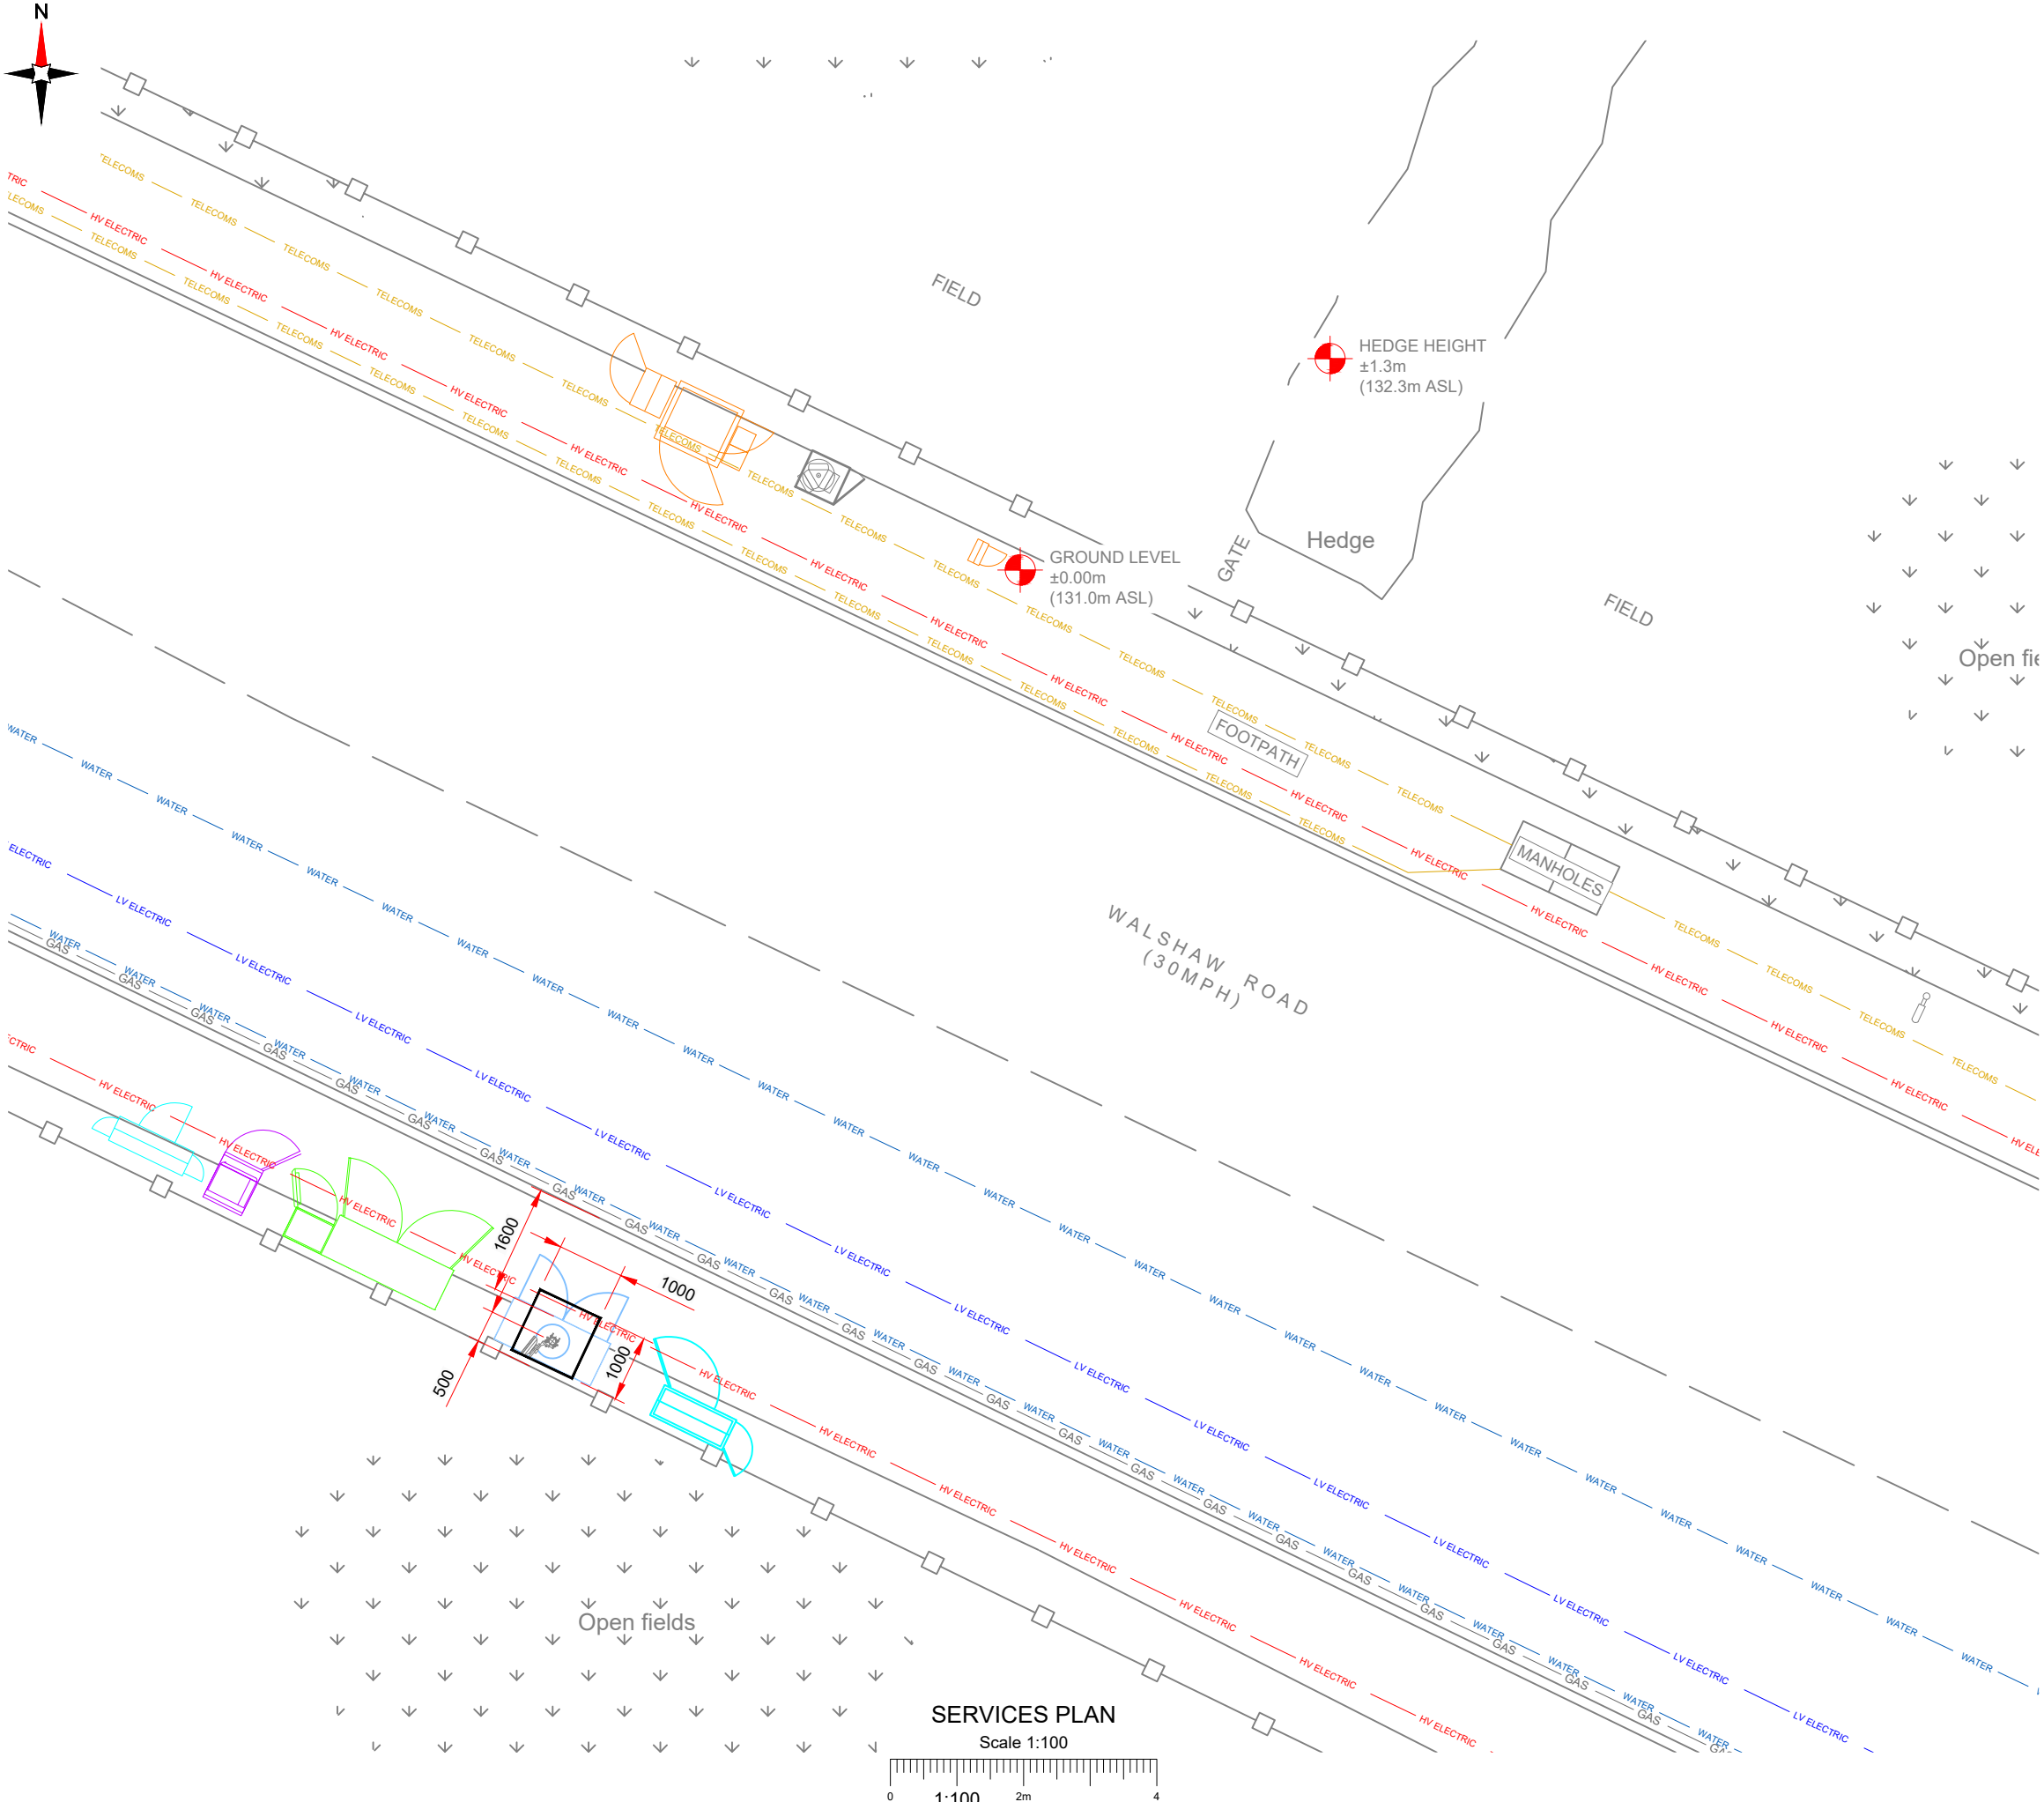

NOTES:

1. ALL DIMENSIONS IN MM UNLESS OTHERWISE NOTED.

SERVICES:

WATER

WATER

WATER

GAS

GAS

GAS

TELECOMS

TELECOMS

TELECOMS

LV ELECTRIC

LV ELECTRIC

LV ELECTRIC

HV ELECTRIC

HV ELECTRIC

HV ELECTRIC

Master:	MBNL / EE / H3G:	Project:	Purpose of Issue:	Issue:
M004	MBNL	H3G UNILATERAL SW	Planning	D
Date:	27/08/2020	Revision / Upgrade Description:		
Drawn:	C.D.N	Client comments		
Checked:	AF			
Approved:	BS			
Master:	MBNL / EE / H3G:	Project:	Purpose of Issue:	Issue:
M003	MBNL	H3G UNILATERAL SW	Planning	C
Date:	21/08/2020	Revision / Upgrade Description:		
Drawn:	C.D.N	Client comments		
Checked:	AF			
Approved:	BS			
Master:	MBNL / EE / H3G:	Project:	Purpose of Issue:	Issue:
M002	MBNL	H3G UNILATERAL SW	Planning	B
Date:	25/06/2020	Revision / Upgrade Description:		
Drawn:	C.D.N	Site relocated		
Checked:	AF			
Approved:	BS			
Master:	MBNL / EE / H3G:	Project:	Purpose of Issue:	Issue:
M001	MBNL	H3G UNILATERAL SW	Planning	A
Date:	20/06/2020	Revision / Upgrade Description:		
Drawn:	C.D.N	First Issue		
Checked:	AF			
Approved:	BS			

Hutchison 3G UK Limited
Star House, 20 Grenfell Road
Maidenhead, SL6 1EH
Tel: 01628 765 000
Fax: 01628 765 001

H3G Base Station Information line:
0845 6043000
Available 8am-8pm Monday to Friday

Hatfield Business Park
Hatfield
Hertfordshire
AL10 9BW

Tel: 01707 315000
Fax: 01707 319001

Mobile Broadband Network Limited
Sixth Floor, Thames Tower, Station Road, Reading, RG1 1LX

Design Consultant & Principal Contractor:

WHP Telecoms
Unit 1 Maple Park,
Low Fields Avenue, Leeds
LS12 6HH

Tel: 01133023550
e-mail: info@whptelecoms.com

Site Name:

WALSHAW ROAD

Site ID:

786142

Address:

WALSHAW ROAD,
BURY GREATER,
MANCHESTER,
BL8 3AF

Title:

006 SERVICES PLAN

Project:

H3G UNILATERAL SW

Purpose of Issue:

PLANNING

EE Cell ID:	MBNL Cell ID:	3UK Cell ID:
76007	BRY020	BL0121

Master Drawing No:

786142_BRY020_76007_BL0121_M004

Issue:

D

Criteria	Self-approval	Proposal
Distance Between Existing and New Pole	<20m	13.47m
Difference Between Existing CL and New CL AMSL	Not Lower	2.05m
Azimuth Change	<5deg	NONE
Difference in Dish Height	<0.5m	N/A




1. ALL DIMENSIONS IN MM UNLESS OTHERWISE NOTED.

	Hutchison 3G UK Limited Star House, 20 Grenville Road Maidenhead, SL6 1EH Tel: 01628 765 000 Fax: 01628 765 001		Hatfield Business Park Hatfield Hertfordshire AL10 9BW
	H3G Base Station Information Line: 0845 6043000 Available 8am-8pm Monday to Friday		Tel: 01707 315000 Fax: 01707 319001

Mobile Broadband Network Limited
Sixth Floor, Thames Tower, Station Road, Reading, RG1 1LX


Tel: 01133023550
e-mail: info@whptelecoms.com

Master Drawing No:	Issue:
786142 BRY020 76007 BL0121 M004	D

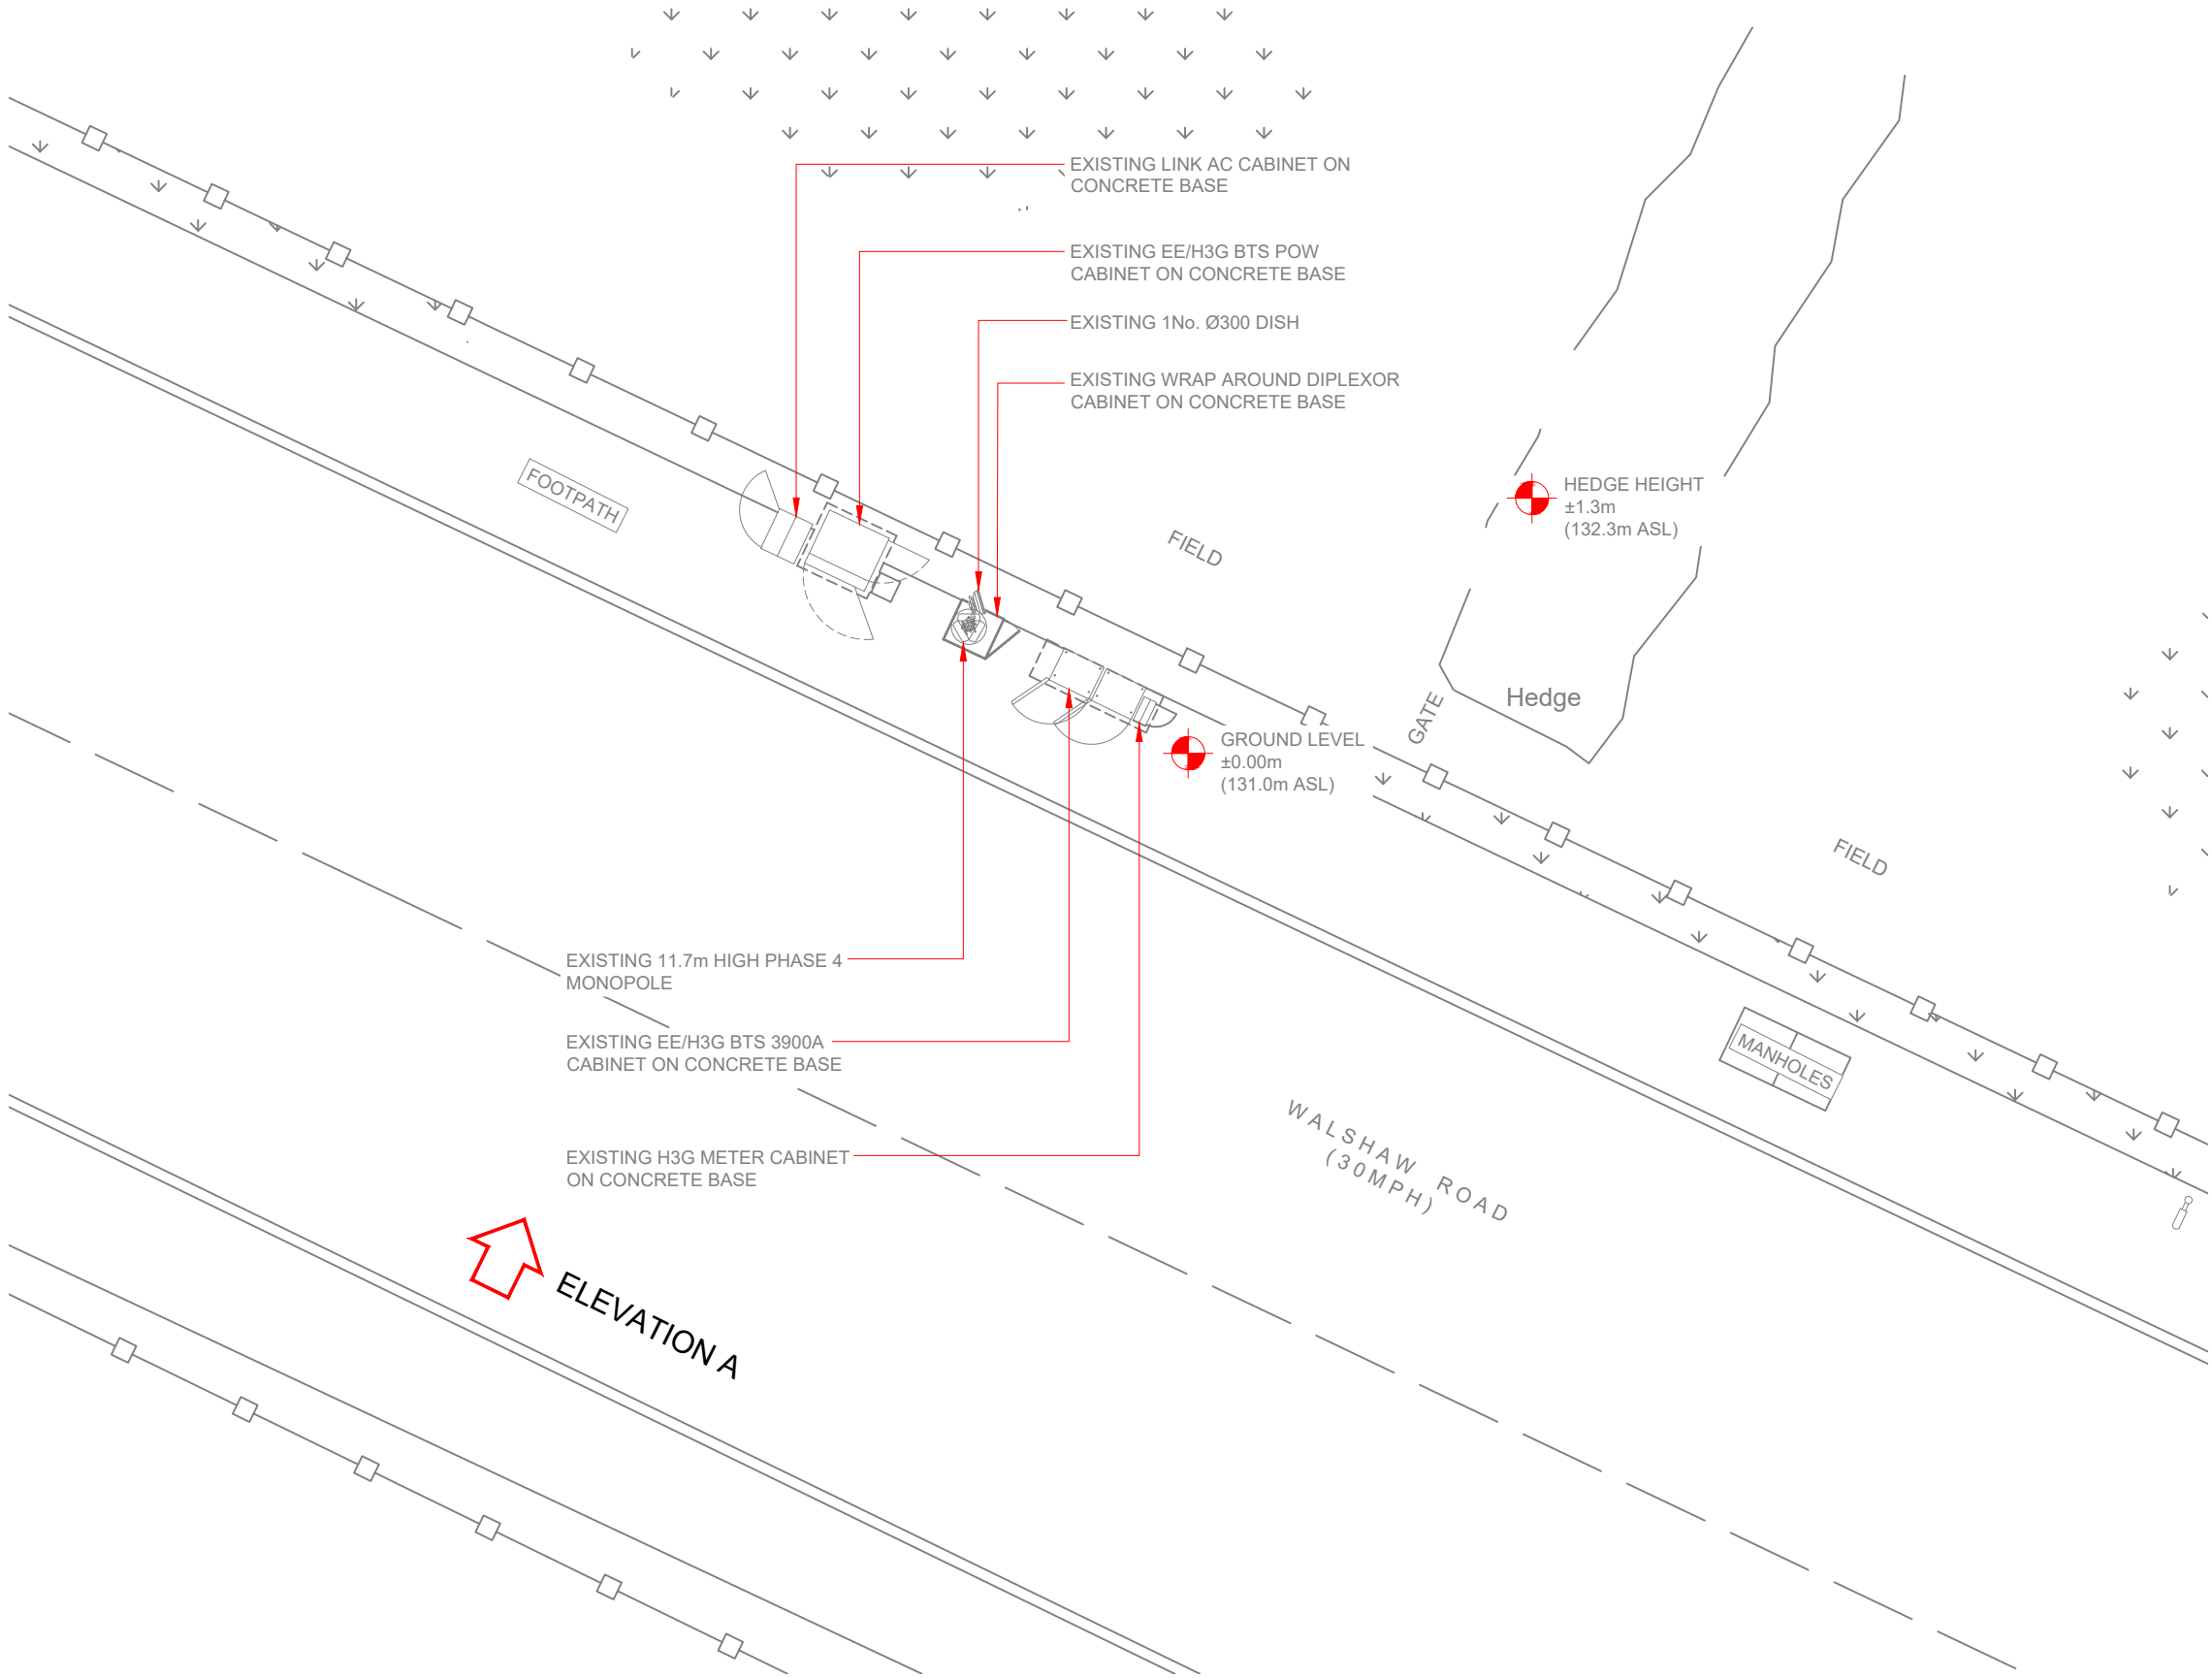

EXISTING SITE PLAN

 Scale 1:100



3G / 4G Antenna ID	Existing 3G Bearing
EA1	0°
EB1	120°
EC1	240°

NOTES:

1. ALL DIMENSIONS IN MM UNLESS OTHERWISE NOTED.

Master:	MBNL / EE / H3G:	Project:	Purpose of Issue:	Issue:
M004	MBNL	H3G UNILATERAL SW	Planning	D
Date:	27/08/2020	Revision / Upgrade Description:		
Drawn:	C.D.N	Client comments		
Checked:	AF			
Approved:	BS			
Master:	MBNL / EE / H3G:	Project:	Purpose of Issue:	Issue:
M003	MBNL	H3G UNILATERAL SW	Planning	C
Date:	21/08/2020	Revision / Upgrade Description:		
Drawn:	C.D.N	Client comments		
Checked:	AF			
Approved:	BS			
Master:	MBNL / EE / H3G:	Project:	Purpose of Issue:	Issue:
M002	MBNL	H3G UNILATERAL SW	Planning	B
Date:	25/06/2020	Revision / Upgrade Description:		
Drawn:	C.D.N	Site relocated		
Checked:	AF			
Approved:	BS			
Master:	MBNL / EE / H3G:	Project:	Purpose of Issue:	Issue:
M001	MBNL	H3G UNILATERAL SW	Planning	A
Date:	20/06/2020	Revision / Upgrade Description:		
Drawn:	C.D.N	First Issue		
Checked:	AF			
Approved:	BS			



Hutchison 3G UK Limited
Star House, 20 Grenfell Road
Maidenhead, SL6 1EH
Tel: 01628 765 000
Fax: 01628 765 001

H3G Base Station Information line:
0845 6043000
Available 8am-8pm Monday to Friday



Hatfield Business Park
Hatfield
Hertfordshire
AL10 9BW

Tel: 01707 315000
Fax: 01707 319001



Mobile Broadband Network Limited
Sixth Floor, Thames Tower, Station Road, Reading, RG1 1LX

Design Consultant & Principal Contractor:



WHP Telecoms
Unit 1 Maple Park,
Low Fields Avenue, Leeds
LS12 6HH

Tel: 01133023550
e-mail: info@whptelecoms.com

Site Name:	WALSHAW ROAD		
Site ID:	786142		
Address:	WALSHAW ROAD, BURY GREATER, MANCHESTER, BL8 3AF		
Title:	100 EXISTING SITE PLAN		
Project:	H3G UNILATERAL SW		
Purpose of Issue:	PLANNING		
EE Cell ID:	MBNL Cell ID:	3UK Cell ID:	
76007	BRY020	BL0121	
Master Drawing No: 786142_BRY020_76007_BL0121_M004			Issue: D

3G / 4G Antenna ID	Existing 3G Bearing
EA1	0°
EB1	120°
EC1	240°

NOTES:	
1.	ALL DIMENSIONS IN MM UNLESS OTHERWISE NOTED.

Master:	MBNL / EE / H3G:	Project:	H3G UNILATERAL SW	Purpose of Issue:	Planning	Issue:	D
M004	MBNL						
Date:	27/08/2020	Revision / Upgrade Description:					
Drawn:	C.D.N	Client comments					
Checked:	AF						
Approved:	BS						
Master:	MBNL / EE / H3G:	Project:	H3G UNILATERAL SW	Purpose of Issue:	Planning	Issue:	C
M003	MBNL						
Date:	21/08/2020	Revision / Upgrade Description:					
Drawn:	C.D.N	Client comments					
Checked:	AF						
Approved:	BS						
Master:	MBNL / EE / H3G:	Project:	H3G UNILATERAL SW	Purpose of Issue:	Planning	Issue:	B
M002	MBNL						
Date:	25/06/2020	Revision / Upgrade Description:					
Drawn:	C.D.N	Site relocated					
Checked:	AF						
Approved:	BS						
Master:	MBNL / EE / H3G:	Project:	H3G UNILATERAL SW	Purpose of Issue:	Planning	Issue:	A
M001	MBNL						
Date:	20/06/2020	Revision / Upgrade Description:					
Drawn:	C.D.N	First Issue					
Checked:	AF						
Approved:	BS						



Hutchison 3G UK Limited
Star House, 20 Grenfell Road
Maidenhead, SL6 1EH
Tel: 01628 765 000
Fax: 01628 765 001



Hatfield Business Park
Hatfield
Hertfordshire
AL10 9BW

Tel: 01707 315000
Fax: 01707 319001



Mobile Broadband Network Limited
Sixth Floor, Thames Tower, Station Road, Reading, RG1 1LX



Design Consultant & Principal Contractor:




WHP Telecoms
Unit 1 Maple Park,
Low Fields Avenue, Leeds
LS12 6HH

Tel: 01133023550
e-mail: info@whptelecoms.com

Site Name:	WALSHAW ROAD	
Site ID:	786142	
Address:	WALSHAW ROAD, BURY GREATER, MANCHESTER, BL8 3AF	
Title:	150 EXISTING SITE ELEVATION A	
Project:	H3G UNILATERAL SW	
Purpose of Issue:	PLANNING	
EE Cell ID:	MBNL Cell ID:	3UK Cell ID:
76007	BRY020	BL0121
Master Drawing No:		Issue:
786142_BRY020_76007_BL0121_M004		D

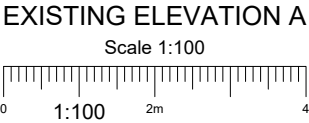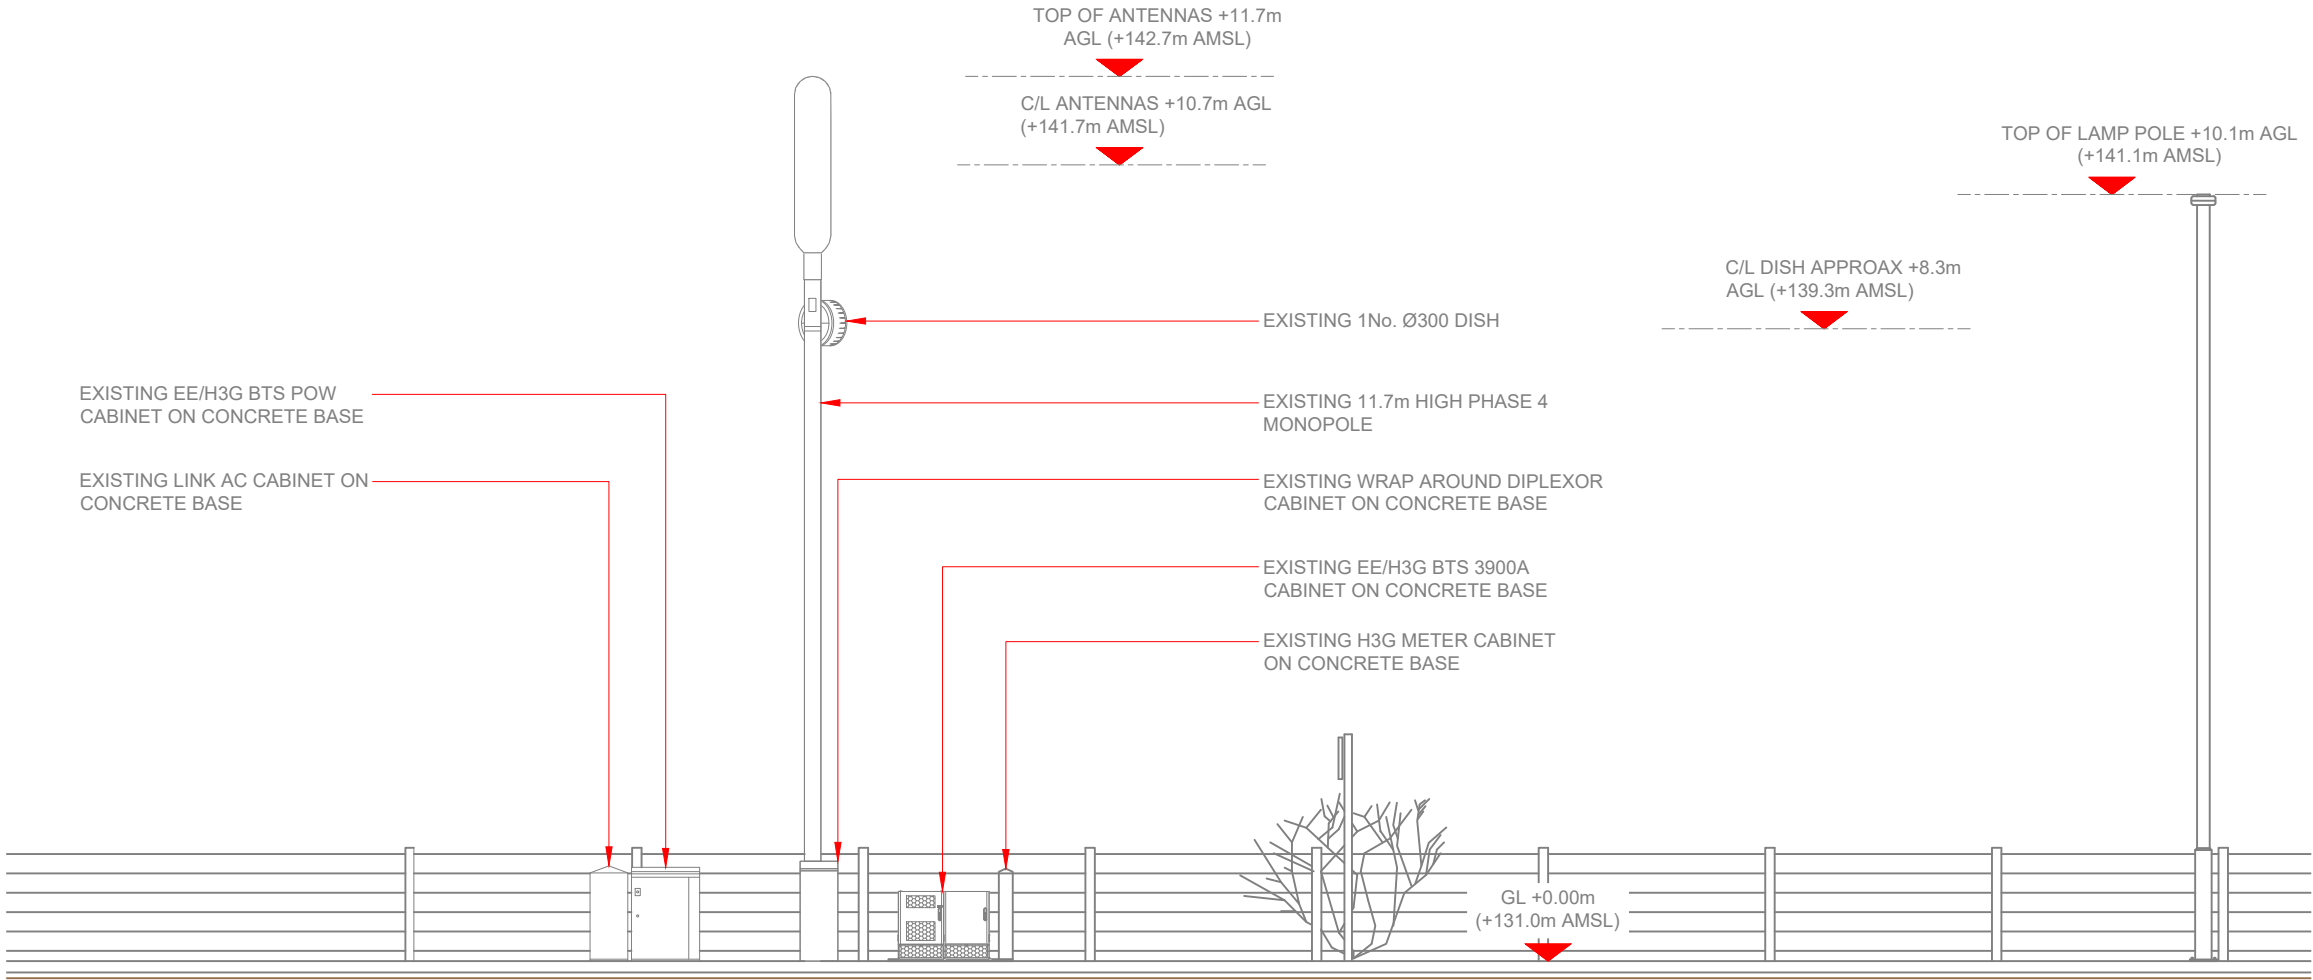

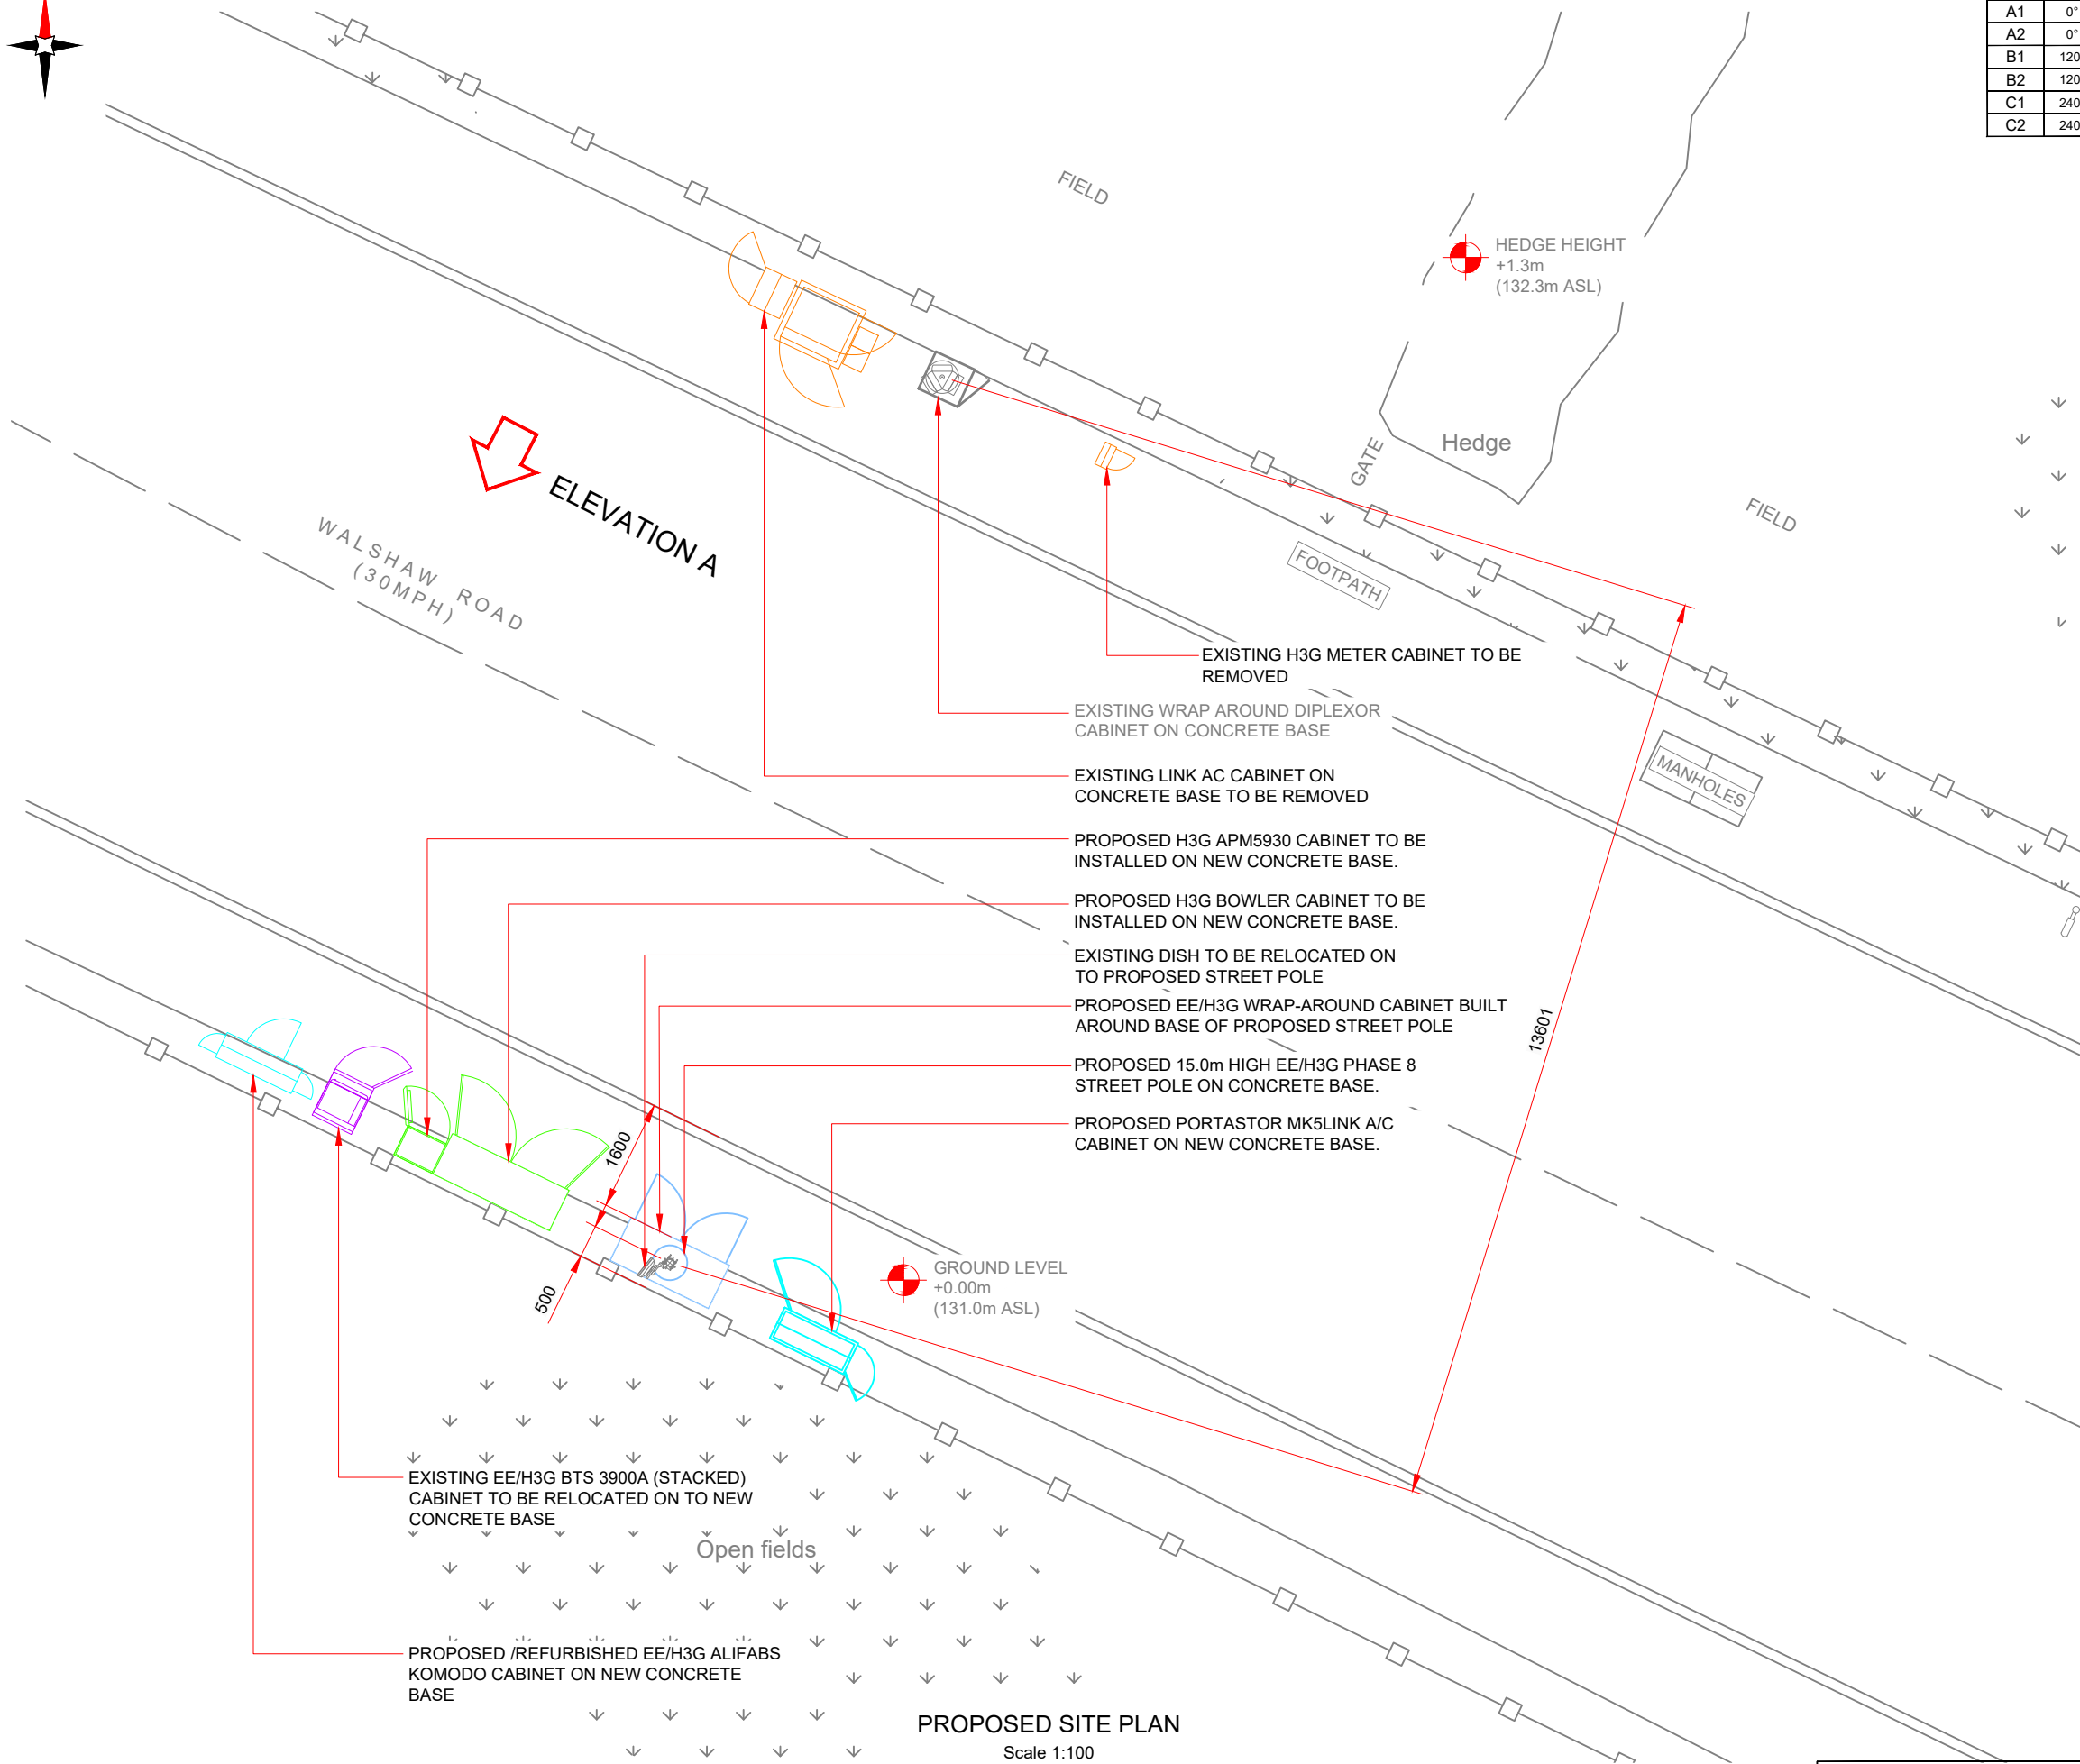

Antenna Aperture ID	Proposed 4G/5G Bearing	Operator Shared/EE/H3G
A1	0°	H3G
A2	0°	EE/H3G
B1	120°	H3G
B2	120°	EE/H3G
C1	240°	H3G
C2	240°	EE/H3G

NOTES:

1. ALL DIMENSIONS IN MM UNLESS OTHERWISE NOTED.

<u>MAX CONFIGURATION SITE</u>	
RF MAX CONFIG	1.0

Master:	MBNL / EE / H3G:	Project:	Purpose of Issue:	Issue:
M004	MBNL	H3G UNILATERAL SW	Planning	D
Date:	27/08/2020	Revision / Upgrade Description:		
Drawn:	C.D.N	Client comments		
Checked:	AF			
Approved:	BS			
Master:	MBNL / EE / H3G:	Project:	Purpose of Issue:	Issue:
M003	MBNL	H3G UNILATERAL SW	Planning	C
Date:	21/08/2020	Revision / Upgrade Description:		
Drawn:	C.D.N	Client comments		
Checked:	AF			
Approved:	BS			
Master:	MBNL / EE / H3G:	Project:	Purpose of Issue:	Issue:
M002	MBNL	H3G UNILATERAL SW	Planning	B
Date:	25/06/2020	Revision / Upgrade Description:		
Drawn:	C.D.N	Site relocated		
Checked:	AF			
Approved:	BS			
Master:	MBNL / EE / H3G:	Project:	Purpose of Issue:	Issue:
M001	MBNL	H3G UNILATERAL SW	Planning	A
Date:	20/06/2020	Revision / Upgrade Description:		
Drawn:	C.D.N	First Issue		
Checked:	AF			
Approved:	BS			



Hutchison 3G UK Limited
Star House, 20 Grenfell Road
Maidenhead, SL6 1EH
Tel: 01628 765 000
Fax: 01628 765 001

H3G Base Station Information line:
0845 6043000
Available 8am-8pm Monday to Friday



Hatfield Business Park
Hatfield
Hertfordshire
AL10 9BW

Tel: 01707 315000
Fax: 01707 319001



Mobile Broadband Network Limited
Sixth Floor, Thames Tower, Station Road, Reading, RG1 1LX

Design Consultant & Principal Contractor:



WHP Telecoms
Unit 1 Maple Park,
Low Fields Avenue, Leeds
LS12 6HH

Tel: 01133023550
e-mail: info@whptelecoms.com

Site Name: WALSHAW ROAD

Site ID: 786142

Address:

WALSHAW ROAD,
BURY GREATER,
MANCHESTER,
BL8 3AF

Title: 215 PROPOSED MAX CONFIGURATION SITE PLAN
--

Project:	H3G UNILATERAL SW
----------	-------------------


Purpose of Issue:	PLANNING
-------------------	----------

EE Cell ID: 76007	MBNL Cell ID: BRY020	3UK Cell ID: BL0121
-----------------------------	--------------------------------	-------------------------------

Master Drawing No: 786142 BRY020 76007 BL0121 M004

Issue:	D
--------	---

Passive Infrastructure Equipment Capacity & Lead Operator			
A	B	C	LEAD
HS2	HS2	HS2	H3G

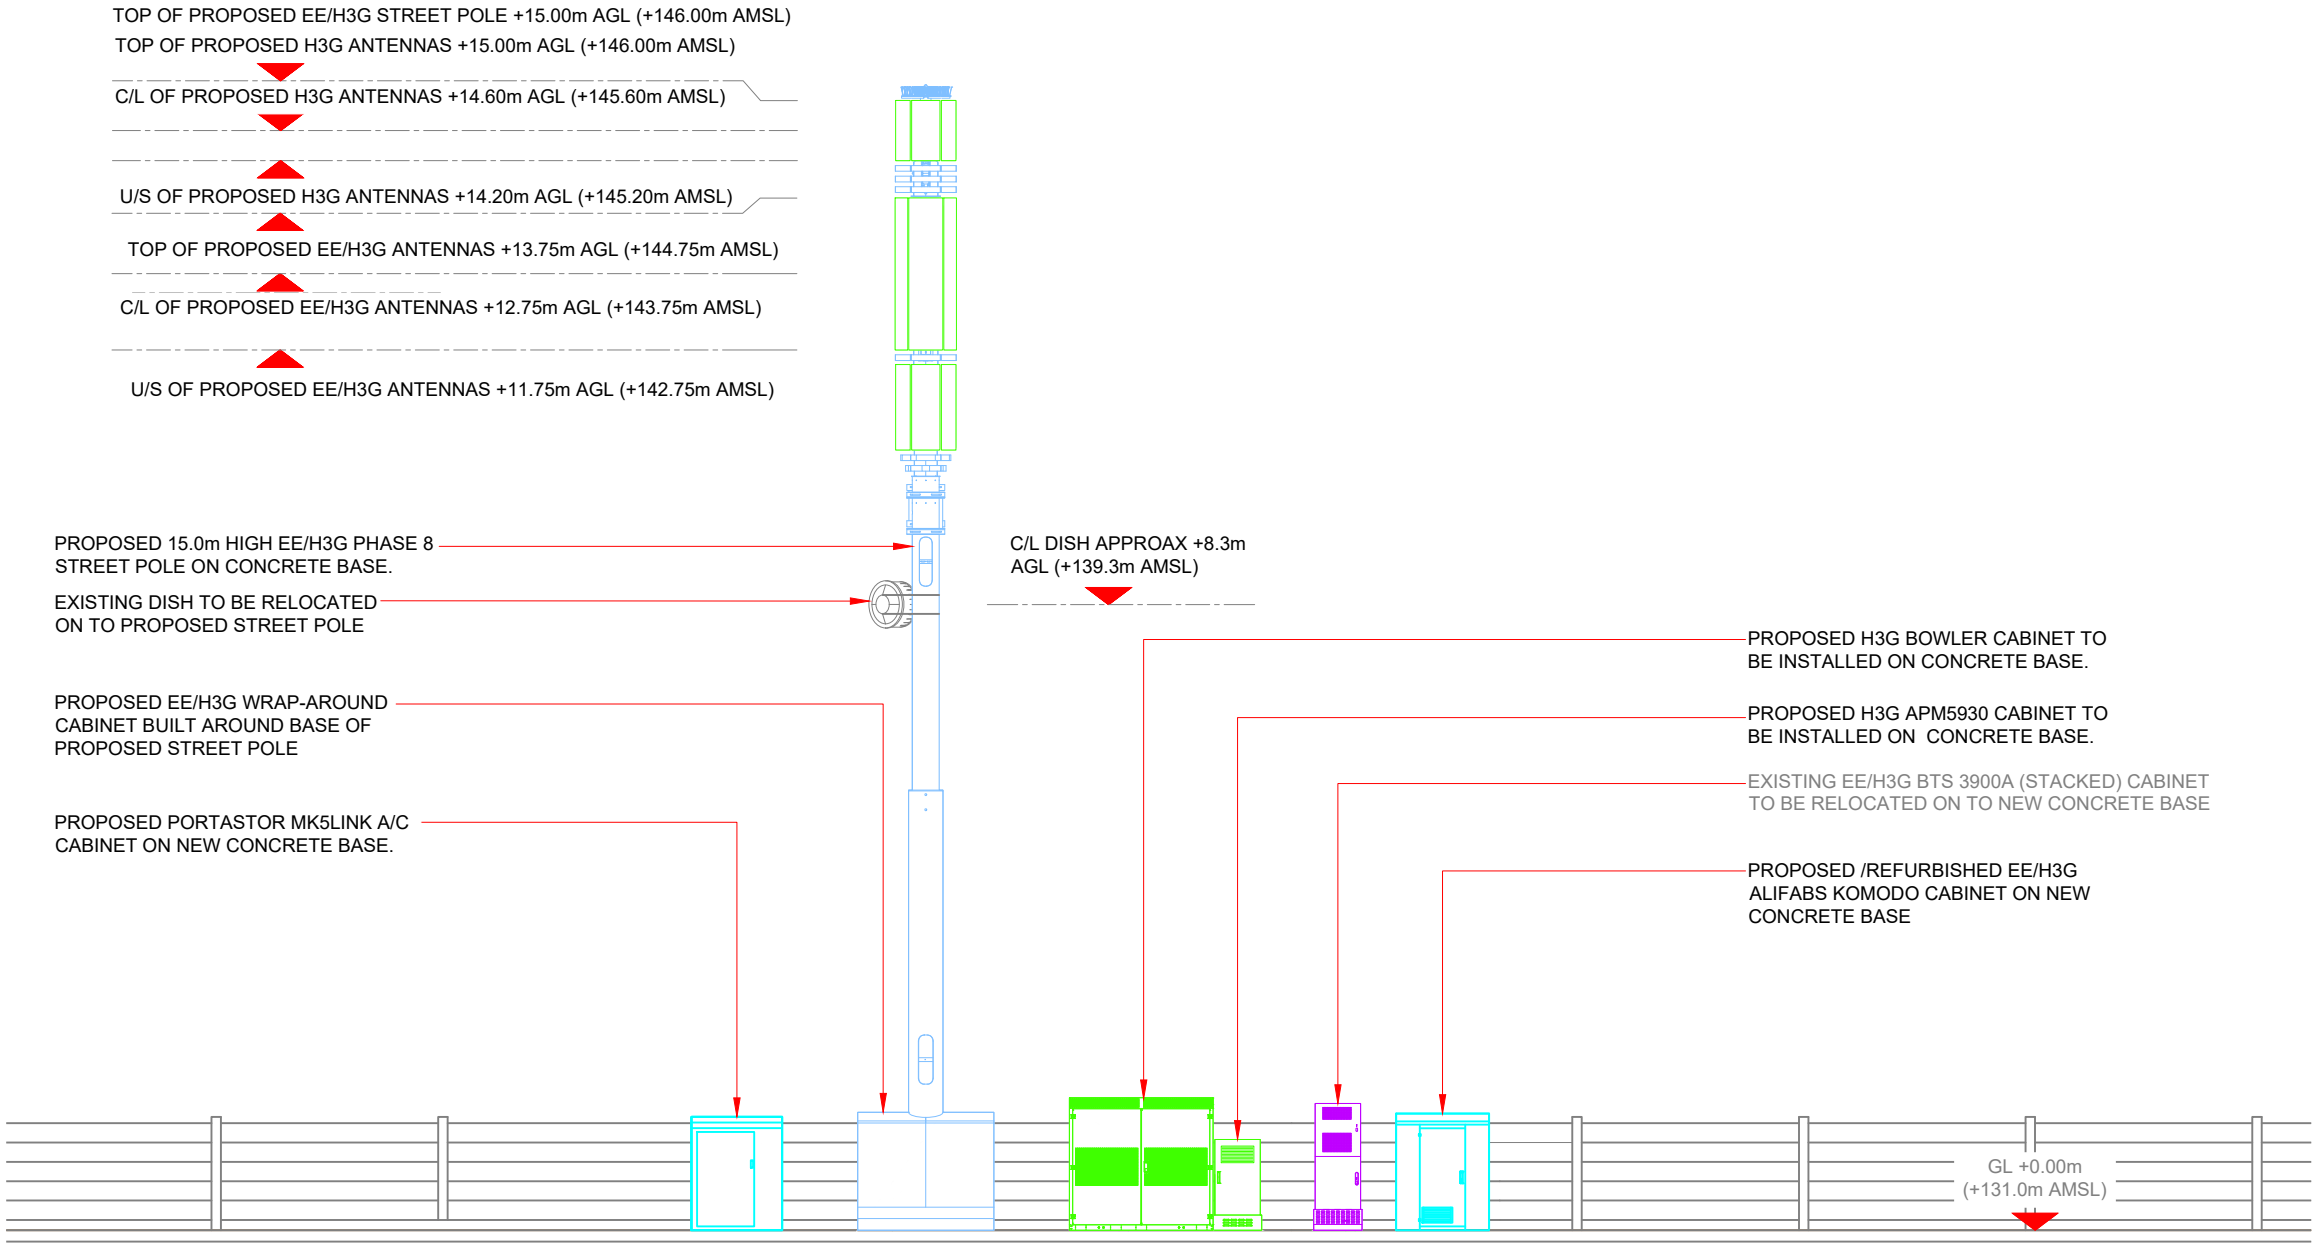

Antenna Aperture ID	Proposed 4G/5G Bearing	Operator: Shared/ EE/H3G
A1	0°	H3G
A2	0°	EE/H3G
B1	120°	H3G
B2	120°	EE/H3G
C1	240°	H3G
C2	240°	EE/H3G

NOTES:

1. ALL DIMENSIONS IN MM UNLESS OTHERWISE NOTED.

MAX CONFIGURATION SITE

RF MAX CONFIG 1.0

Master:	MBNL / EE / H3G:	Project:	Purpose of Issue:	Issue:
M004	MBNL	H3G UNILATERAL SW	Planning	D
Date:	27/08/2020	Revision / Upgrade Description:		
Drawn:	C.D.N	Client comments		
Checked:	AF			
Approved:	BS			
Master:	MBNL / EE / H3G:	Project:	Purpose of Issue:	Issue:
M003	MBNL	H3G UNILATERAL SW	Planning	C
Date:	21/08/2020	Revision / Upgrade Description:		
Drawn:	C.D.N	Client comments		
Checked:	AF			
Approved:	BS			
Master:	MBNL / EE / H3G:	Project:	Purpose of Issue:	Issue:
M002	MBNL	H3G UNILATERAL SW	Planning	B
Date:	25/06/2020	Revision / Upgrade Description:		
Drawn:	C.D.N	Site relocated		
Checked:	AF			
Approved:	BS			
Master:	MBNL / EE / H3G:	Project:	Purpose of Issue:	Issue:
M001	MBNL	H3G UNILATERAL SW	Planning	A
Date:	20/06/2020	Revision / Upgrade Description:		
Drawn:	C.D.N	First Issue		
Checked:	AF			
Approved:	BS			



Hutchison 3G UK Limited
Star House, 20 Grenfell Road
Maidenhead, SL6 1EH
Tel: 01628 765 000
Fax: 01628 765 001
H3G Base Station Information line:
0845 6043000
Available 8am-8pm Monday to Friday



Hatfield Business Park
Hatfield
Hertfordshire
AL10 9BW
Tel: 01707 315000
Fax: 01707 319001



Mobile Broadband Network Limited
Sixth Floor, Thames Tower, Station Road, Reading, RG1 1LX

Design Consultant & Principal Contractor:



WHP Telecoms
Unit 1 Maple Park,
Low Fields Avenue, Leeds
LS12 6HH

Tel: 01133023550
e-mail: info@whptelecoms.com

Site Name:
WALSHAW ROAD

Site ID:
786142

Address:
WALSHAW ROAD,
BURY GREATER,
MANCHESTER,
BL8 3AF

Title: 265 PROPOSED MAX CONFIGURATION
ELEVATION

Project:
H3G UNILATERAL SW

Purpose of Issue:
PLANNING

EE Cell ID: 76007	MBNL Cell ID: BRY020	3UK Cell ID: BL0121
----------------------	-------------------------	------------------------

Master Drawing No: 786142_BRY020_76007_BL0121_M004	Issue: D
---	-------------

Passive Infrastructure Equipment Capacity & Lead Operator			
A	B	C	LEAD
HS2	HS2	HS2	H3G