


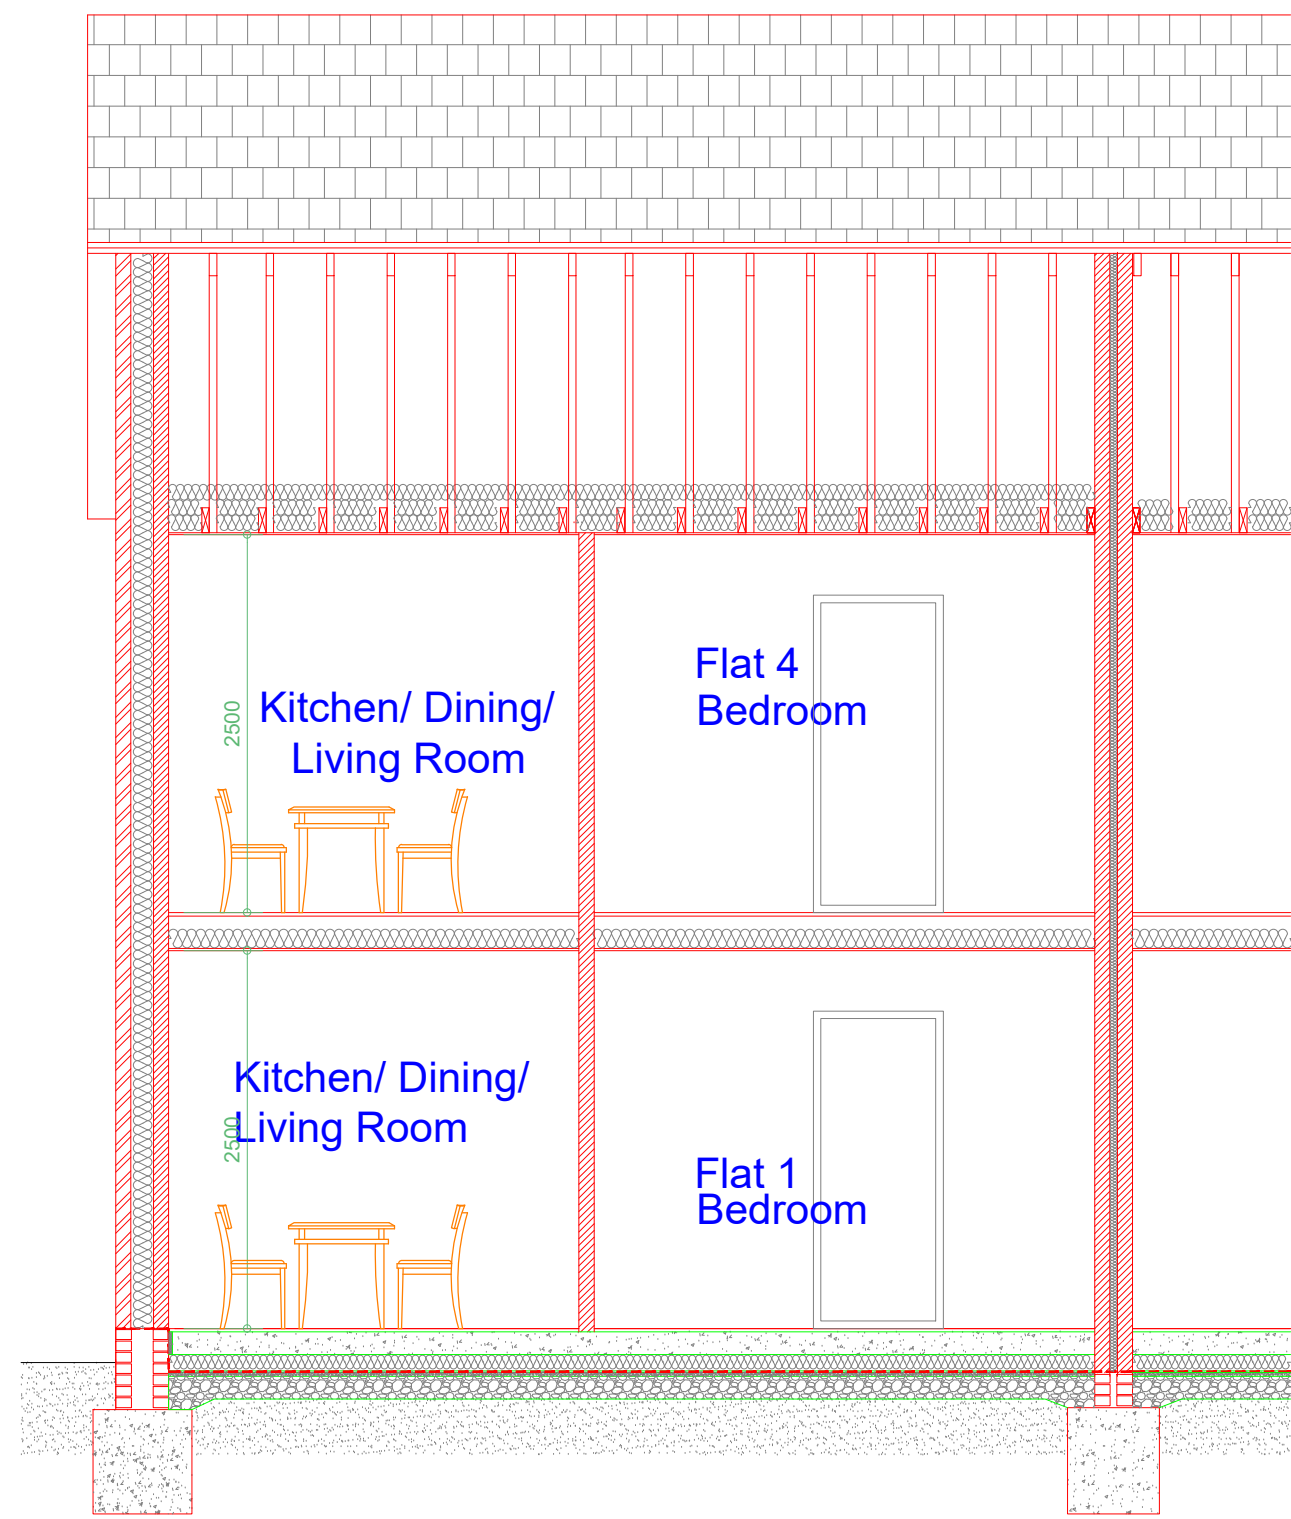

Section A-A
Scale 1:50

ALL ELEMENTS OF CONSTRUCTION TO BE OF MINIMUM 1/2 hr. FIRE RESISTANCE


Cross flow ventilation provided to roof rafter space via proprietary eaves strip (continuous and dry ridge (5mm) ventilation systems levels at least to a min 25mm continuous wide strip

ELECTRICITY service into existing buildings., care must be taken when any excavation is taking place near these positions. Confirm position of electricity cables with UK Power Networks (plans@ukpowernetworks.co.uk) before commencing on site, position of service cable to be marked on site, and also on copy of plans.

WATER supply to be located & isolated prior to removal of any pipework, water supply pipe to be adequately protected from accidental / wilful damage at all times, contact United Utilities 0845 746 2200

GAS service into existing buildings., care must be taken when any excavation is taking place near these positions. Confirm position of gas supply pipe with Transco 01204 - 546900, before commencing on site, position of service pipe to be marked on site, and also on copy of plans, once position of pipe has been established. IN AN EMERGENCY CALL 0800 111999 IMMEDIATELY

Internal drainage shall be to BS 5572 : 1978 and BS5414 all internal drainage to be by 'Bartol' or similar approved UPVC high temperature waste system, 100, 032 & 040mm as necessary (minimum trap sizes & seal depths) IE : depth of seal 075mm depth of seal 075mm

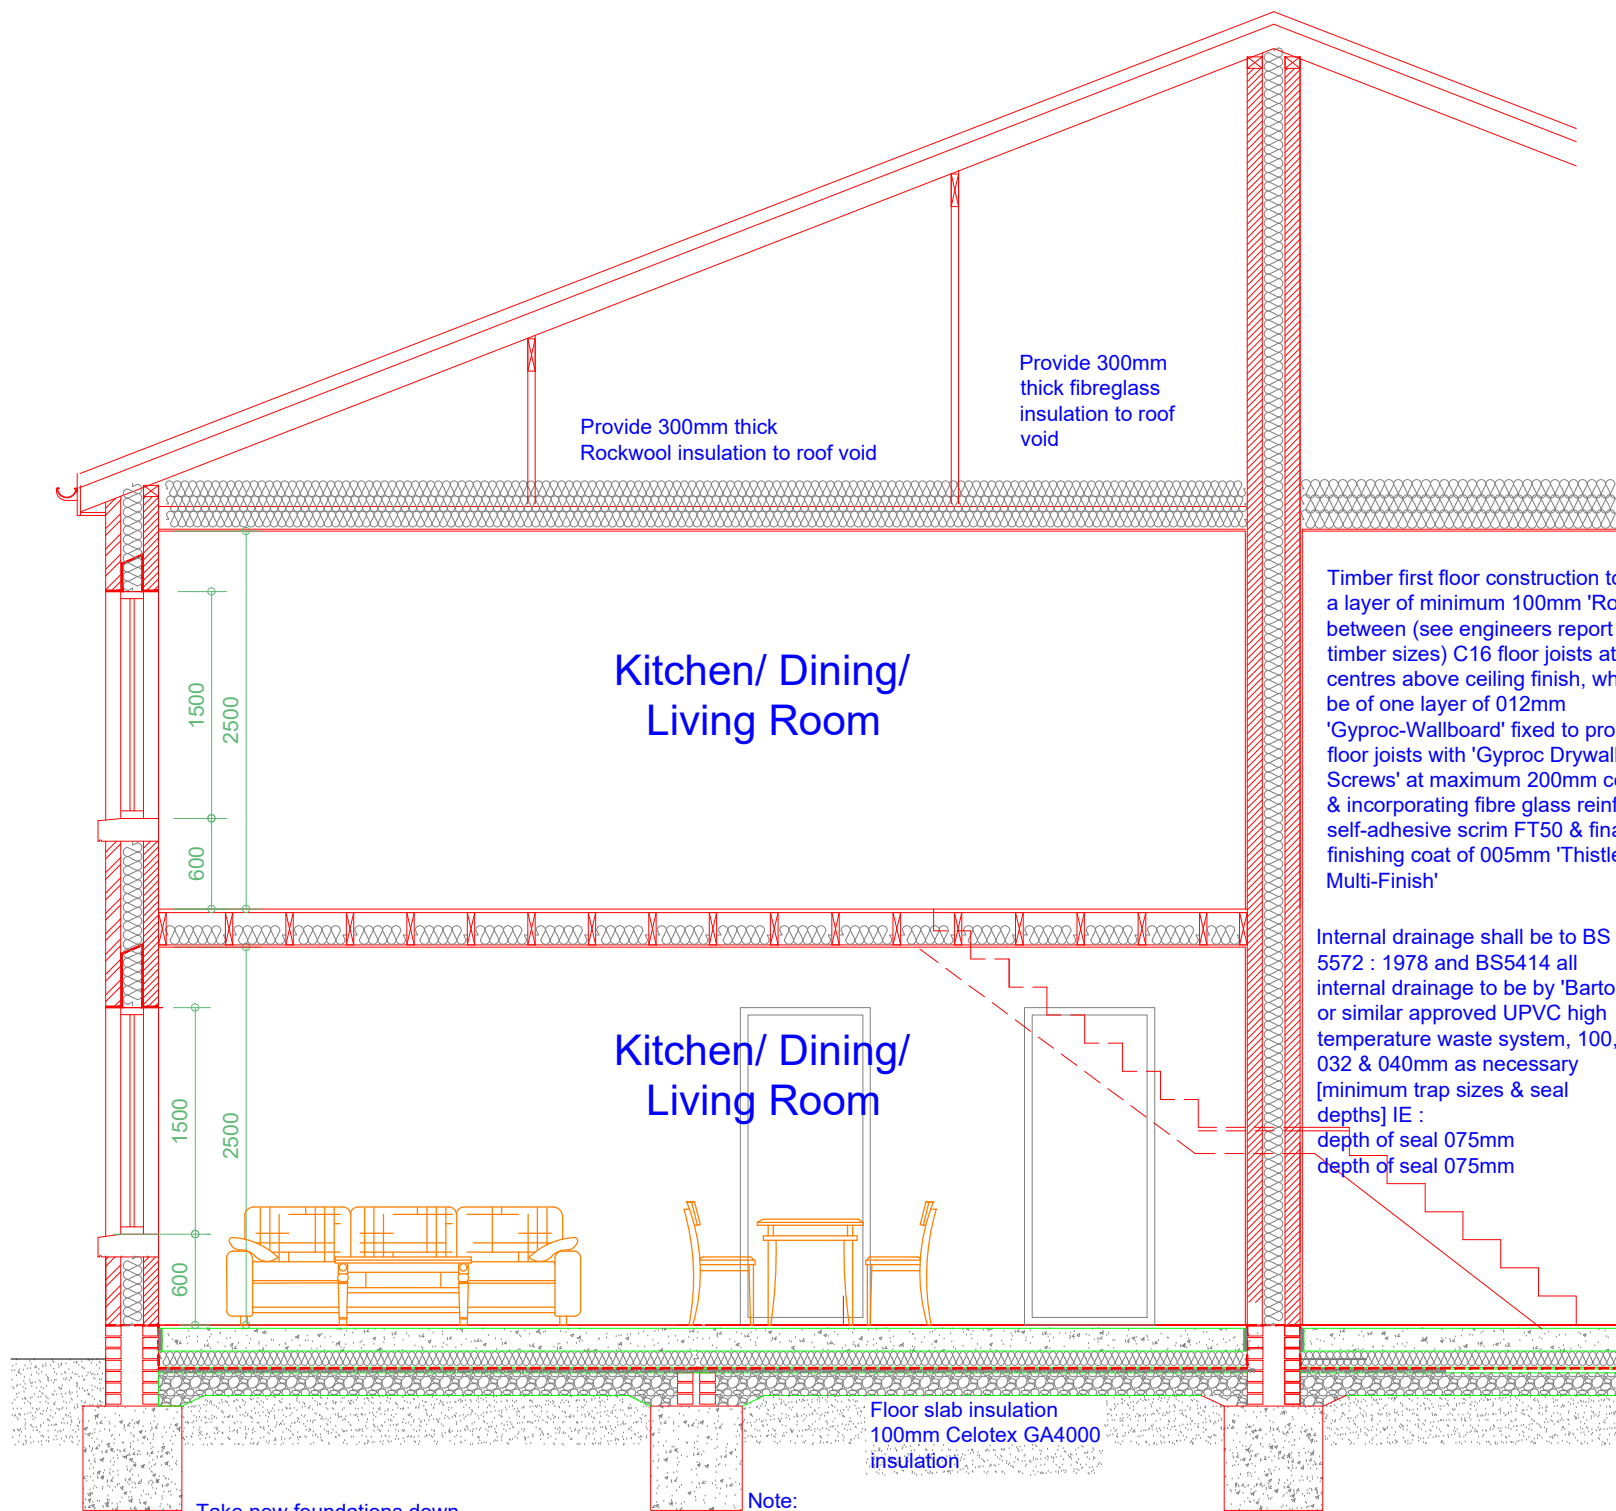

Section B-B
Scale 1:50

All windows to have operable casements equal to min. 1/20th floor area of room and to be fully weatherstripped all non-habitable rooms IE bathrooms, kitchen, utility, etc


Kingspan Thermabate Cavity Wall Closers (or equivalent) will be used.

Eaves ventilation to be type FV100 by 'Glidevale' to 10,000mm² / i.in. metre free air space

Lateral restraint provided to bottom truss chords parallel to external wall to be of 030x005mm MS straps, carried over min. 3 no. chords [with 050x100mm noggins under] at 2000mm centres.

Internal drainage shall be to BS 5572 : 1978 and BS5414 all internal drainage to be by 'Bartol' or similar approved UPVC high temperature waste system, 100, 032 & 040mm as necessary (minimum trap sizes & seal depths) IE : depth of seal 075mm depth of seal 075mm

NOTE, Positions of proposed drainage runs and types of drainage indicated on drawings are provisional only, and may be altered to suit site conditions. Contractor to check invert & position of existing drainage systems to ensure adequate fall & to ensure BCO is satisfied with proposed drainage layout, fall and site inverts before excavation of drainage runs

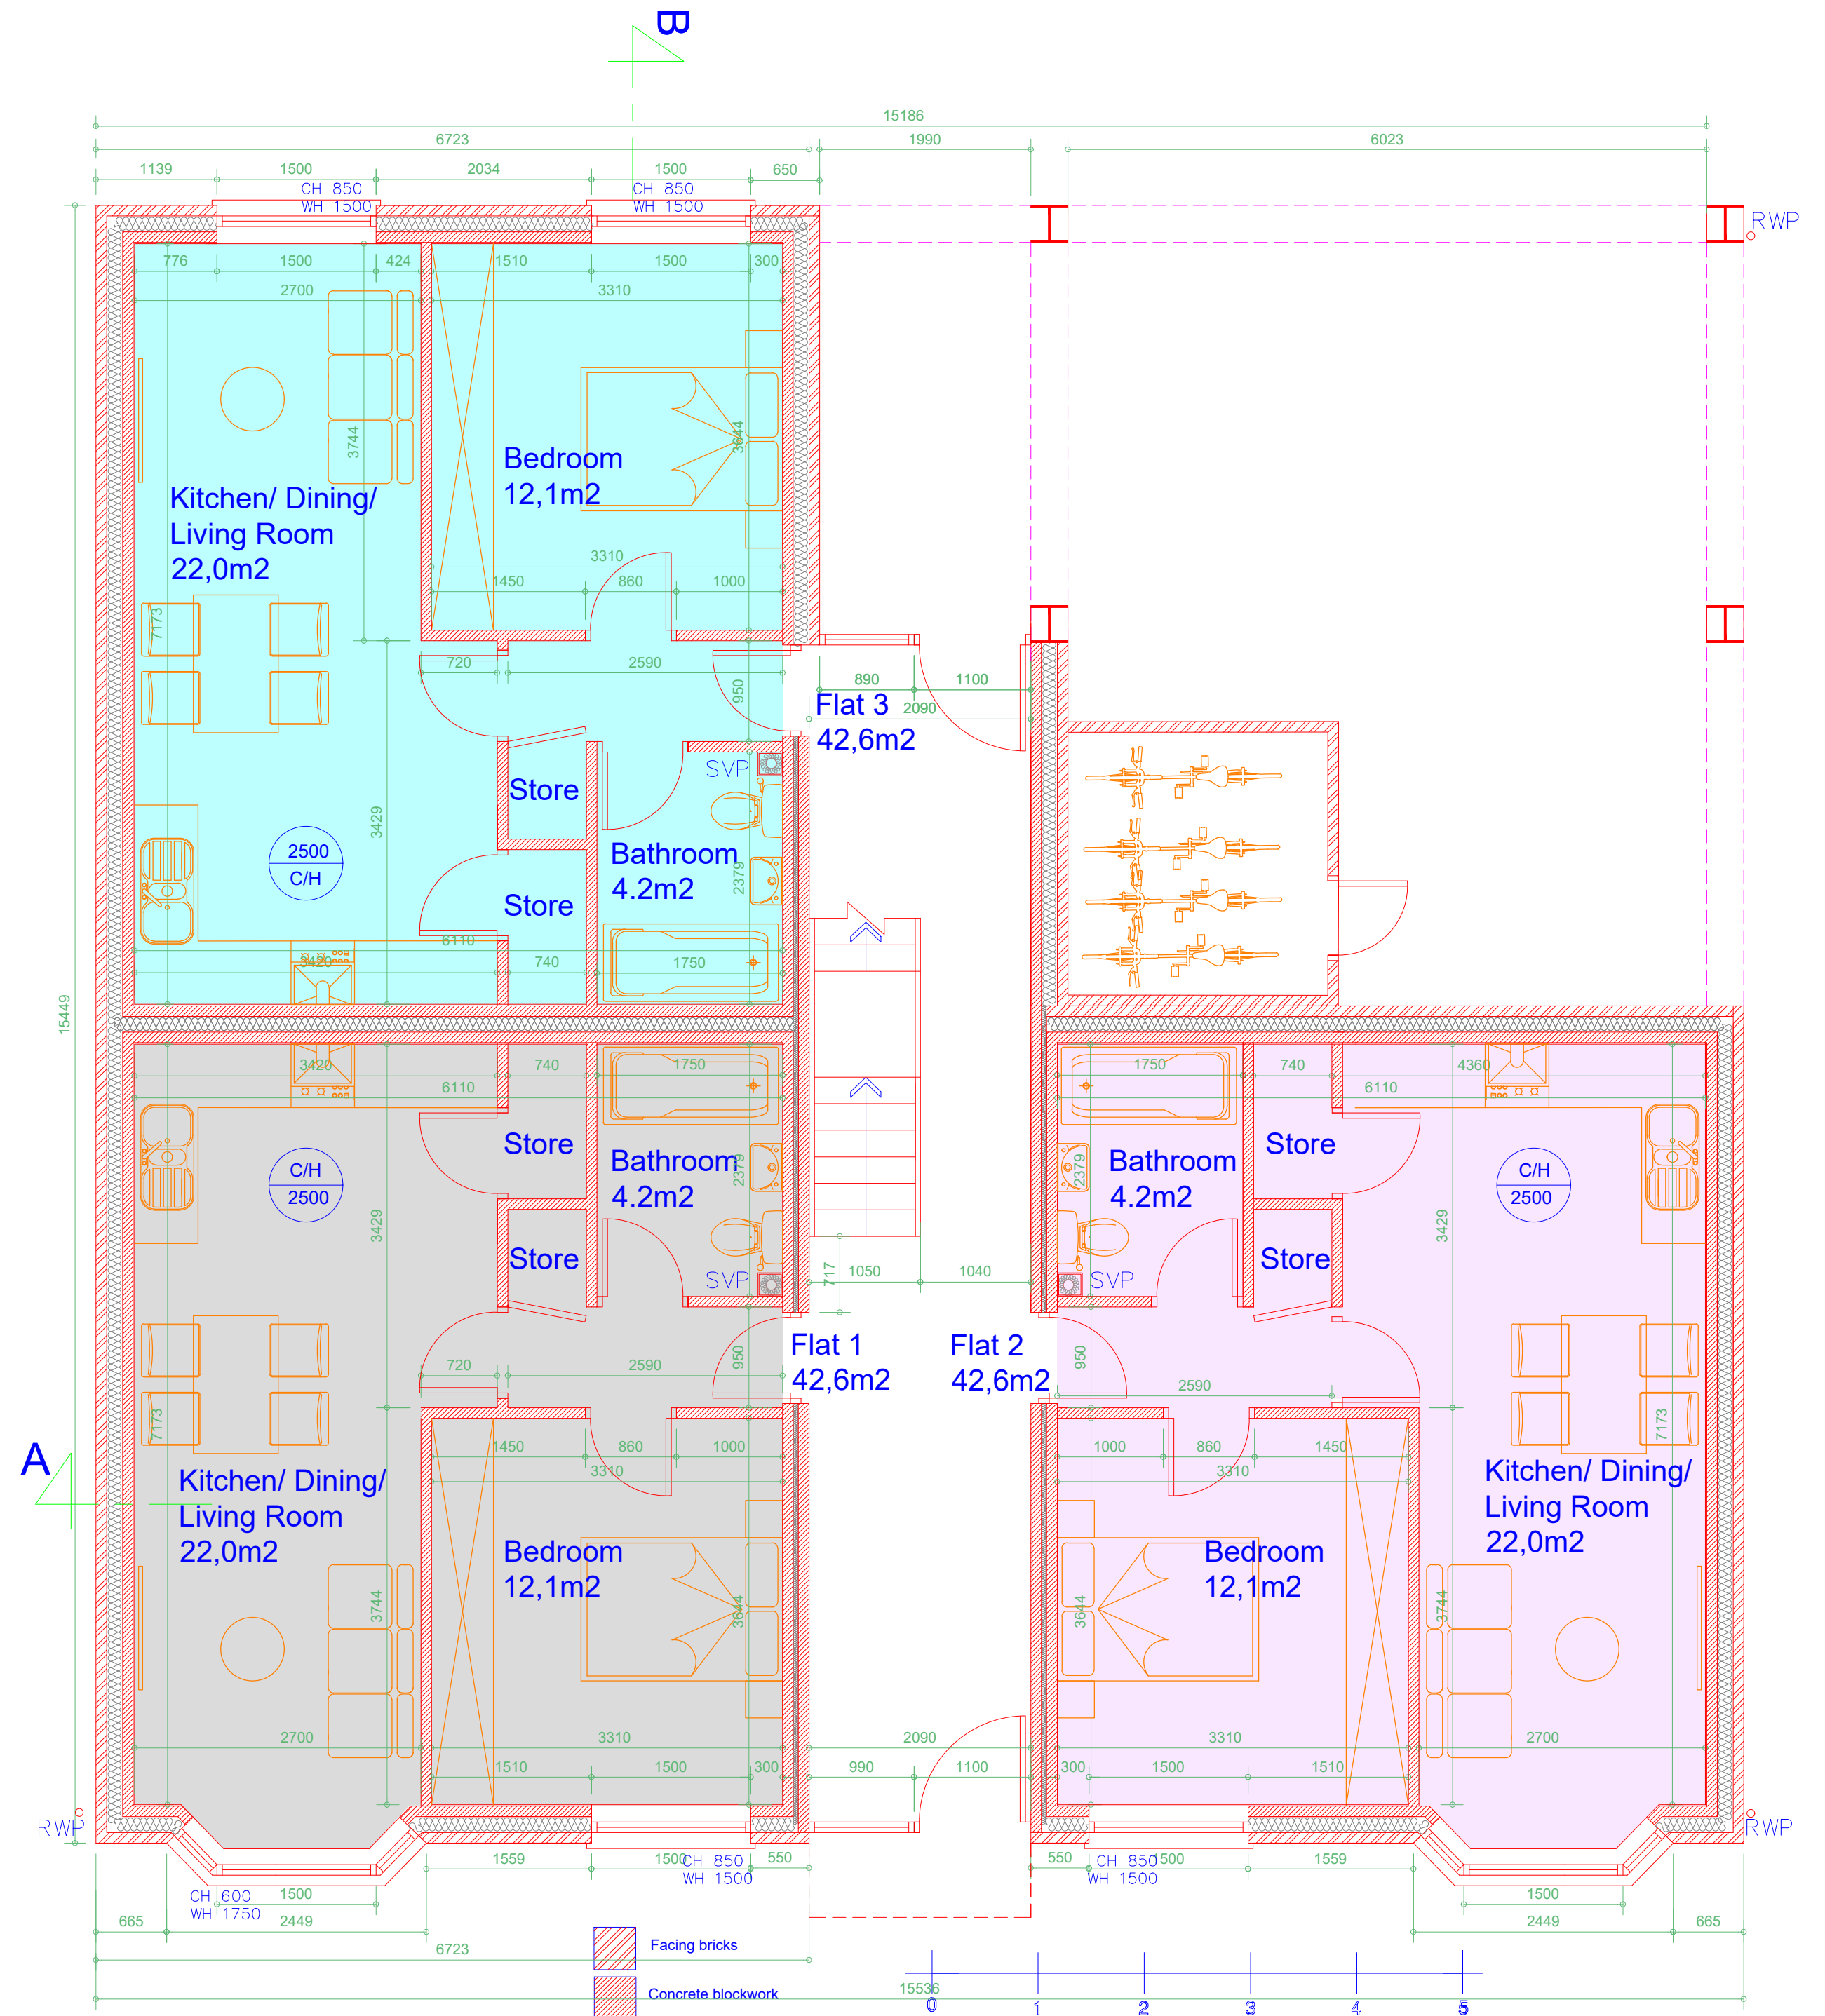

Ground Floor Plan
Scale 1:50

Rev Date Description

Issued For : INFORMATION PURPOSES ONLY

Client

Mr. Hassen Lakhel

Project
207 to 209 Bury Old Rd, Prestwich, Bury, M25
1JFProposed new build apartments.
4 x two bedroom and 3 x one bedroom

Scheme - Drawing Title

Proposed Ground Floor Plan and Sections

01 Drawing No. Revision Date 29.11.23 Scale 1:50 @A1



Plans To Build It Ltd
Tel: 0161 728 5730
Mob: 07741175755
www.planstobuildit.com