



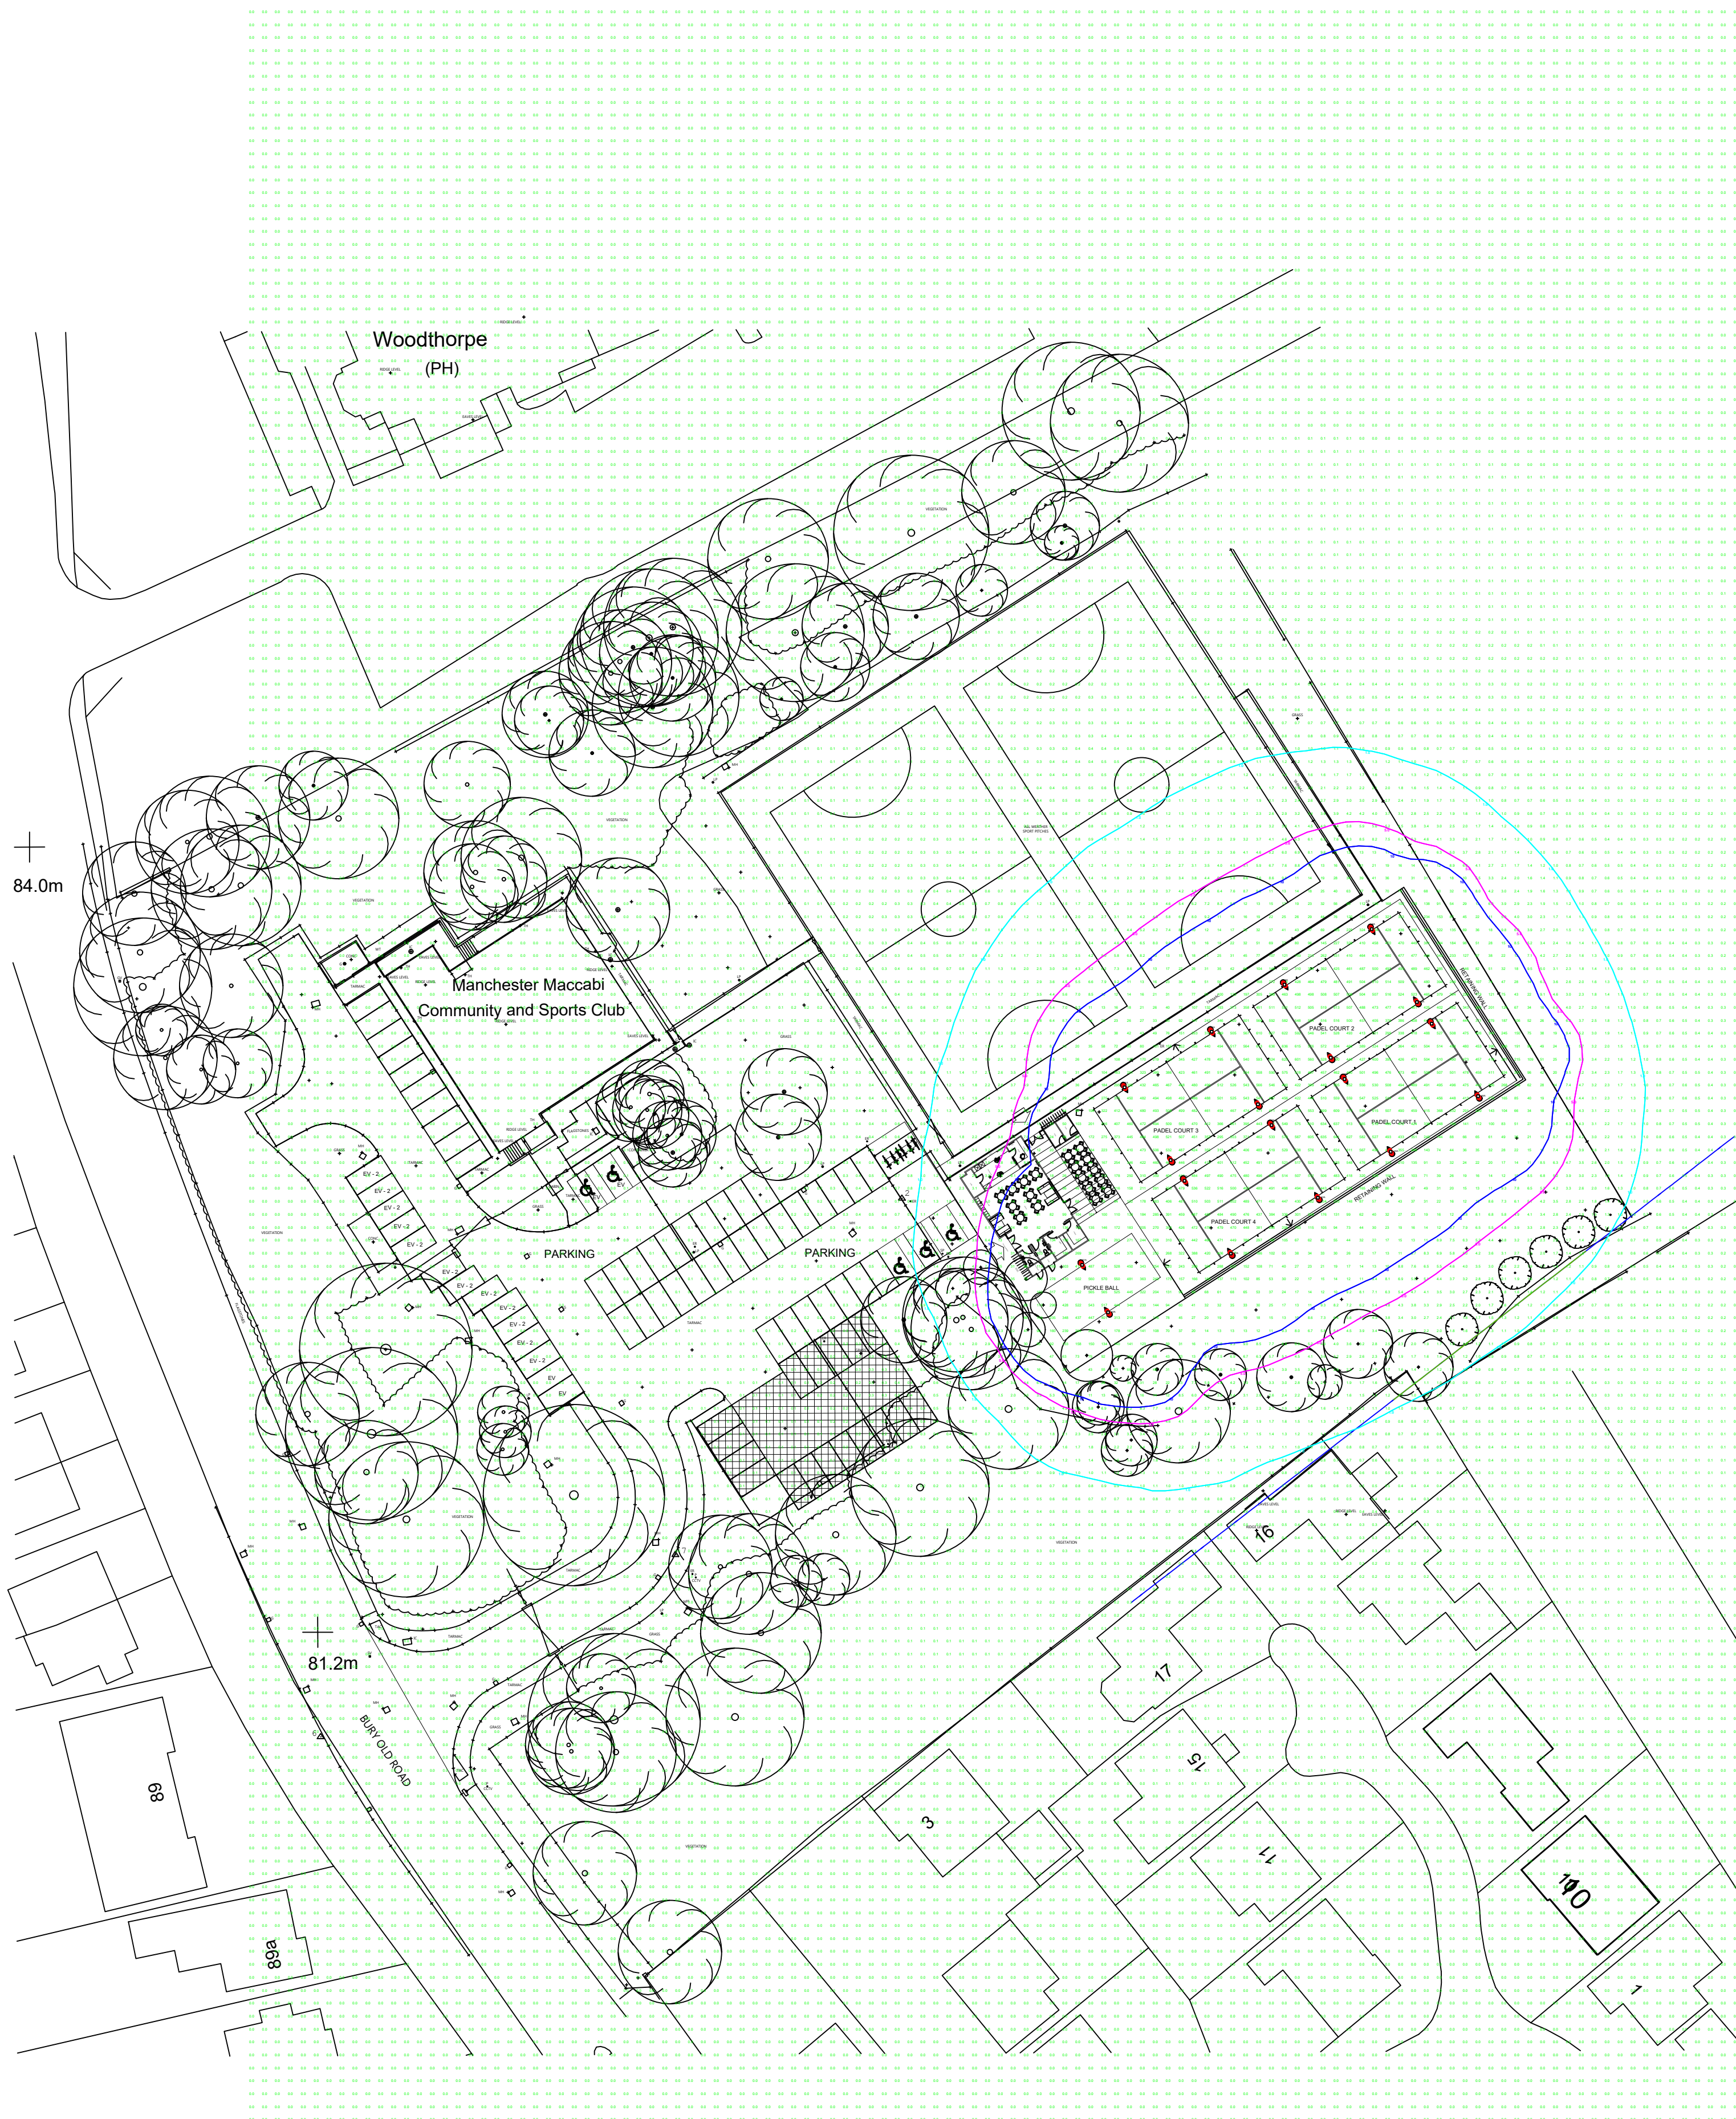


Luminaire Type:	Padel Court floodlight
Luminaire Reference:	EL-NED 240 (TC)
Mounting Type:	Post top mounted on 6m mast
Luminaire Tilt:	0°
Lumen Output:	37.20klm
Luminaire Wattage:	240w
Luminous Intensity:	G3

ISOLUX CONTOUR KEY (AT GROUND LEVEL):
1.00 Isolux contour line
5.00 Isolux contour line
10.0 Isolux contour line

LIGHT LEVEL (AT GROUND LEVEL)
Lux value

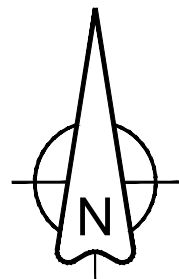

DACA Lighting LED floodlight

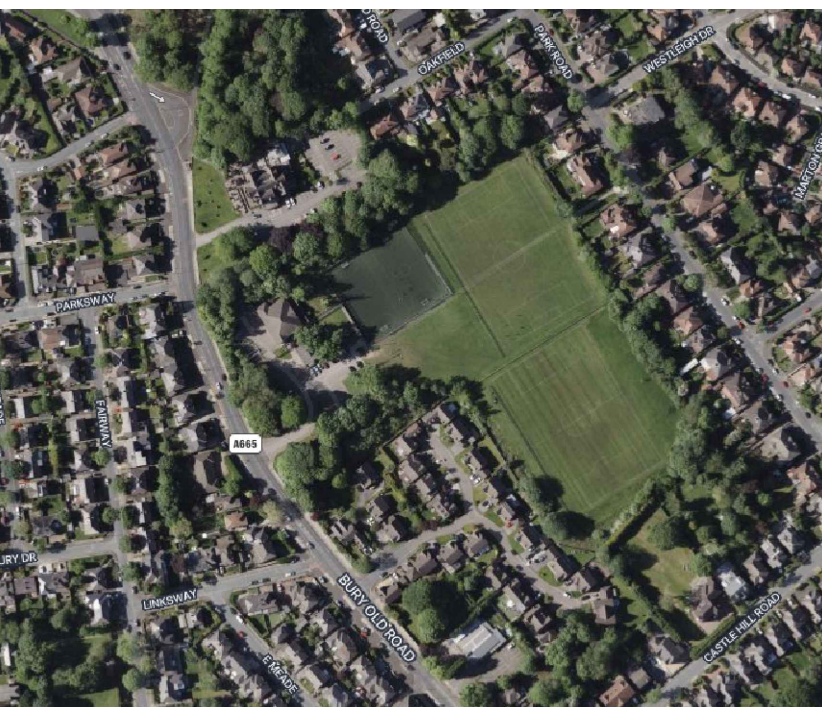

Location plan: Easting 382778 Northing 402938

The details provided on this drawing are subject to comments by all the relevant approving authorities or overseeing organisation. No construction works shall take place until technical approval has been obtained by the approving authority or overseeing organisation. It is to be understood that these drawings and the information shown are preliminary only and shall not be used for construction. Should the contractor commence work on site prior to obtaining technical approval, then it is entirely at their own risk and no liability shall be accepted by SHD Lighting Consultancy Ltd.

R1	REVISED SITE PLAN RECEIVED 06/03/2024	07/03/2024	SRH
R0	INITIAL DESIGN FOR REVIEW AND COMMENT	21/02/2024	SRH
REV	DESCRIPTION	DATE	BY

SHD

info@shdlighting.co.uk 07834 490 192 www.shdlighting.co.uk

SCHEME:	MANCHESTER MACCABI SPORTS CLUB		
DRAWING:	PADEL COURT LIGHT SPILL DESIGN		
CLIENT:	ILEX PROJECT MANAGEMENT LTD		
DRAWING NUMBER:	SHD1351-SHD-HLG-BURY-DR-ED-Lighting Layout R1	DRAWN:	SRH
	SHEET 1 OF 1	CHECKED:	SRH
CONTRACT NUMBER:	SHD1351	APPROVED:	
	DATE: 21/02/2024	REVISION:	R1
PRELIMINARY DESIGN - NOT FOR CONSTRUCTION			