


NOTES:
BEFORE THE COMMENCEMENT OF ANY
DEMOLITION AND/ OR CONSTRUCTION
WORK HEALTH AND SAFETY PLANS MUST
BE SUPPLIED BY THE MAIN CONTRACTOR
AND/OR NOMINATED SUB- CONTRACTORS
AND DEMOLITION CONSENT BE OBTAINED
FROM THE LOCAL AUTHORITY

CONSTRUCTION
LOFT PLAN
SCALE 1:20 @ A1

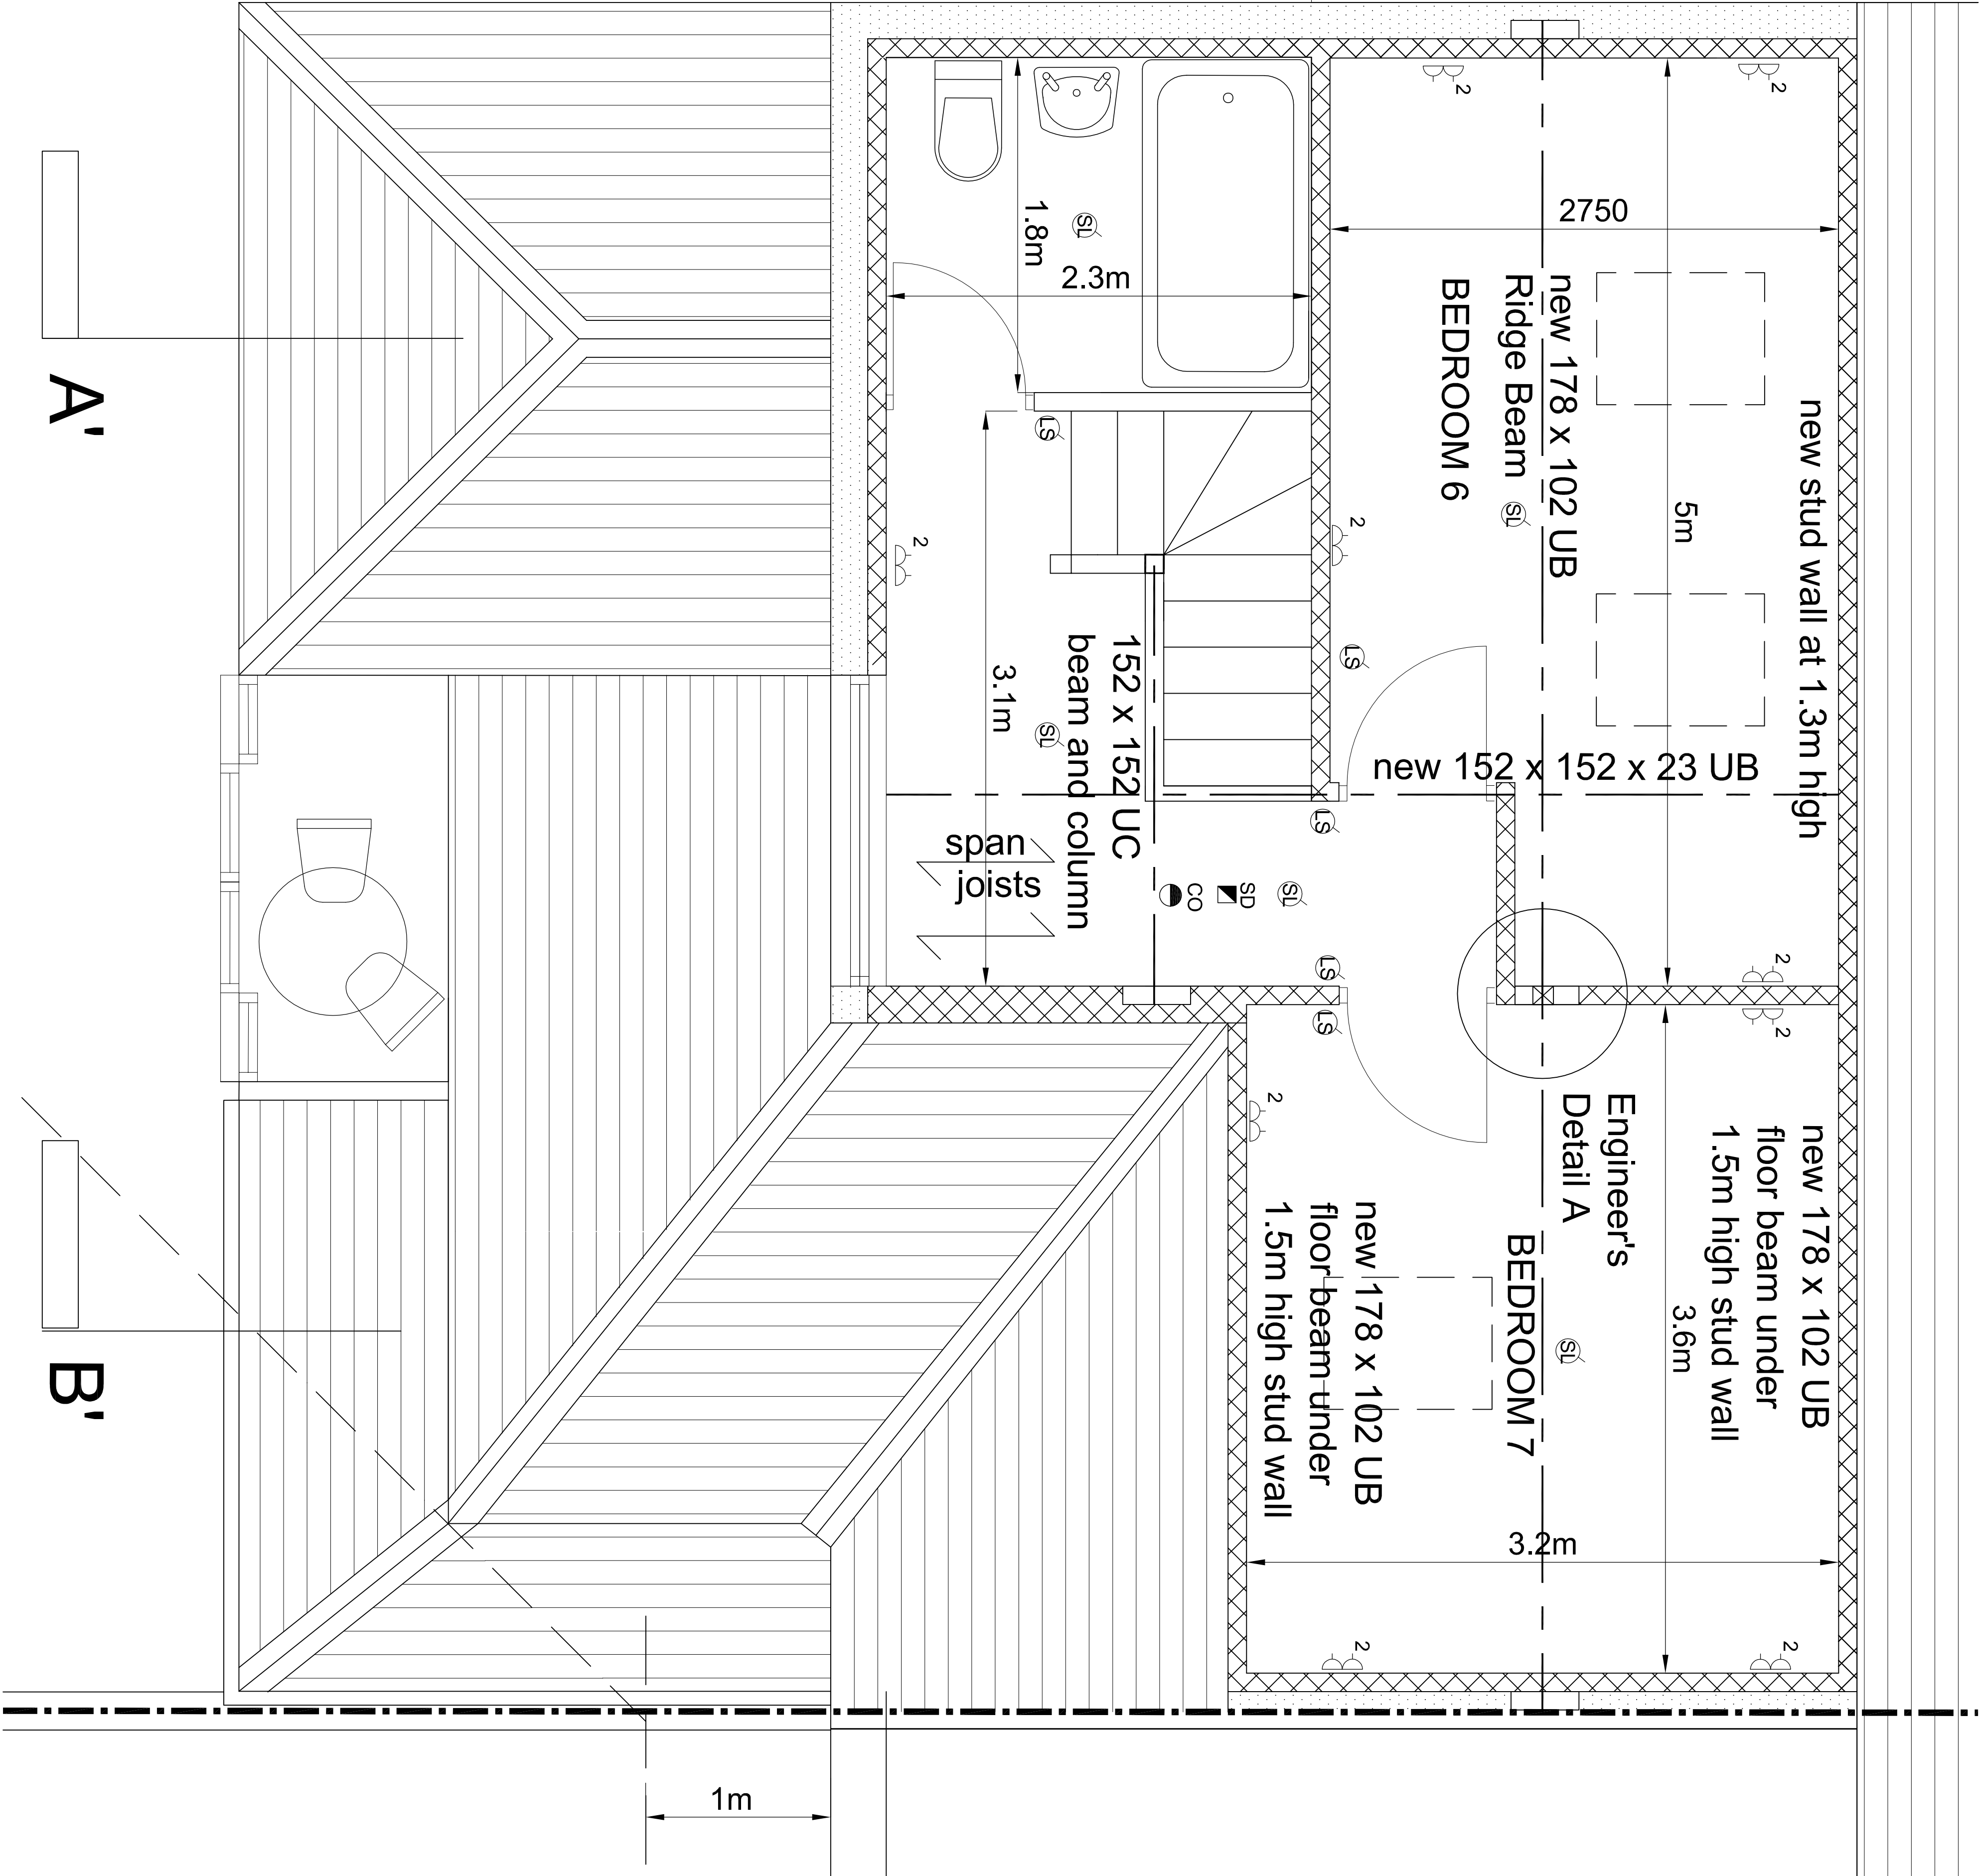

KEY TO ELECTRICAL SYMBOLS

- 6kw oven supply
- 13 amp double socket
- electrical switch over worktop with concealed socket under
- Lightswitch
- Exterior wall mounted LED movement sensor operated light
- Surface mounted LED downlight
- LED batten light under wall unit
- Shaving Point
- Wash hand basin in vanity unit with LED down lighter over back mirror operated by string pull cord
- CO2 fire extinguisher/ fire blanket mounted on wall brackets
- Thermostat
- Control Panel (for Intruder Alarm)
- Smoke Detector
- Heat Detector
- Sounder
- Carbon monoxide Detector

REV	DATE	REVISIONS
A	150821	STRUCTURAL DESIGN ADDED

BM ARCHITECTURAL DESIGNS
APARTMENT 8,
224 GREAT CLOWES STREET
MANCHESTER M7 2ZS
TEL: 07415 493002

PROJECT: PROPOSED REAR DORMER ROOF
EXTENSION AT 56 WINDSOR ROAD,
PRESTWICH, BURY M25 0DE

TITLE: PROPOSED LAYOUT- FIRST FLOOR PLAN

CLIENT: MR. RAQS SINGH AND FAMILY

SCALE: 1:20 @A1 DATE: 04/ 2021 DRAWN: BM

STATUS: BUILDING REGULATIONS

DRAWING NO.: BM0421MINDS/BR8 REV: A