


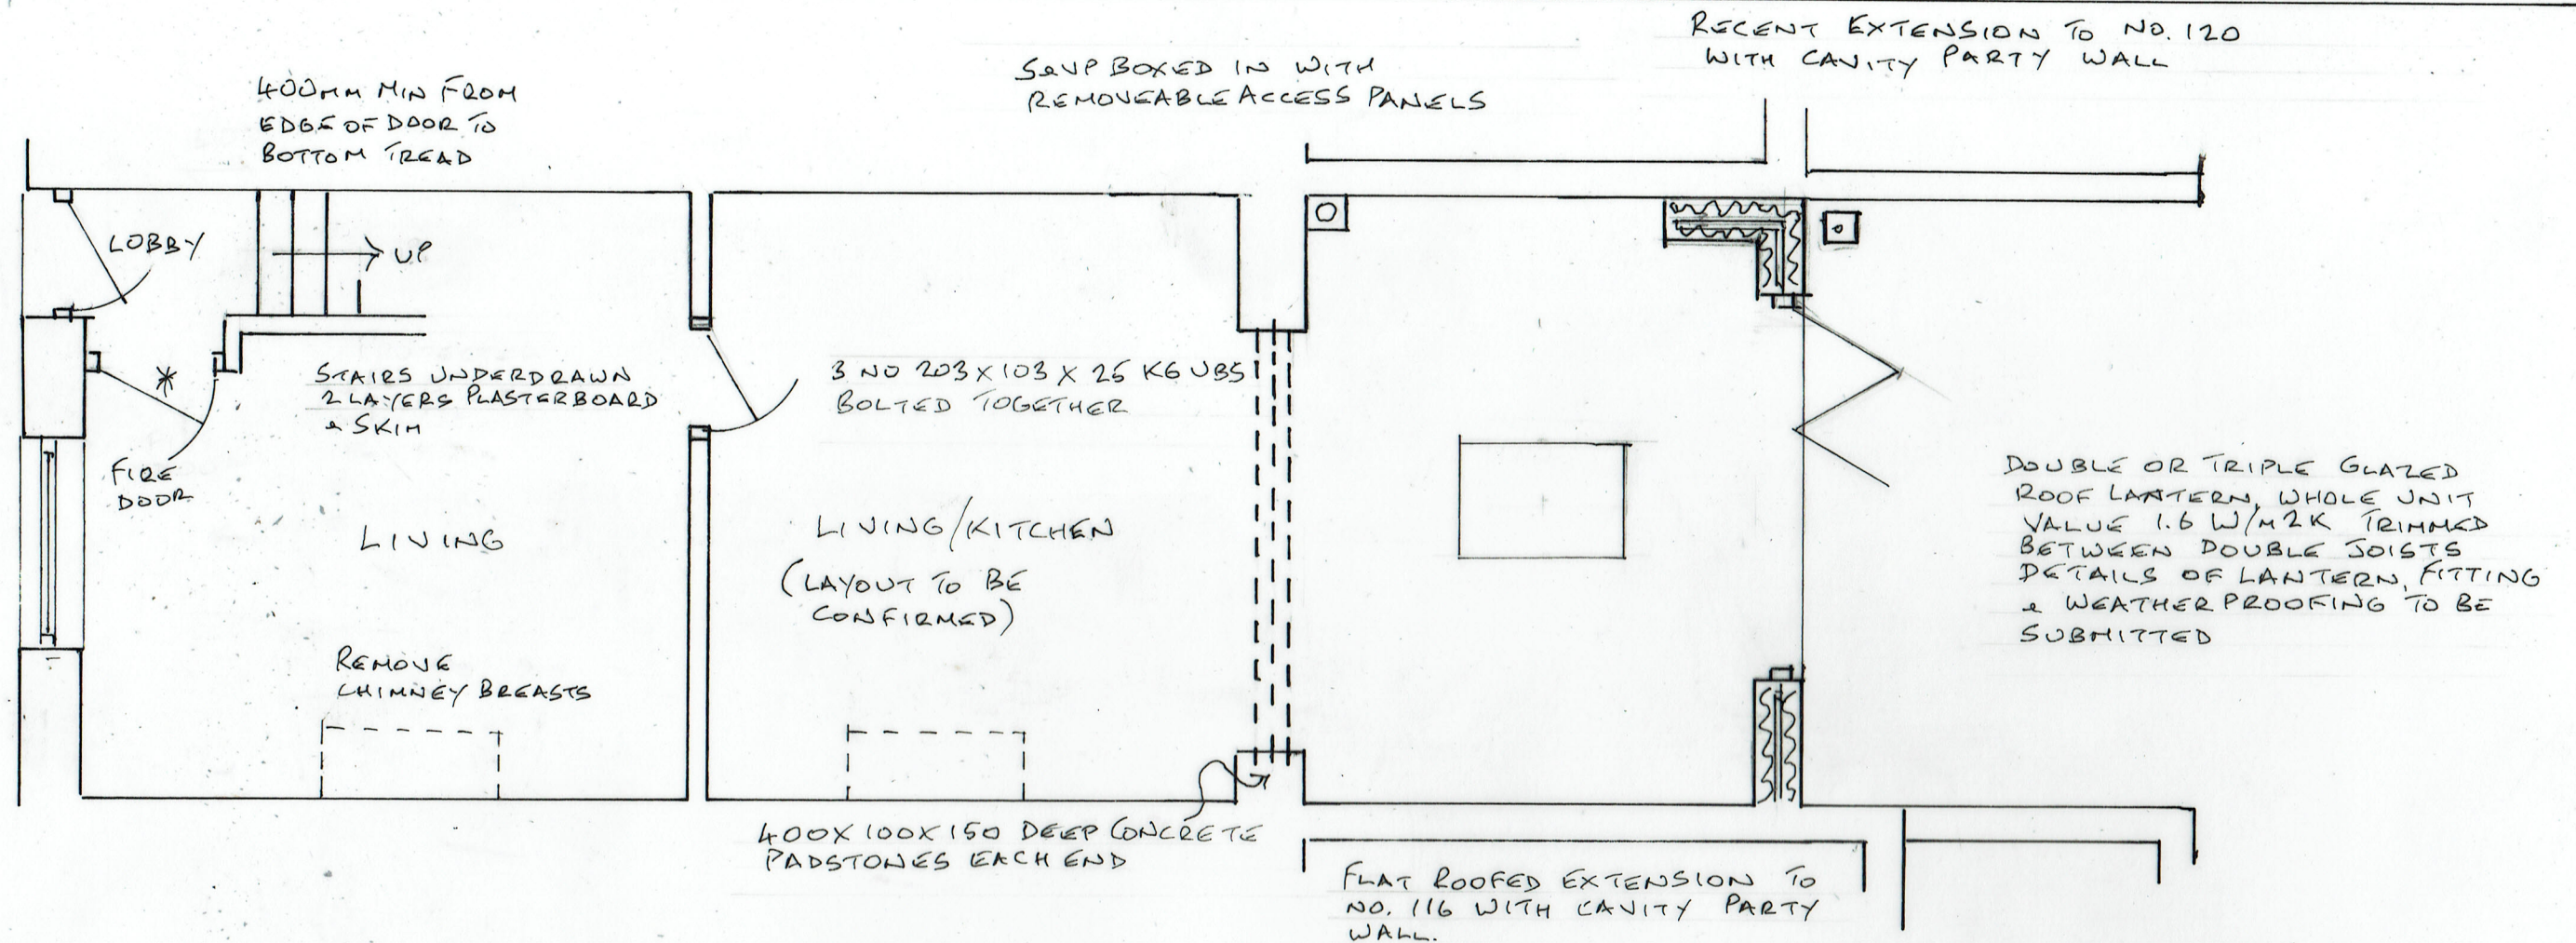

MECHANICAL VENTILATION TO KITCHEN MIN 60 LITRES/SEC SUBJECT TO EFFICIENCY TEST. 20 MINUTE OVER-RUN


38MM UPVC SINK WASTE, 75MM DEEP SEAL ANTI VAC TRAP

EXISTING C.H. SYSTEM EXTENDED. RADIATORS WITH INDEPENDENT THERMOSTATIC CONTROL & INSULATED PIPEWORK, NEW C.H. BOILER, GAS COMBI, CONDENSING MIN 86% SEDBUK RATING. FITTED BY GAS SAFE REGISTERED ENGINEER & CERTIFICATE ISSUED.


2A PROPOSED PLAN



REAR ELEVATION

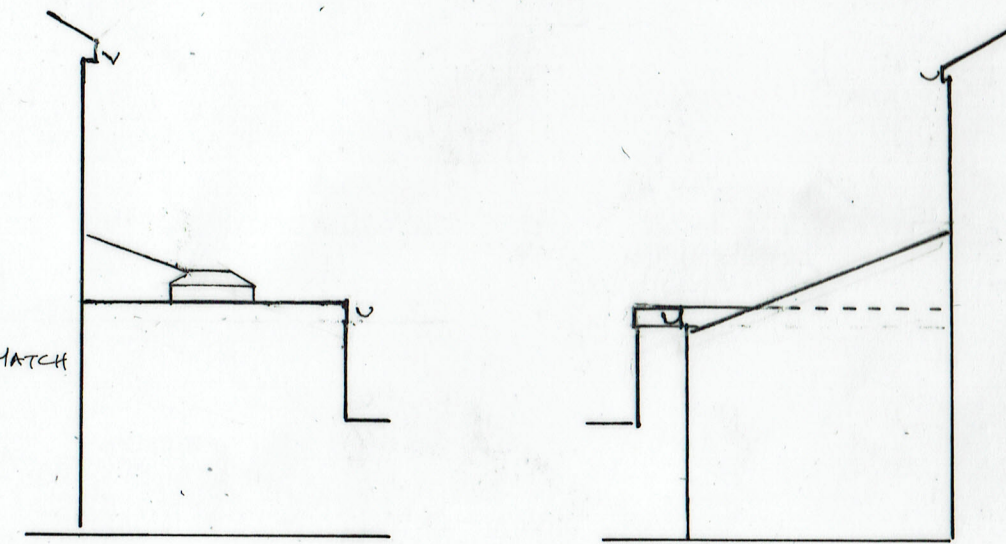

SIDE ELEVATIONS

 

SCALE 1:50 & 1:100 @ A3

SINGLE STOREY REAR EXTENSION
118 PEEL BROW, RAMSBOTTOM BLOOAU