
 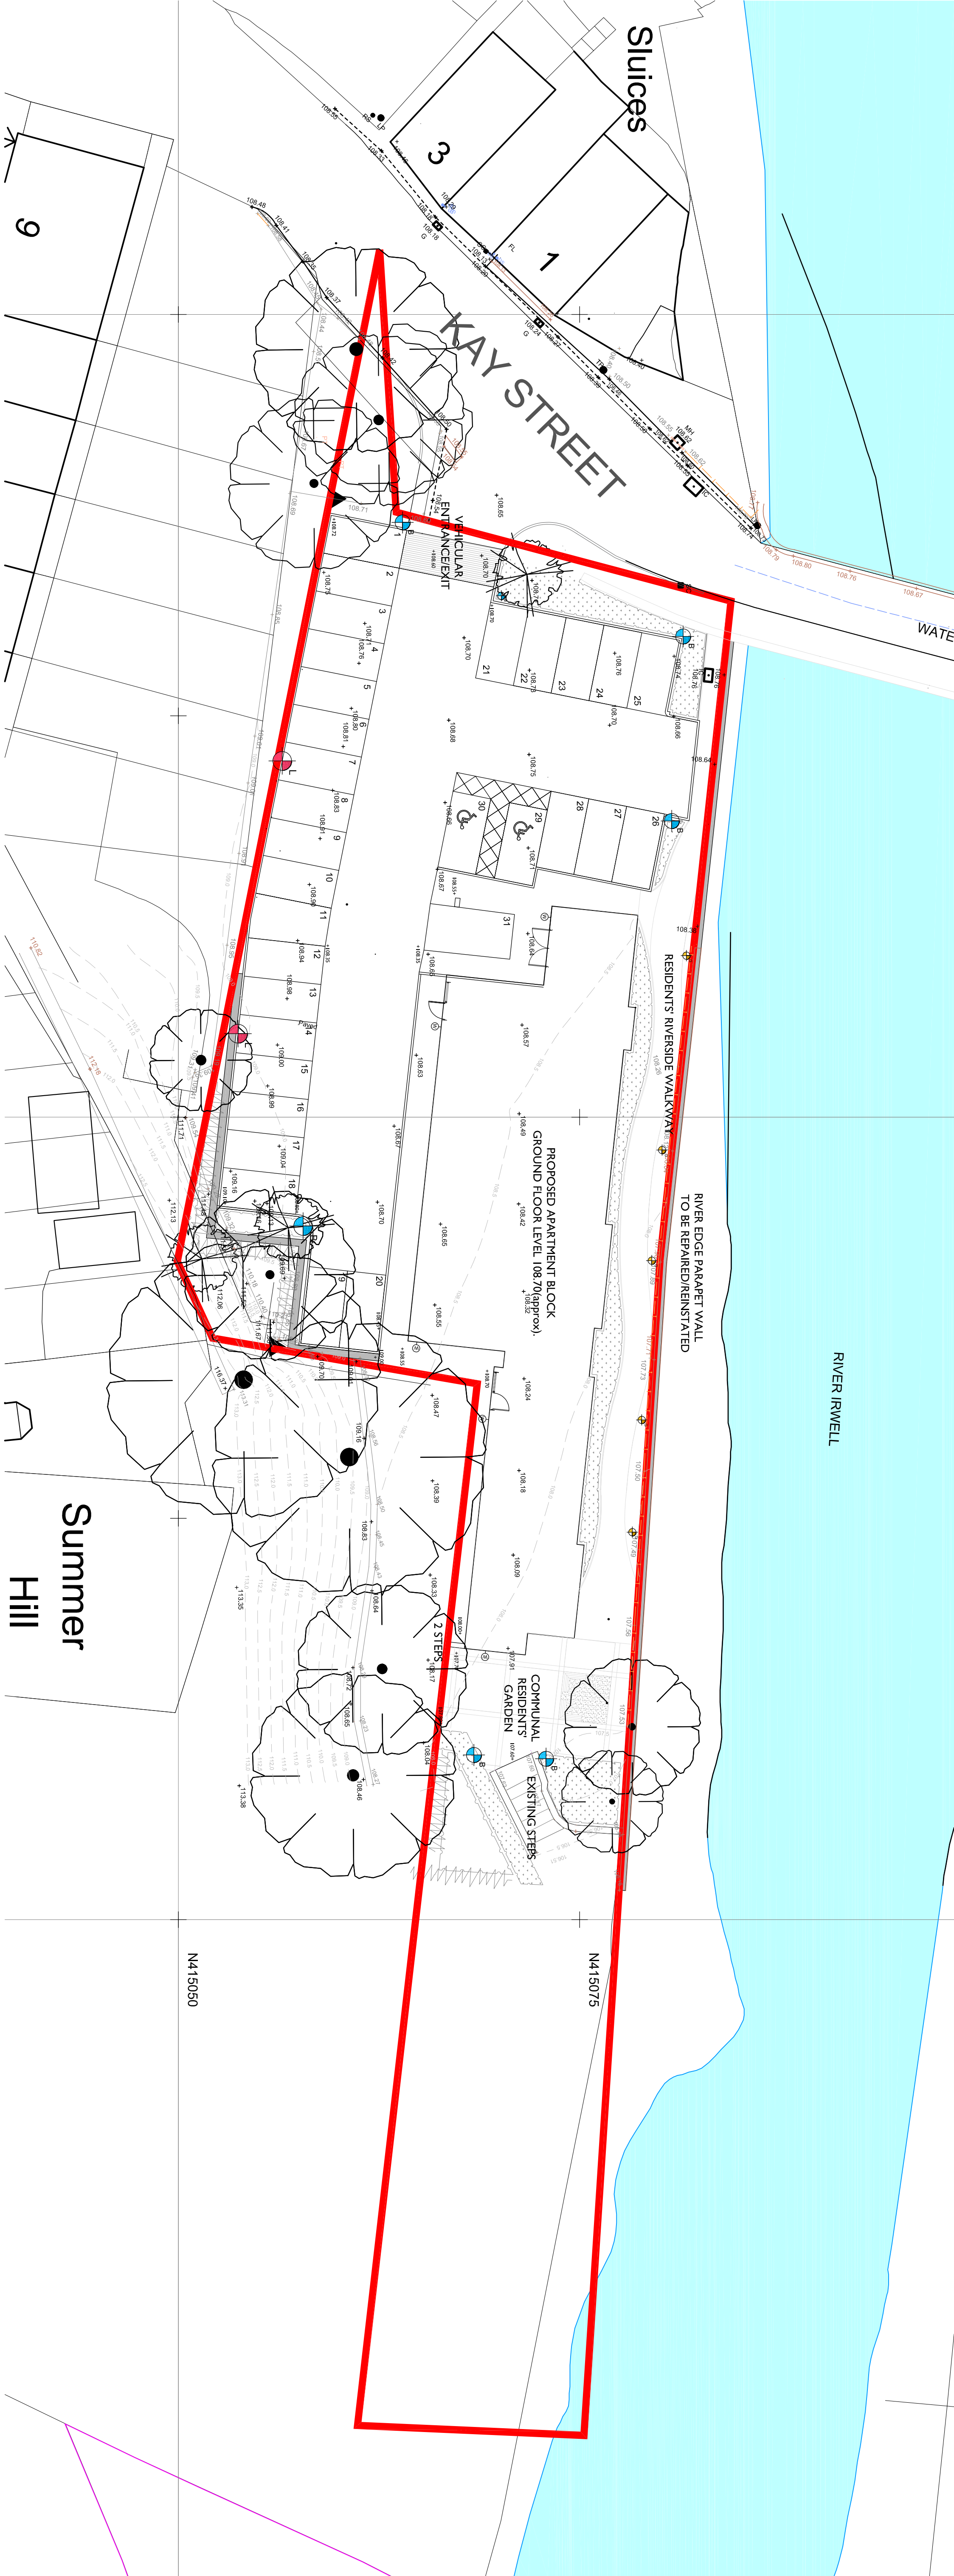


NOTES:
CONTRACTORS MUST VERIFY ALL DIMENSIONS ON SITE BEFORE
COMMENCEMENT OF ANY WORK OR PREPARING
MANUFACTURING DRAWINGS
DO NOT SCALE FROM THIS DRAWING
ANY DISCREPANCIES ON THIS DRAWING ARE TO BE
NOTIFIED TO THE ARCHITECT IMMEDIATELY
HATTRELL LLP COPYRIGHT

REV	AMENDMENT	DATE	CHKD
A	Existing wall to bridge shown	May 23 15	
B	Column lights amended	Nov 23 15	



HATTRELL LLP

SHARPE E KINGS COURT RAILWAY STREET ALTRINCHAM CHESHIRE WA14 2RD
TELEPHONE 0161 1320 4207
e-mail: design@hattrell.co.uk / www.hattrell.co.uk

CLIENT

Opuilwood Developments Ltd

PROJECT


Waterside,
Summerseat

DRAWING TITLE
Proposed External
Lighting Layout


SCALE @A1 DRAWN BY IS CHECKED DATE
1:200 ST 03/22

DRAWING No 24972-2-11 REVISION B

PLANNING

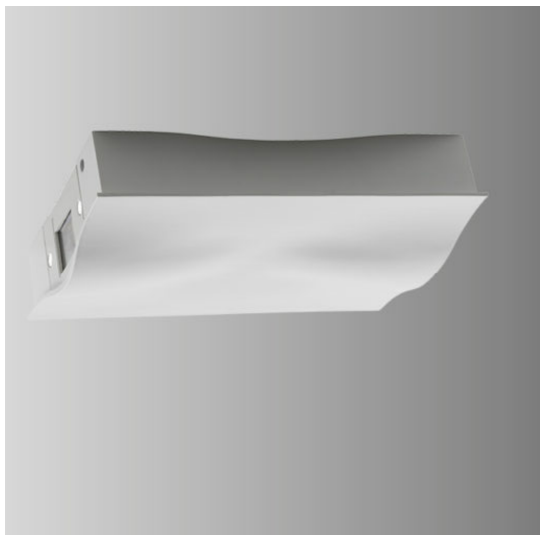

Steon : Elara Midi
2x26W LED Light Wall light with PPR
Luminous Efficacy: 108lm/w
Finish: Metallic Grey Powder Coated
Aluminium
Colour Temperature: 3000K
Size: H225mmxW160mmxD56mm

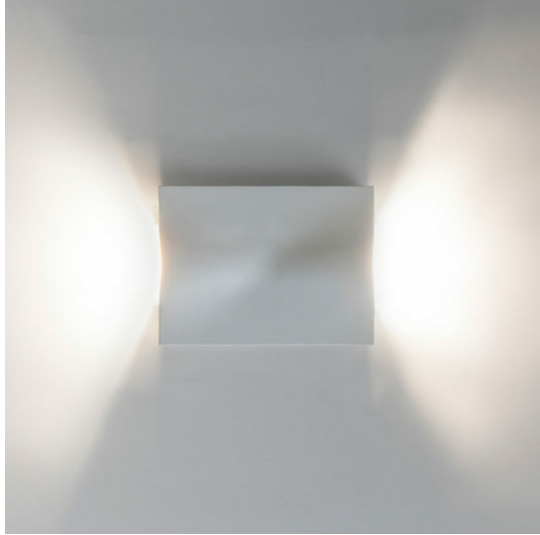

Steon : Monarch 14W LED Bollard
Luminous Efficacy: 35lm/w
Finish: Black Powder Coated
Aluminium
Colour Temperature: 4000K
Dims Dia65mm xH900mm



Steon : Nomus 1.5W LED
Groundlight
Finish: Stainless Steel
Colour Temperature: 3500K
Size: Dia88mm



Steon : Quad
Luminous Efficacy: 124lm/w
Finish: Black die-cast Aluminium
Colour Temperature: 4000K

