


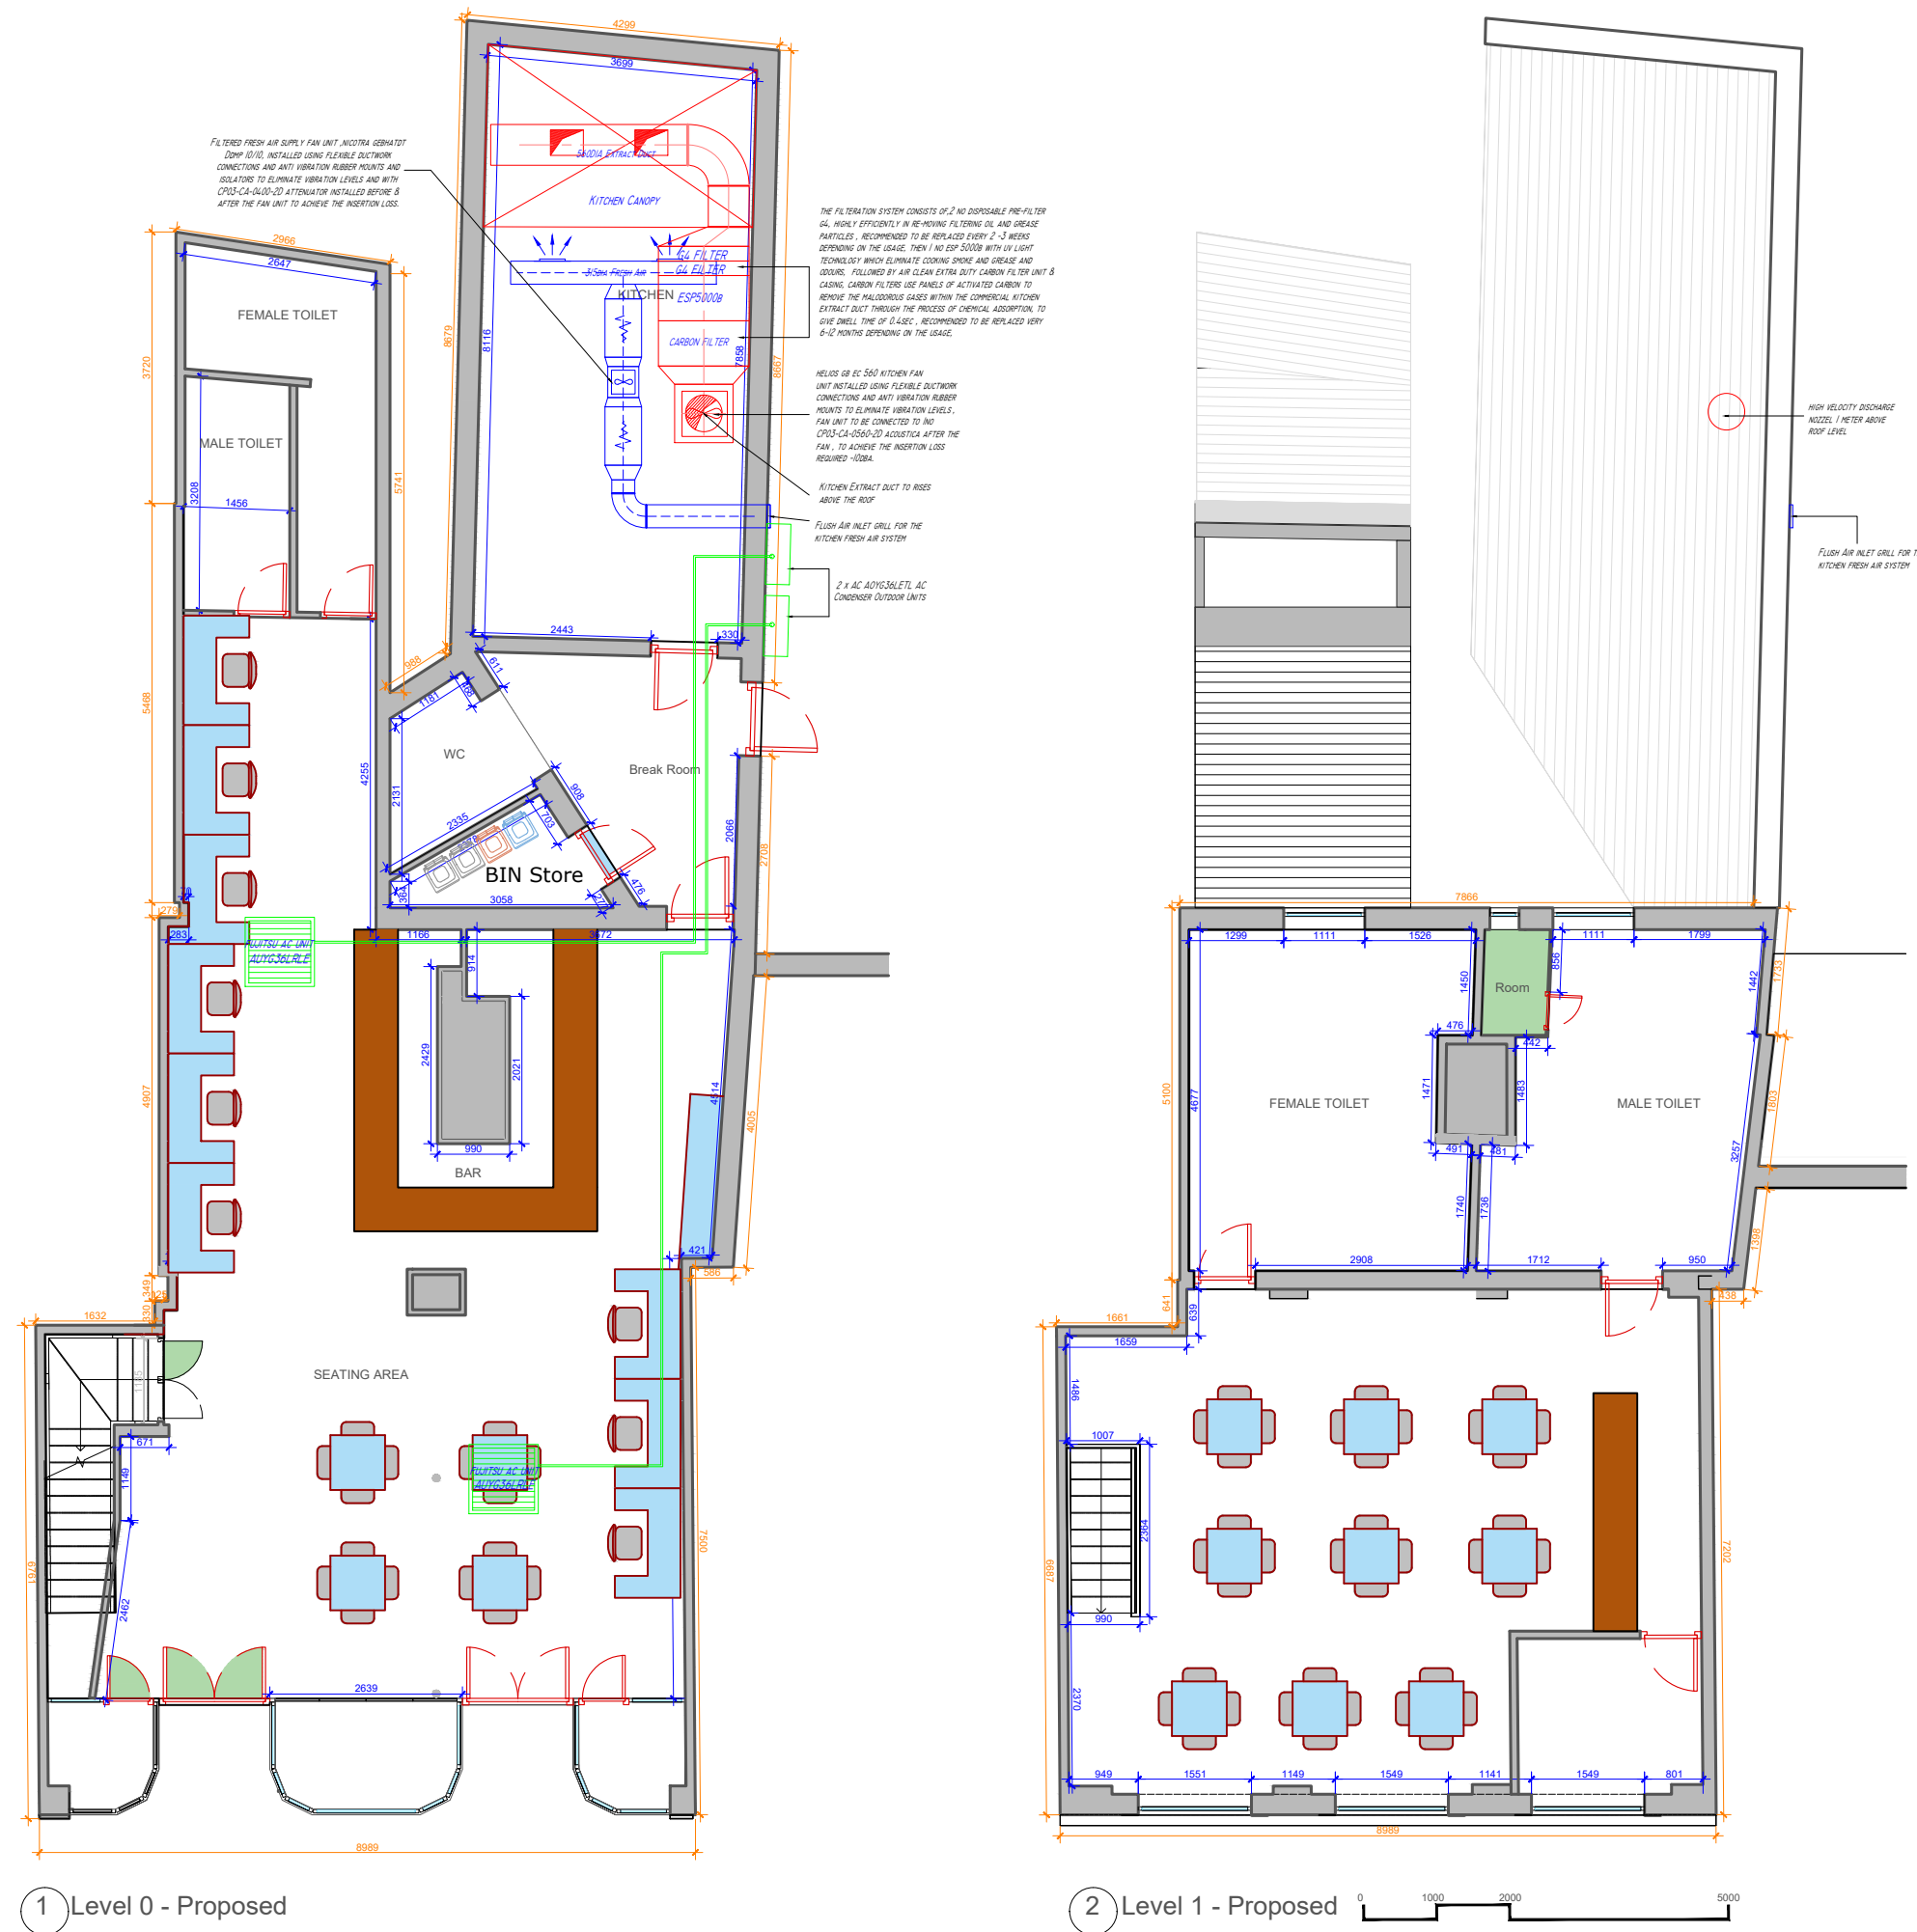

Note:

Project Title:  
12 Bolton Street -  
Proposed HVAC Plan

Drawing Number:  
01 - Proposed HVAC Plan

Scale:  
1:100 @ A3

Date:  
03/06/2024

**FAN  
RESCUE**

Commercial kitchen and HVAC  
System Specialists  
Established 2005

Ability House, Unit 129,  
121 Brooker Road,  
Waltham Abbey EN9 1JH  
Tel: +44 (0) 20 33082 936  
www.fanrescue.co.uk