


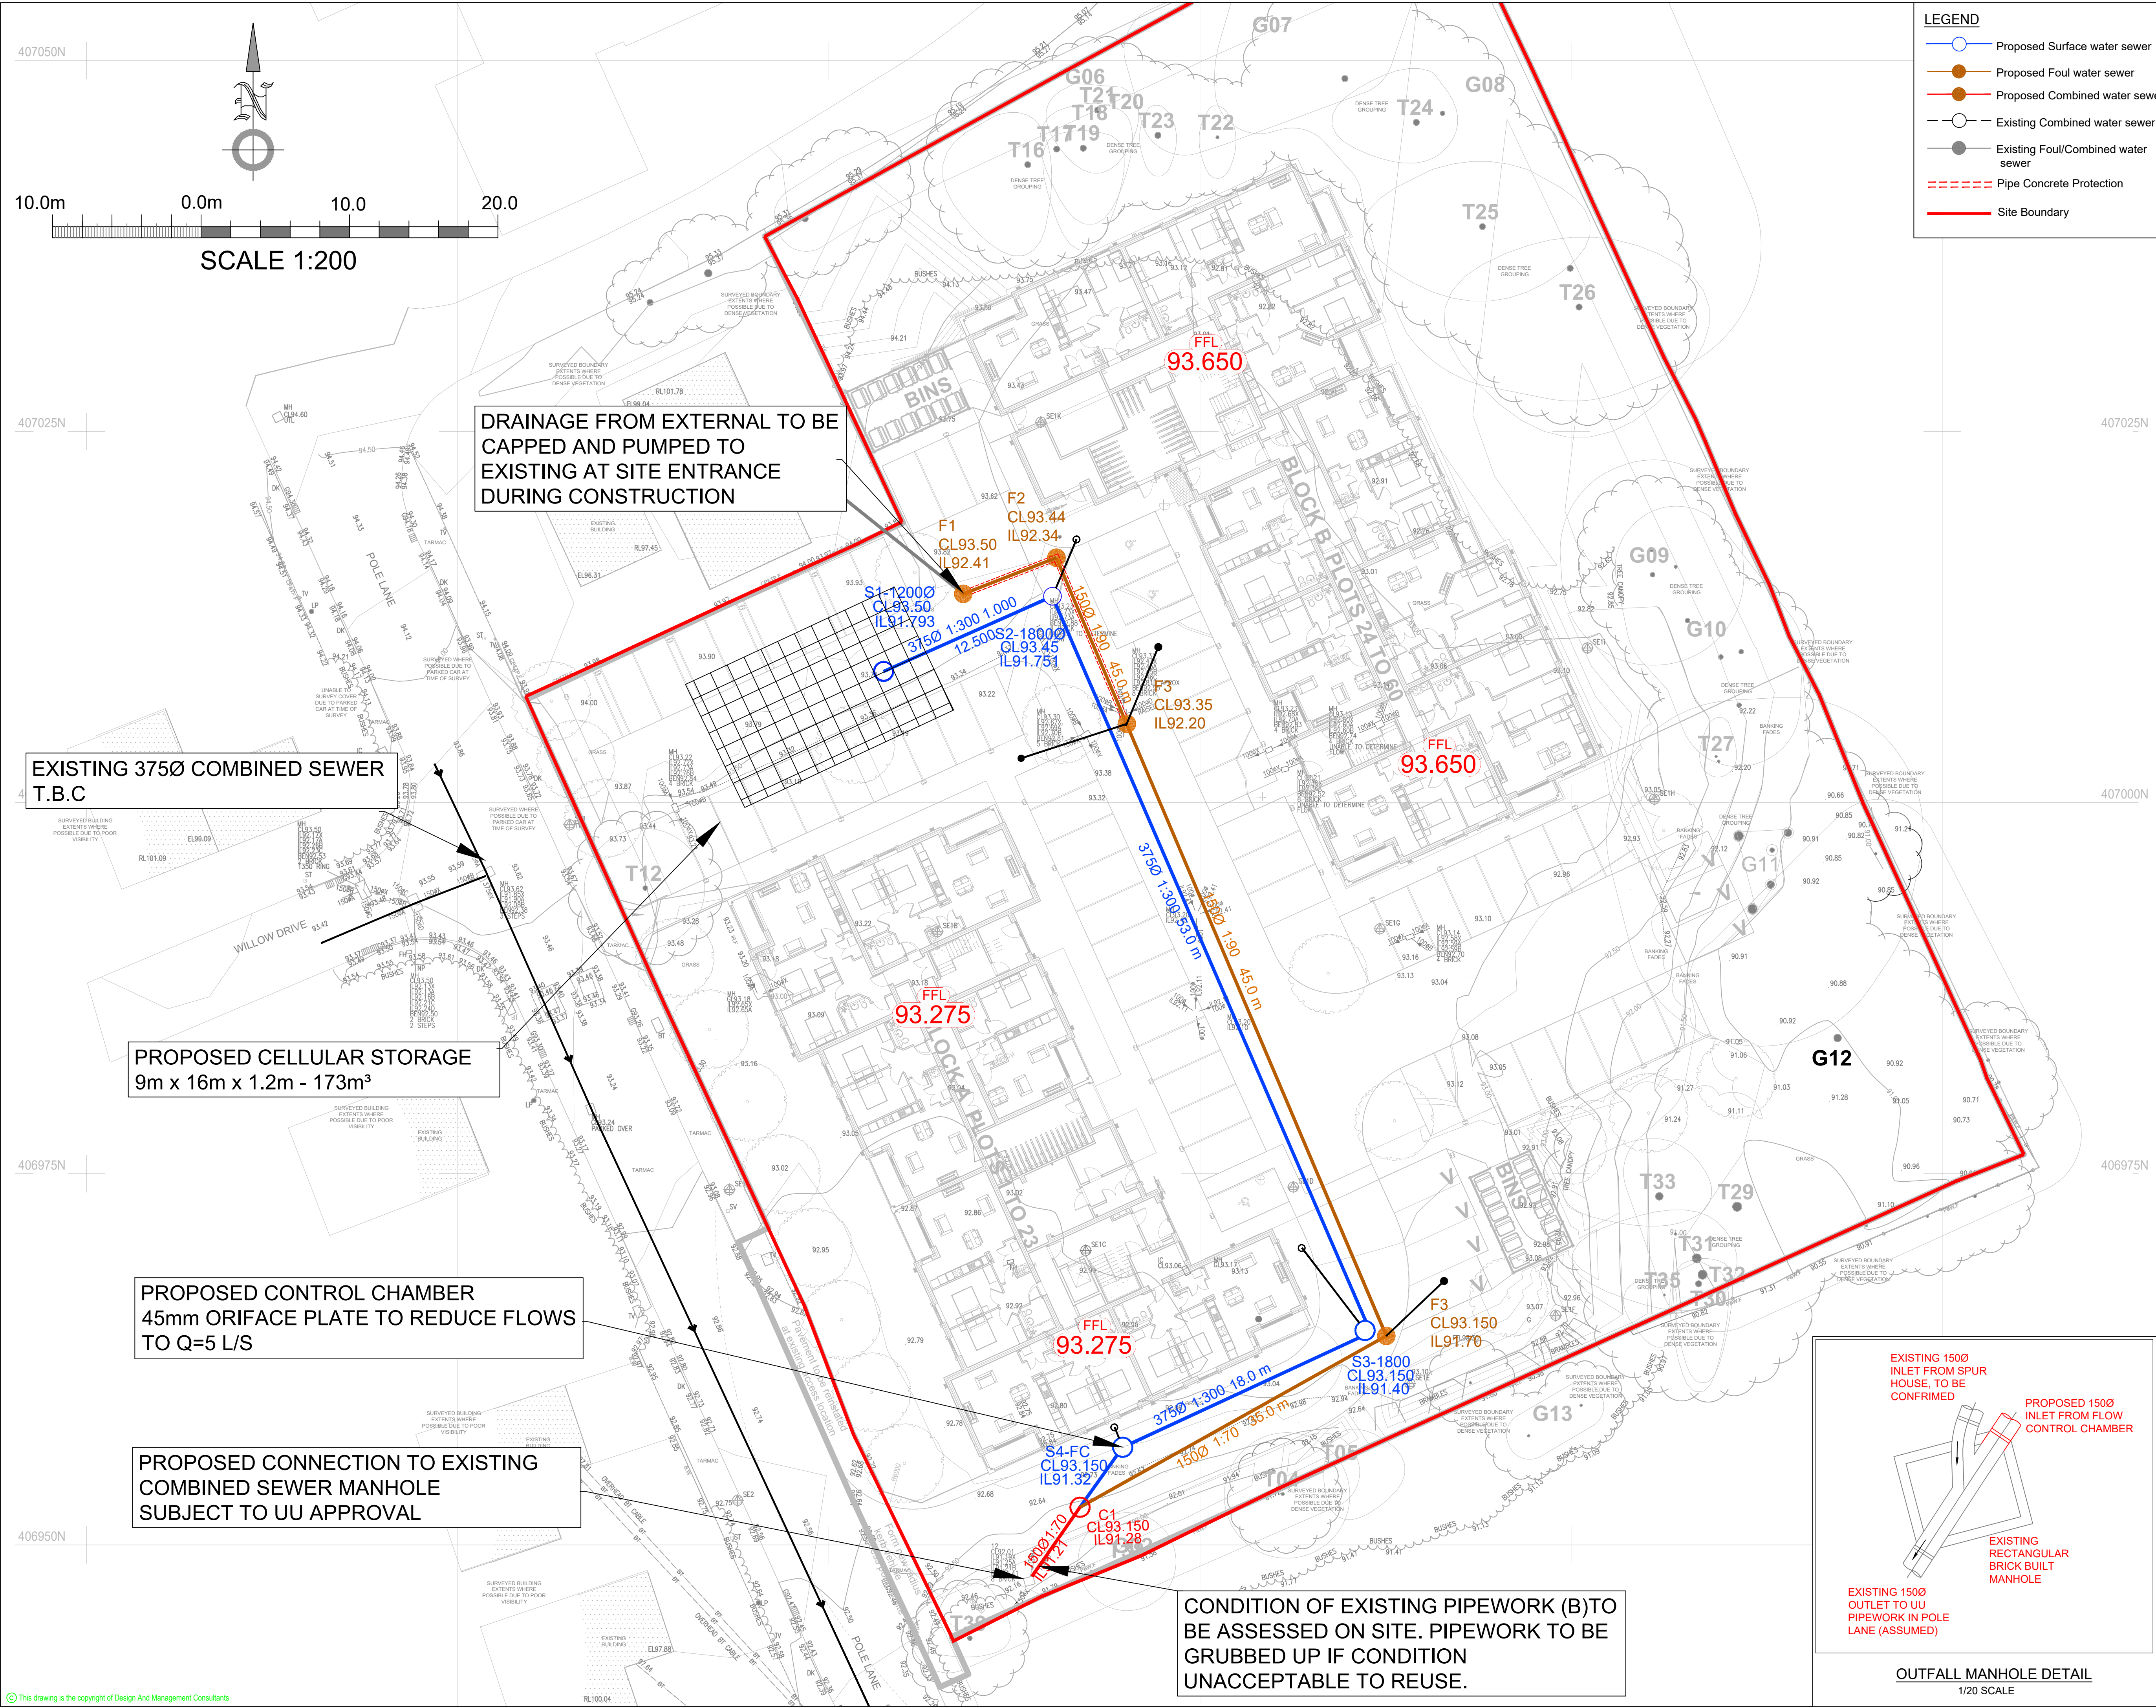

- LEGEND**
- Proposed Surface water sewer
 - Proposed Foul water sewer
 - Proposed Combined water sewer
 - Existing Combined water sewer
 - Existing Foul/Combined water sewer
 - Pipe Concrete Protection
 - Site Boundary

- NOTES**
- THIS DRAWING IS TO BE READ IN CONJUNCTION WITH ALL RELEVANT ARCHITECTS AND ENGINEERS DRAWINGS AND SPECIFICATIONS.
 - DO NOT SCALE THIS DRAWING. ALL DETAILS AND DIMENSIONS ARE TO BE CHECKED BY THE CONTRACTOR PRIOR TO COMMENCEMENT OF CONSTRUCTION. ANY DISCREPANCIES TO BE REPORTED TO THE ENGINEER.
 - ALL DIMENSIONS ARE IN METERS UNLESS NOTED OTHERWISE
 - ALL LEVELS ARE RELEVANT TO ORDNANCE DATUM (NEWLYN).
 - LOCATION OF EXISTING SEWERS, UTILITIES AND SERVICES TO BE SURVEYED BEFORE COMMENCING WORK ON SITE.
 - ALL ADAPTABLE SEWER WORKS AND MATERIAL TO BE IN ACCORDANCE WITH "SEWERS FOR ADOPTION" 6TH EDITION, THE RELEVANT BRITISH/EUROPEAN AND UNITED UTILITIES STANDARDS REQUIREMENTS ADDENDUM TO THE MECHANICAL AND ELECTRICAL SPECIFICATION AND KITEMARKED.
 - MANHOLE COVERS SHALL MUST HAVE A CLEAR OPENING OF 600mm AND SHALL BE CLASS D400 TO BS EN 124 WITH 150mm DEEP FRAMES IN HIGHWAYS.
 - FILLED GROUND MUST BE FILLED AND CONSOLIDATED UNDER THE SUPERVISION AND TO THE SATISFACTION OF UNITED UTILITIES BEFORE ANY SEWER WORKS ARE CARRIED OUT.
 - UNITED UTILITIES IS NOT OBLIGED TO ACCEPT FILTER DRAINLAND DRAINAGE RUN-OFF INTO THE PUBLIC SEWER NETWORK OR ADAPTABLE DRAINAGE SYSTEM (DIRECTLY OR INDIRECTLY). AN ALTERNATIVE METHOD OF DISPOSAL OF THE LAND DRAINAGE RUN-OFF WILL THEREFORE BE REQUIRED AND YOU WILL HAVE TO LAISE WITH THE LOCAL AUTHORITY, LAND DRAINAGE SECTION WITH REGARD TO THE DISPOSAL OF THE FILTER DRAINLAND DRAINAGE RUN-OFF.
 - COVER SLABS MUST CARRY THE BSI KITEMARK OR WILL BE REJECTED BY UNITED UTILITIES INSPECTOR. WHERE THE CLEAR OPENING OF THE KITEMARKED PRODUCT IS DIFFERENT TO THAT OF THE COVER AND FRAME, A LOADING BEARING SLAB SHOULD BE FITTED ABOVE THE COVER SLAB TO BRING THE SIZE DOWN TO 600mm x 600mm FOR THE UNITED UTILITIES SPECIFIED COVER SIZE. PLEASE REFER TO CONCRETE PIPE SYSTEMS ASSOCIATION (CPSA) TECHNICAL BULLETIN ISSUED AUTUMN 2004 FOR KITE MARKED COVER SLAB OPENING SIZES.
 - SULPHATE RESISTANT CEMENT (C25-DC2) AND PRECAST CONCRETE PRODUCTS MUST BE USED OR A LABORATORY REPORT PROVIDED PROVING THAT SUCH PRECAUTIONS ARE NOT NECESSARY.
 - THE ADAPTABLE SEWERS SHOULD BE A MINIMUM OF 1.00m AND MANHOLES 0.50m FROM KERB FACES AND SERVICE MARGINS.
 - "SEWERS MUST HAVE 5.00 METRES CLEARANCE FROM TREES AND HEDGES (PLEASE ALSO REFER TO FIGURE 2.3 ON PAGE 33 IN "SEWERS FOR ADOPTION" 6TH EDITION FOR RESTRICTIONS ON TREE PLANTING ADJACENT TO SEWERS.
 - SEWERS TO BE LAID IN CLASS "S" BEDDING (150mm GRANULAR BED AND SURROUND), WHERE DEPTH OF COVER TO TOP OF THE SEWER IS LESS THAN 1.20m IN HIGHWAYS AND VERGES (OR LESS THAN 900mm IN NONE VEHICULAR ACCESS THEN A CONCRETE SLAB SHOULD BE PROVIDE ABOVE GRANULAR BED AND SURROUND.
 - BEDDING AND BACKFILL MATERIAL TO CONFORM TO THE REQUIREMENT OF WATER INDUSTRY SPECIFICATION 4-08-02 (TABLE A2).
 - THE CHAMBER SIZE OF MANHOLES WITH MORE THAN ONE CONNECTION IN THEM MAY NEED TO BE INCREASED AN INCREMENT TO ACCOMMODATE THE CONNECTIONS AND BENDS.
 - UNITED UTILITIES POLICY IS NOT TO ACCEPT TYPE "C" BRICK MANHOLES AND 1050mm DIA MANHOLE RINGS. HOWEVER IT IS PREFERRED THAT YOU USE A TYPE "B" MANHOLE WITH 1200mm DIA OR 1500mm DIA RINGS. WITH THE OPENING SITED OVER THE CHANNEL, WHERE DEPTH OF COVER TO PIPE SOFT IS 1.00-1.50m.
 - THE MINIMUM CRUSHING STRENGTH FOR CLAY PIPES SHOULD BE AS FOLLOWS: 100mm DIA, 40kN/m, 150mm DIA, 40kN/m, 225mm DIA, 45kN/m and 300mm DIA, 72kN/m. THE MINIMUM CRUSHING STRENGTH FOR CONCRETE PIPES SHOULD BE TO CLASS 120 TO EN 1916 / BS 5911-1:2002"
 - PRIVATE DRAINAGE SHOWN ON THIS DRAWING FOR INFORMATION. REFER TO APPROPRIATE DAM CONSULTANTS DRAWINGS FOR CURRENT LAYOUTS AND ADDITIONAL INFORMATION.
 - INVERT AND COVER LEVELS OF EXISTING MANHOLE TO BE CONFIRMED PRIOR TO WORKS COMMENCING ON SITE.

A	Updated to suit latest layout	25.03.26	ET	DW
/	For Construction	27.02.26	PG	DW

Rev:	Description:	Date:	By:	Chkd:
Status:				

CONSTRUCTION

Client: **WATSON HOMES**

Project: **SPURR HOUSE**

Dwg Title: **DRAINAGE LAYOUT**

Design and Management Consultants Ltd.

760 MANDARIN COURT

CHESTER

WA1 1GG

Phone: (01925) 36 30 33

Email: BD@DAM-Consultants.com

Website: DAM-Consultants.com

Scale: 1:200

Size: A1


First Issue: 02/26

Drawn: PG

Checked: DW

Rev: A

Drawing No: 24104-C-140

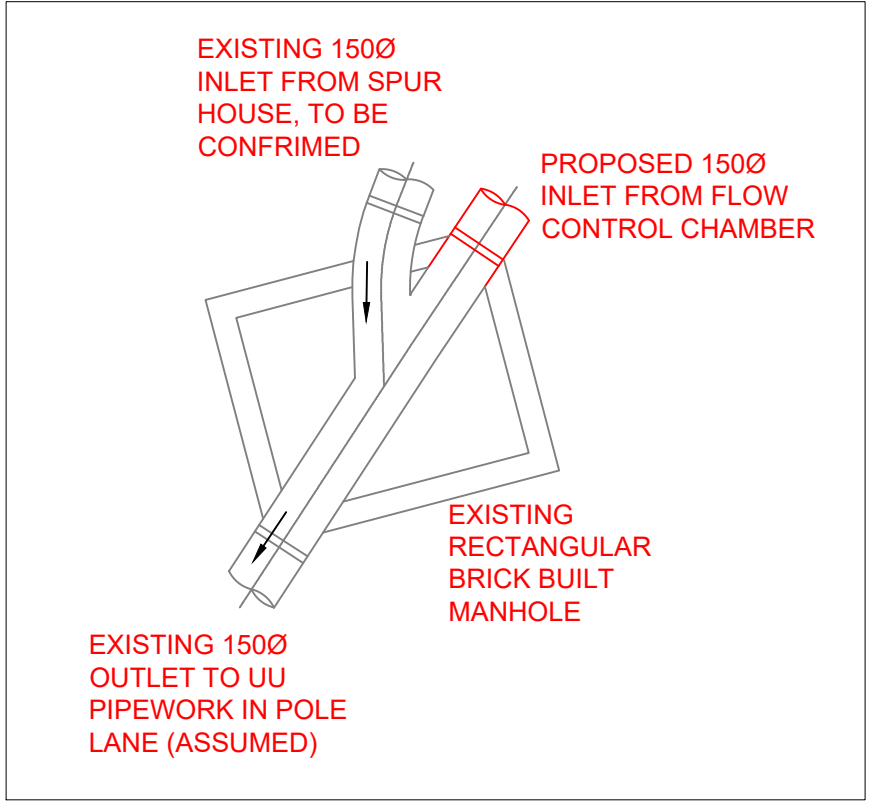

OUTFALL MANHOLE DETAIL
1/20 SCALE