


Luminaire Schedule										
Symbol	Ref	Qty	Config	Description	Mtg Height	Lumens	Cutoff Class	Total MF	Unit Watts	
	A	1	Single	Korium Wall 16 LED 4K 700mA Clear-Wide	2.4	3947	Full Cutoff	0.640	37	
	B	50	Single	Garda Pro Assym 900-12LED-4K	1.6	1467	Semi-Cutoff	0.750	12	
	C	8	Single	Garda Pro Assym 900-12LED-4K	1	1467	Semi-Cutoff	0.750	12	

Calculation Results Summary									
Grid Reference	Measurement	Units	Eav	Emax	Emin	Uo	Ud	X Pitch	Y Pitch
Lift Entrance	Illuminance	LUX	160.06	198.9	124.4	0.78	0.63	0.5	0.5
Ramp 1	Illuminance	LUX	167.97	228.8	74.1	0.44	0.32	0.5	0.5
Ramp 2	Illuminance	LUX	173.84	330.6	71.9	0.41	0.22	0.5	0.5
Span	Illuminance	LUX	174.92	352.0	71.8	0.41	0.20	0.5	0.5
Stairs 1	Illuminance	LUX	234.91	456.6	94.1	0.40	0.21	0.5	0.5

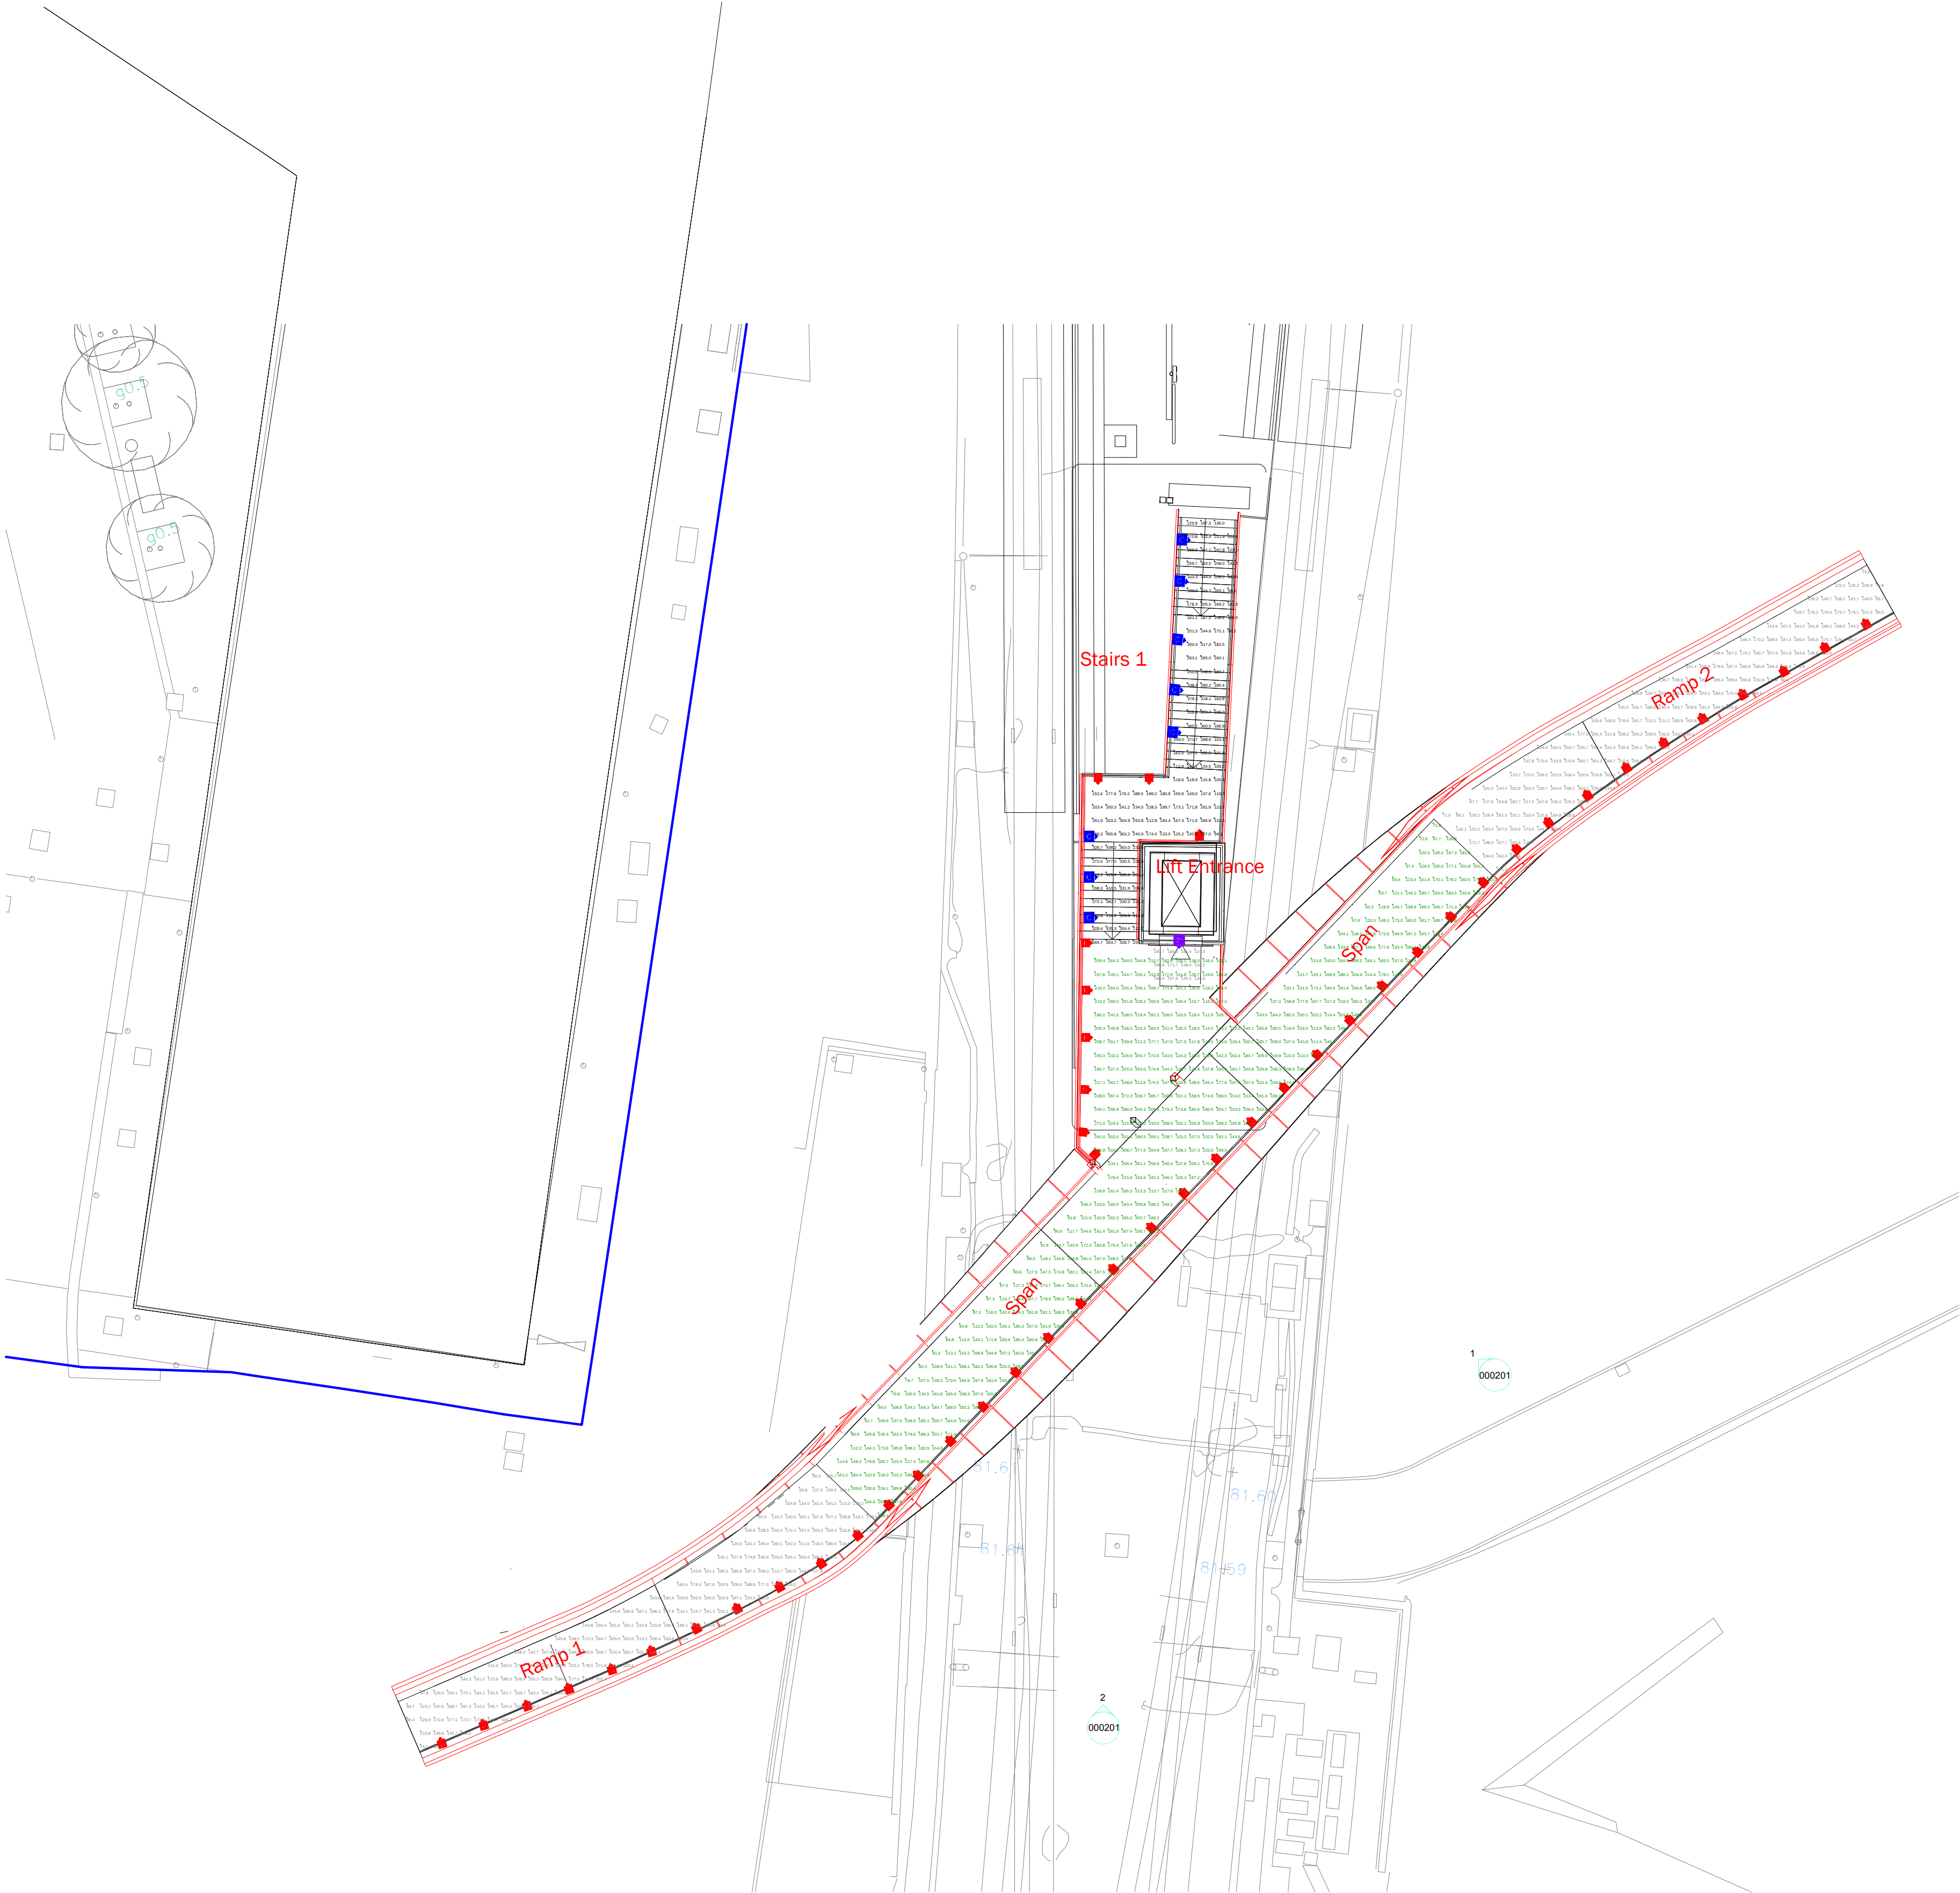

REF A:
Korium Wall 16 LED 4K 700mA Clear-Wide Optic.
RAL9005 Black Finish + Emergency Pick.

REF B:
Garda Pro Assym 900-12LED-4K 900MM.

REF C:
Garda Pro Handrail 4K 900MM.

SAFETY HEALTH & ENVIRONMENTAL INFORMATION

ALL WORKS ARE TO BE CARRIED OUT BY COMPETENT CONTRACTORS, FAMILIAR WITH THIS TYPE OF WORK AND IN LINE WITH AN APPROVED CONSTRUCTION RISK ASSESMENT AND METHOD STATEMENT.

WHERE THERE ARE SIGNIFICANT RESIDUAL RISKS, OVER AND ABOVE THE HAZARDS AND RISKS THAT WHAT WOULD NORMALLY BE ANTICIPATED FOR THIS TYPE OF CONSTRUCTION ACTIVITY, THE DESIGNERS HAVE NOTED THEM BELOW.

ITEM	HAZARD	RISK
XX	XXXXX	XXXXXX

NOTES

- DO NOT SCALE OFF THIS DRAWING.

P01	07.03.25	MW	PRELIMINARY ISSUE FOR COMMENT	MB	DO
REV	DATE	BY	DESCRIPTION	CHK	APP

Architect

Client

S3 - FOR REVIEW

DESIGN ENGINEER SUSTAIN

WWW.FUTURESERV.CO.UK

Suite 2.02 - Ambler House - Trevelyan Square
Leeds - LS1 6ED
☎ +44 (0)113 543 0803 ✉ enquires@futureserv.co.uk 🌐 www.futureserv.co.uk

Project Title
BURY INTERCHANGE
Bury Tram Stop
Haymarket St, Bury BL9 0AY

Drawing Title
LIGHTING SCHEME
FOOTBRIDGE

Project No	Y5604
Drawn & Checked by	MB
Reviewed by	DO
Date	07.03.25
Scale	1:150
Drawing No.	Rev.
16012-FUT-BRY-XXX-D-BV-000011 P01	