
 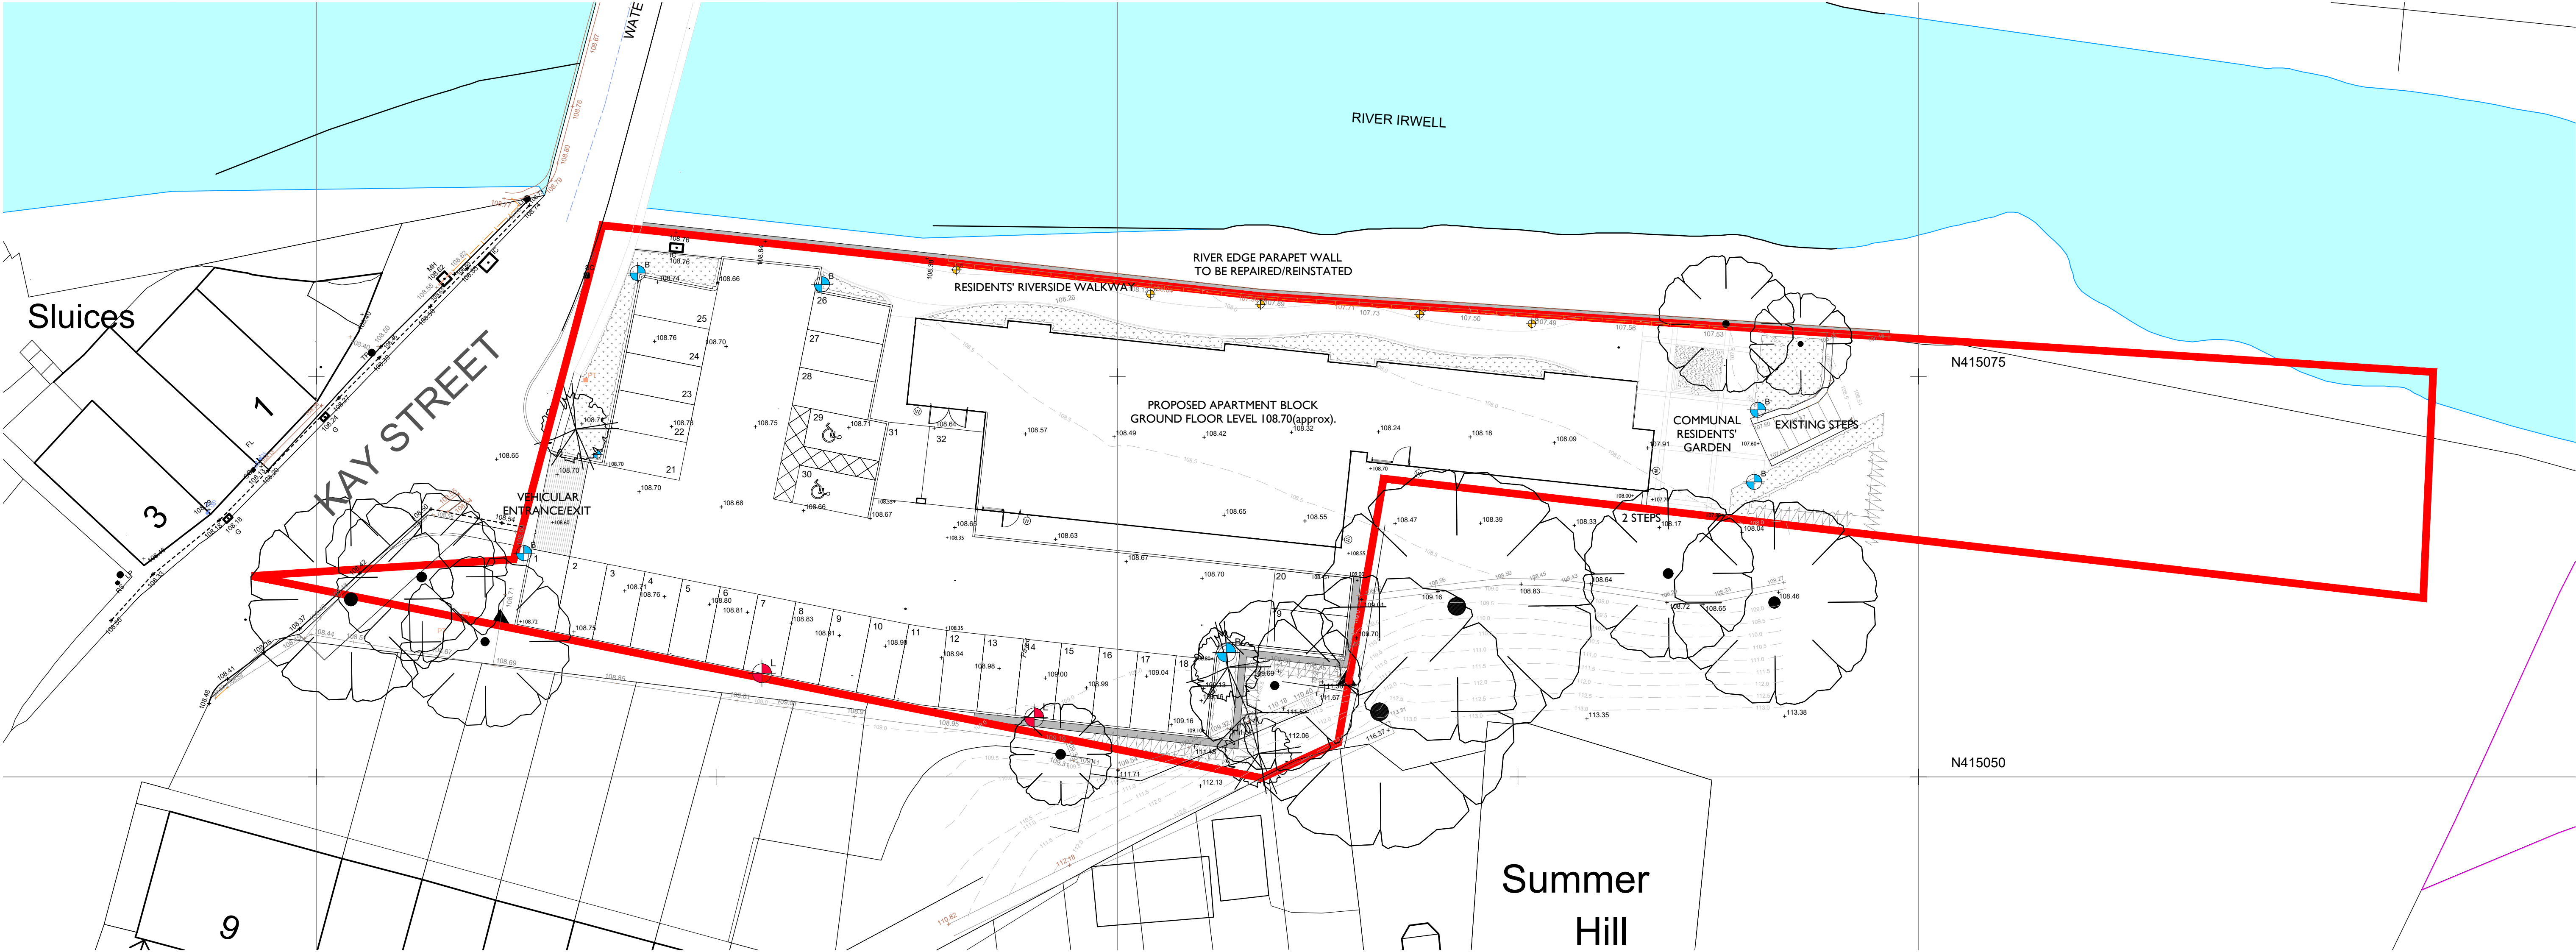


NOTES:
CONTRACTORS MUST VERIFY ALL DIMENSIONS ON SITE BEFORE
COMMENCEMENT OF ANY WORK OR PREPARING
MANUFACTURING DRAWINGS
DO NOT SCALE FROM THIS DRAWING
ANY DISCREPANCIES ON THIS DRAWING ARE TO BE
NOTIFIED TO THE ARCHITECT IMMEDIATELY
HATTRELL DS ONE ARCHITECTS LLP COPYRIGHT

REV	AMENDMENT	DATE	CHKD
A	Existing wall to bridge shown	May 23	IS



HATTRELL LLP

Suite E KINGS COURT RAILWAY STREET ALTRINCHAM CHESHIRE WA14 2RD
TELEPHONE 0161 820 4207
e-mail: design@hattrelldsone.co.uk / www.hattrelldsone.co.uk

CLIENT

Opulwood Developments Ltd

PROJECT

Waterside,
Summerseat

DRAWING TITLE
Proposed External
Lighting Layout

SCALE @A1 DRAWN BY CHECKED DATE
1:200 ST IS 03/22

DRAWING No REVISION
2492-2-11 A

PLANNING



Steon : Elara Midi
2x26W LED Light Wall light with PIR
Luminous Efficacy: 108lm/w
Finish: Metallic Grey Powder Coated
Aluminium
Colour Temperature: 3000K
Size: H225mmxW166mmxD56mm



Steon : Monarch 14W LED Bollard
Luminous Efficacy: 85lm/W
Finish: Black Powder Coated
Aluminium
Colour Temperature: 4000K
Dims Dia165mm xH900mm



Steon : Nomus 1.5W LED
Groundlight
Finish: Stainless Steel
Colour Temperature: 3500K
Size: Dia88mm



Steon : Condor Midi 150W LED
Luminous Efficacy: 116lm/W
Finish : Grey Powder Coated
Aluminium
Colour Temperature: 4000K
Asymmetric 150° beam angle

- W Wall Light : Steon Lighting, Elara Midi or equal approved
- L Column : Steon Lighting, Condor Midi or equal approved
- B Bollard : Steon Lighting, Monarch or equal approved
- G Groundlight : Steon Lighting, Nomus or equal approved

