
 


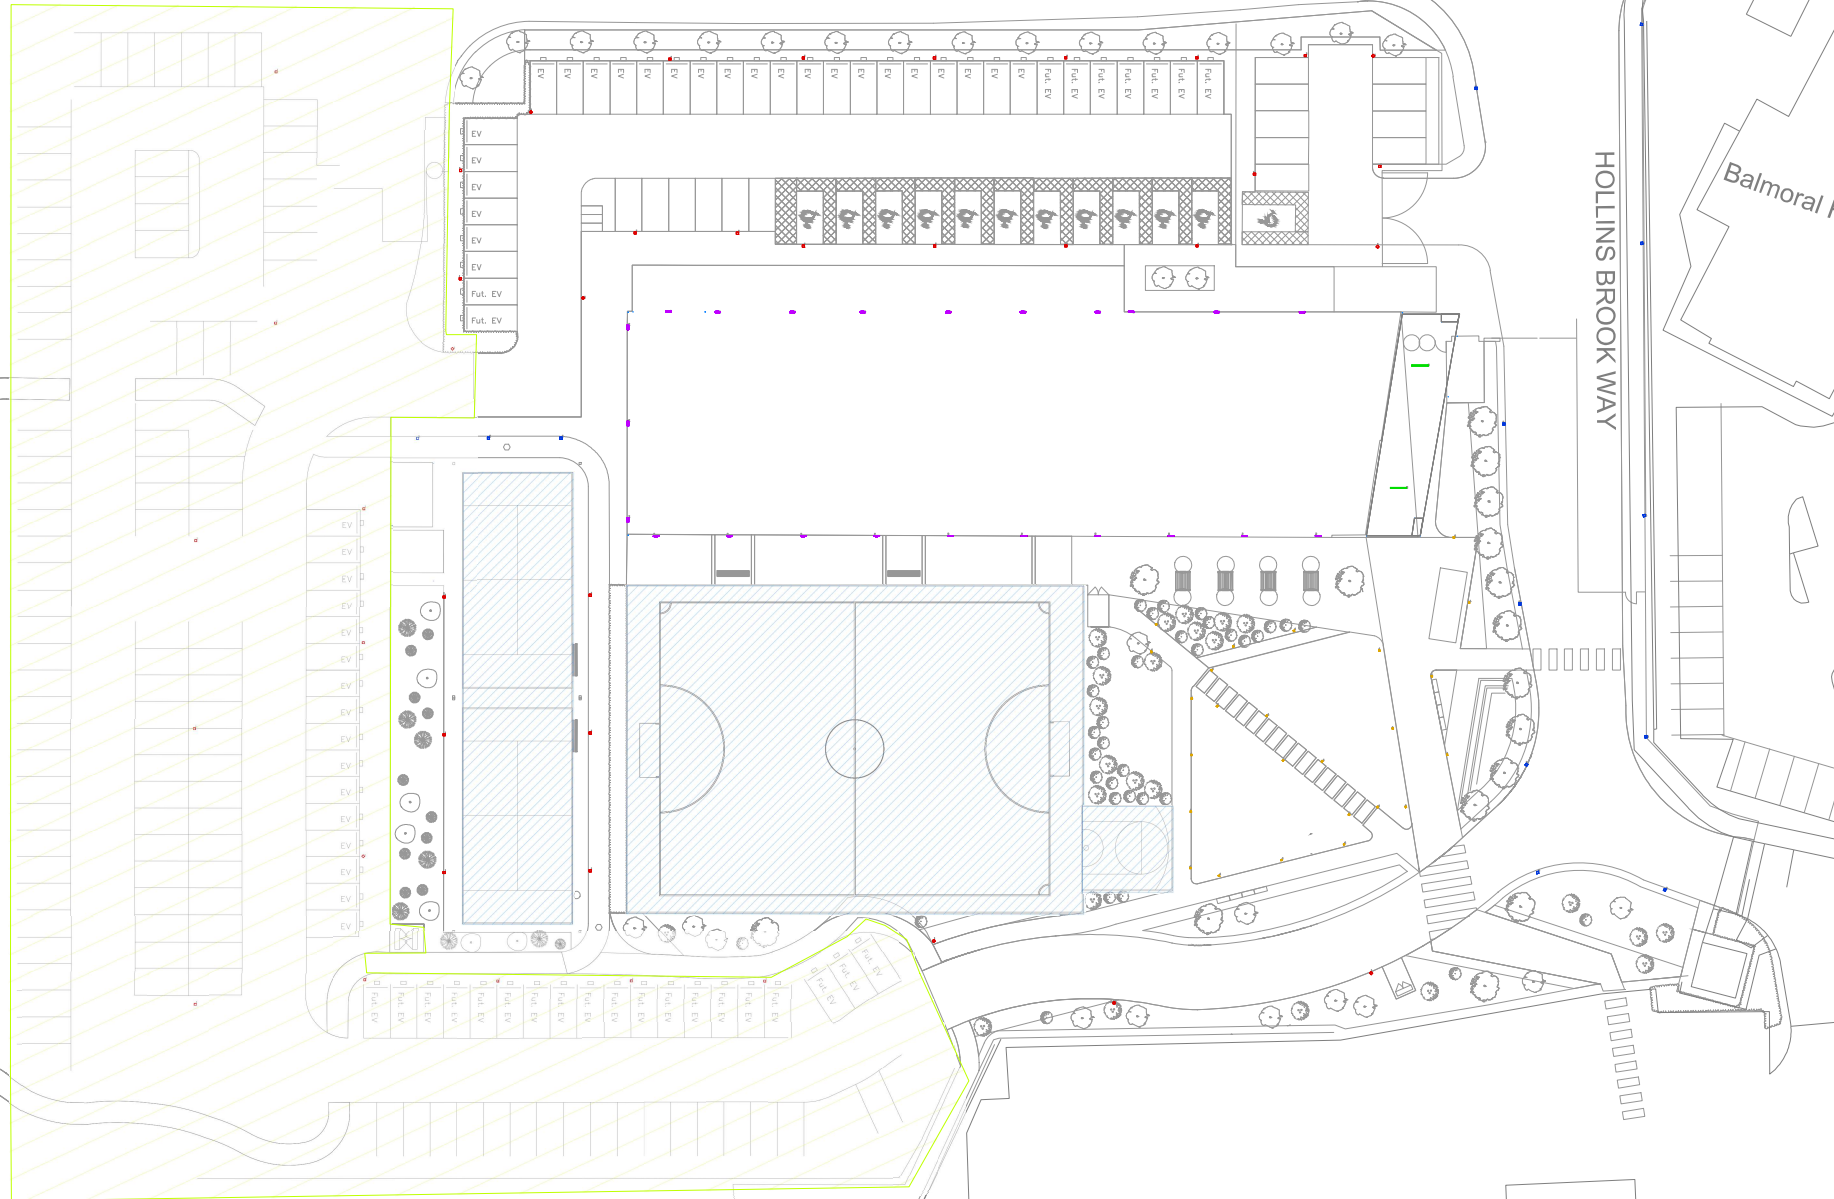

Luminaire list (Site 1)								
Index	Manufacturer	Article name	Item number	Filing	Luminaire Watt	Maintenance factor	Connected load	Quantity
1	Schneider	SHARPLE 160 LPI 160 (Lum. Super-compact, PC, 160Watt) Super Slimline (Lum. Super-compact, PC, 160Watt) Compact (Lum. Super-compact, PC, 160Watt) 830 230V 01-37-043 #94492	#94492	1x 16 SH-CP-160-01-37-043	2742 lm	0.80	26 W	43
2	Midwest Lighting	HL0-1900 H000	H000000	1x HL000000	1000 lm	0.80	14.2 W	23
3	Recess Lighting	Kang, ETL, E-23W - Opt - SuperCompact - #000N	#11918	1x Kang E23 - 23W - Opt	3330 lm	0.80	25 W	2
4	Schneider	CORING 400 230W Corvinox, PC Super Slimline (Lum. Super-compact, PC, 160Watt) Compact (Lum. Super-compact, PC, 160Watt)	289162	1x 20 WFL230PWR (lum. power) 830 230V	1120 lm	0.80	9 W	25
5	Schneider	SHARPLE 160 LPI 6542 900W SHARPLE 160 LPI 6542 900W Super Slimline (Lum. Super-compact, PC, 160Watt) Compact (Lum. Super-compact, PC, 160Watt) 830 230V 01-37-043 #94492	#92602	1x 16 SH-CP-160-01-37-043	5106 lm	0.80	36.5 W	13

- NOTES:**
1. ALL DIMENSIONS ARE IN mm.
 2. THIS DRAWING TO BE READ IN CONJUNCTION WITH ALL RELEVANT ARCHITECTS AND SERVICES ENGINEERS DRAWINGS AND SPECIFICATIONS.
 3. ALL DIMENSIONS TO BE CHECKED ON SITE BY THE CONTRACTOR AND ANY DISCREPANCIES BROUGHT TO THE ENGINEERS & ARCHITECTS ATTENTION IN ACCORDANCE WITH THE SPECIFICATION.
 4. ALL PROPRIETARY PRODUCTS TO BE USED STRICTLY IN ACCORDANCE WITH THE MANUFACTURERS SPECIFICATION AND DETAILS.
 5. ALL TEMPORARY WORKS ARE TO BE DESIGNED AND INSTALLED BY THE CONTRACTOR.
 6. ANY GROUNDING, BUILDING LINES, ETC. ARE TO BE SET OUT IN ACCORDANCE WITH THE RELEVANT ARCHITECTS DRAWINGS.

LEGEND



P03	17.12.25	PLANNING SUBMISSION	KCR	DH
P02	09.12.25	STAGE 3 RESUE	KCR	DH
P01	25.10.25	STAGE 3 RESUE	KCR	DH
REV	DATE	DESCRIPTION	CHK	APP
© This drawing is the property of Kennedy Redford Limited and the information can only be used for their prior permission. 				
CLIENT				
JD SPORTS PLC				
PROJECT NAME				
JD SPORTS CAMPUS				
DRAWING TITLE				
EXTERNAL LIGHTING LAYOUT				
DATE	SCALE	SIZE	DRAWN BY	REV
14.10.25	NTS	A1	DHO	P03
DESIGN STAGE				
STAGE 3				
S4 - ISSUED FOR STAGE APPROVAL				
DRAWING NUMBER				
250715 - KR-D - ZZ - XX - DR - E - 6330				