


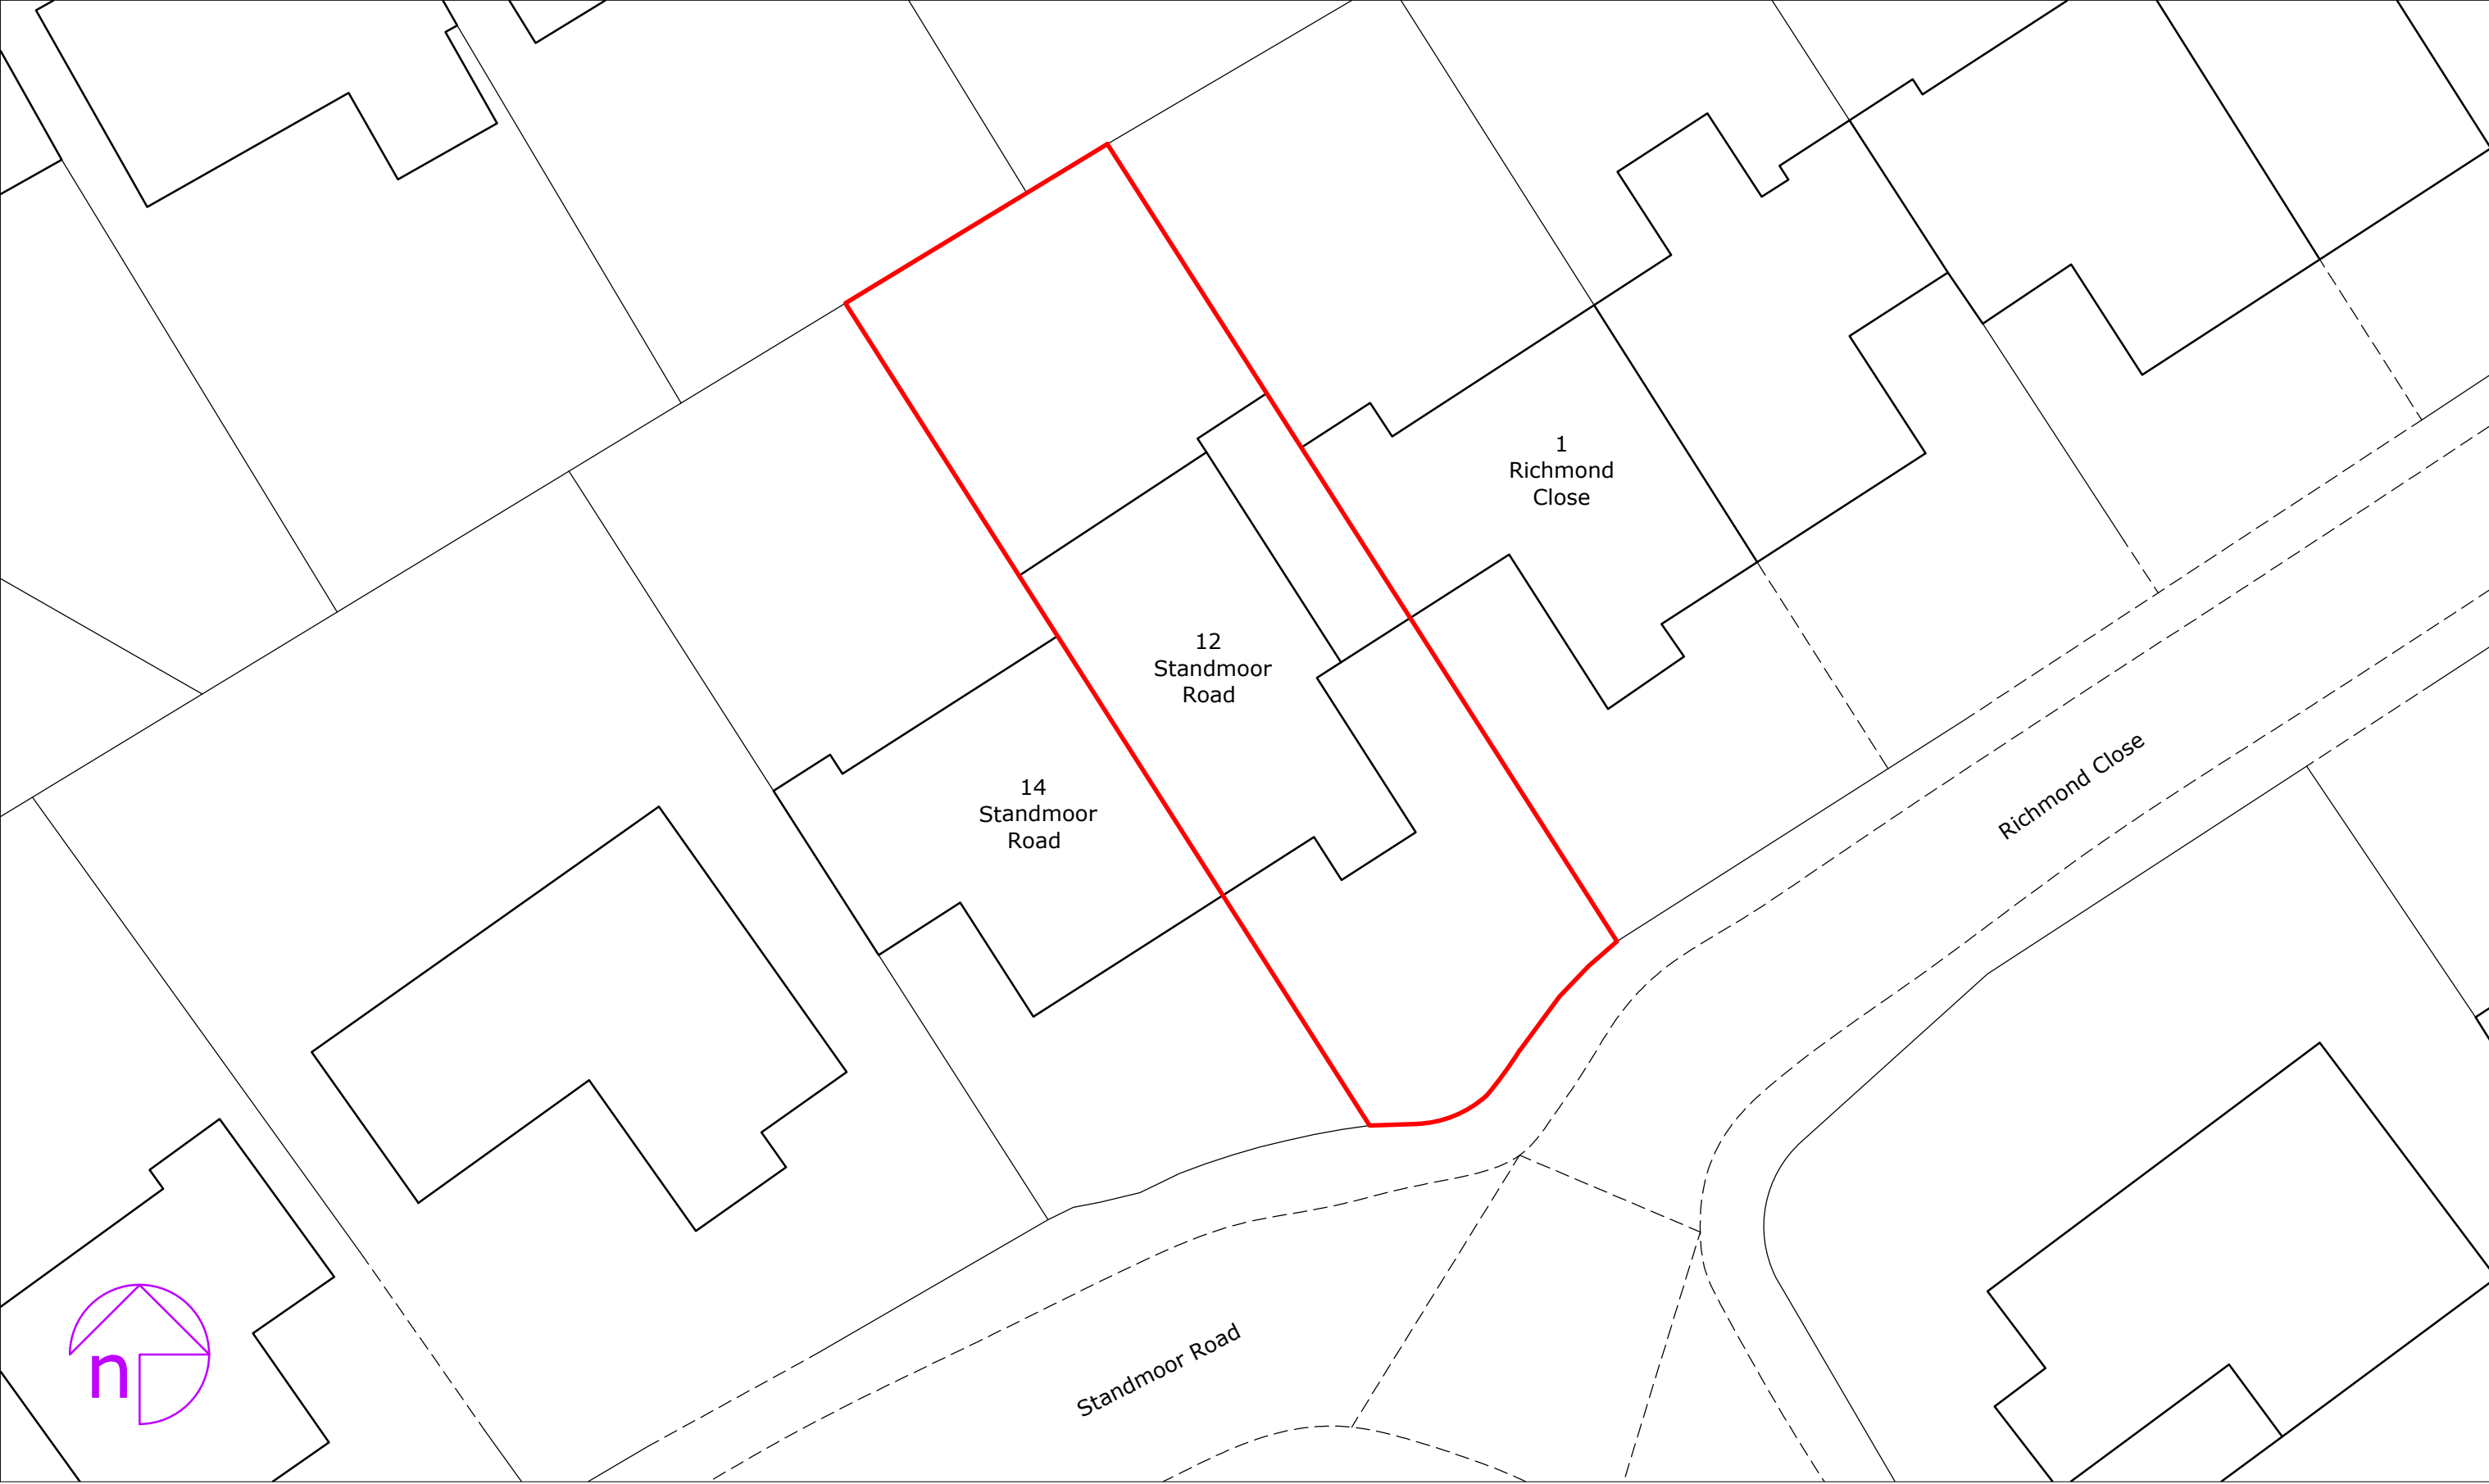

1:200

0

2

4

6

8

10

12

14

16

18

20

30

40m

Rev:	Description:	By:	Date:

Scale:	Paper Size:	Drawn:	Checked:
1:200	A3	D. Rodriguez	
Project ID:	Drawing No:	Revision:	Date:
J-31CB8C3B	01	-	10.01.2025



octopusenergy

services

Accredited by:



Client/Project:

Jonaid Ashraf

12, Standmoor Road

Whitefield M45 7PN

Project status:

PLANNING (installation of air source heat pump)

Drawing title:

Site plan as existing